


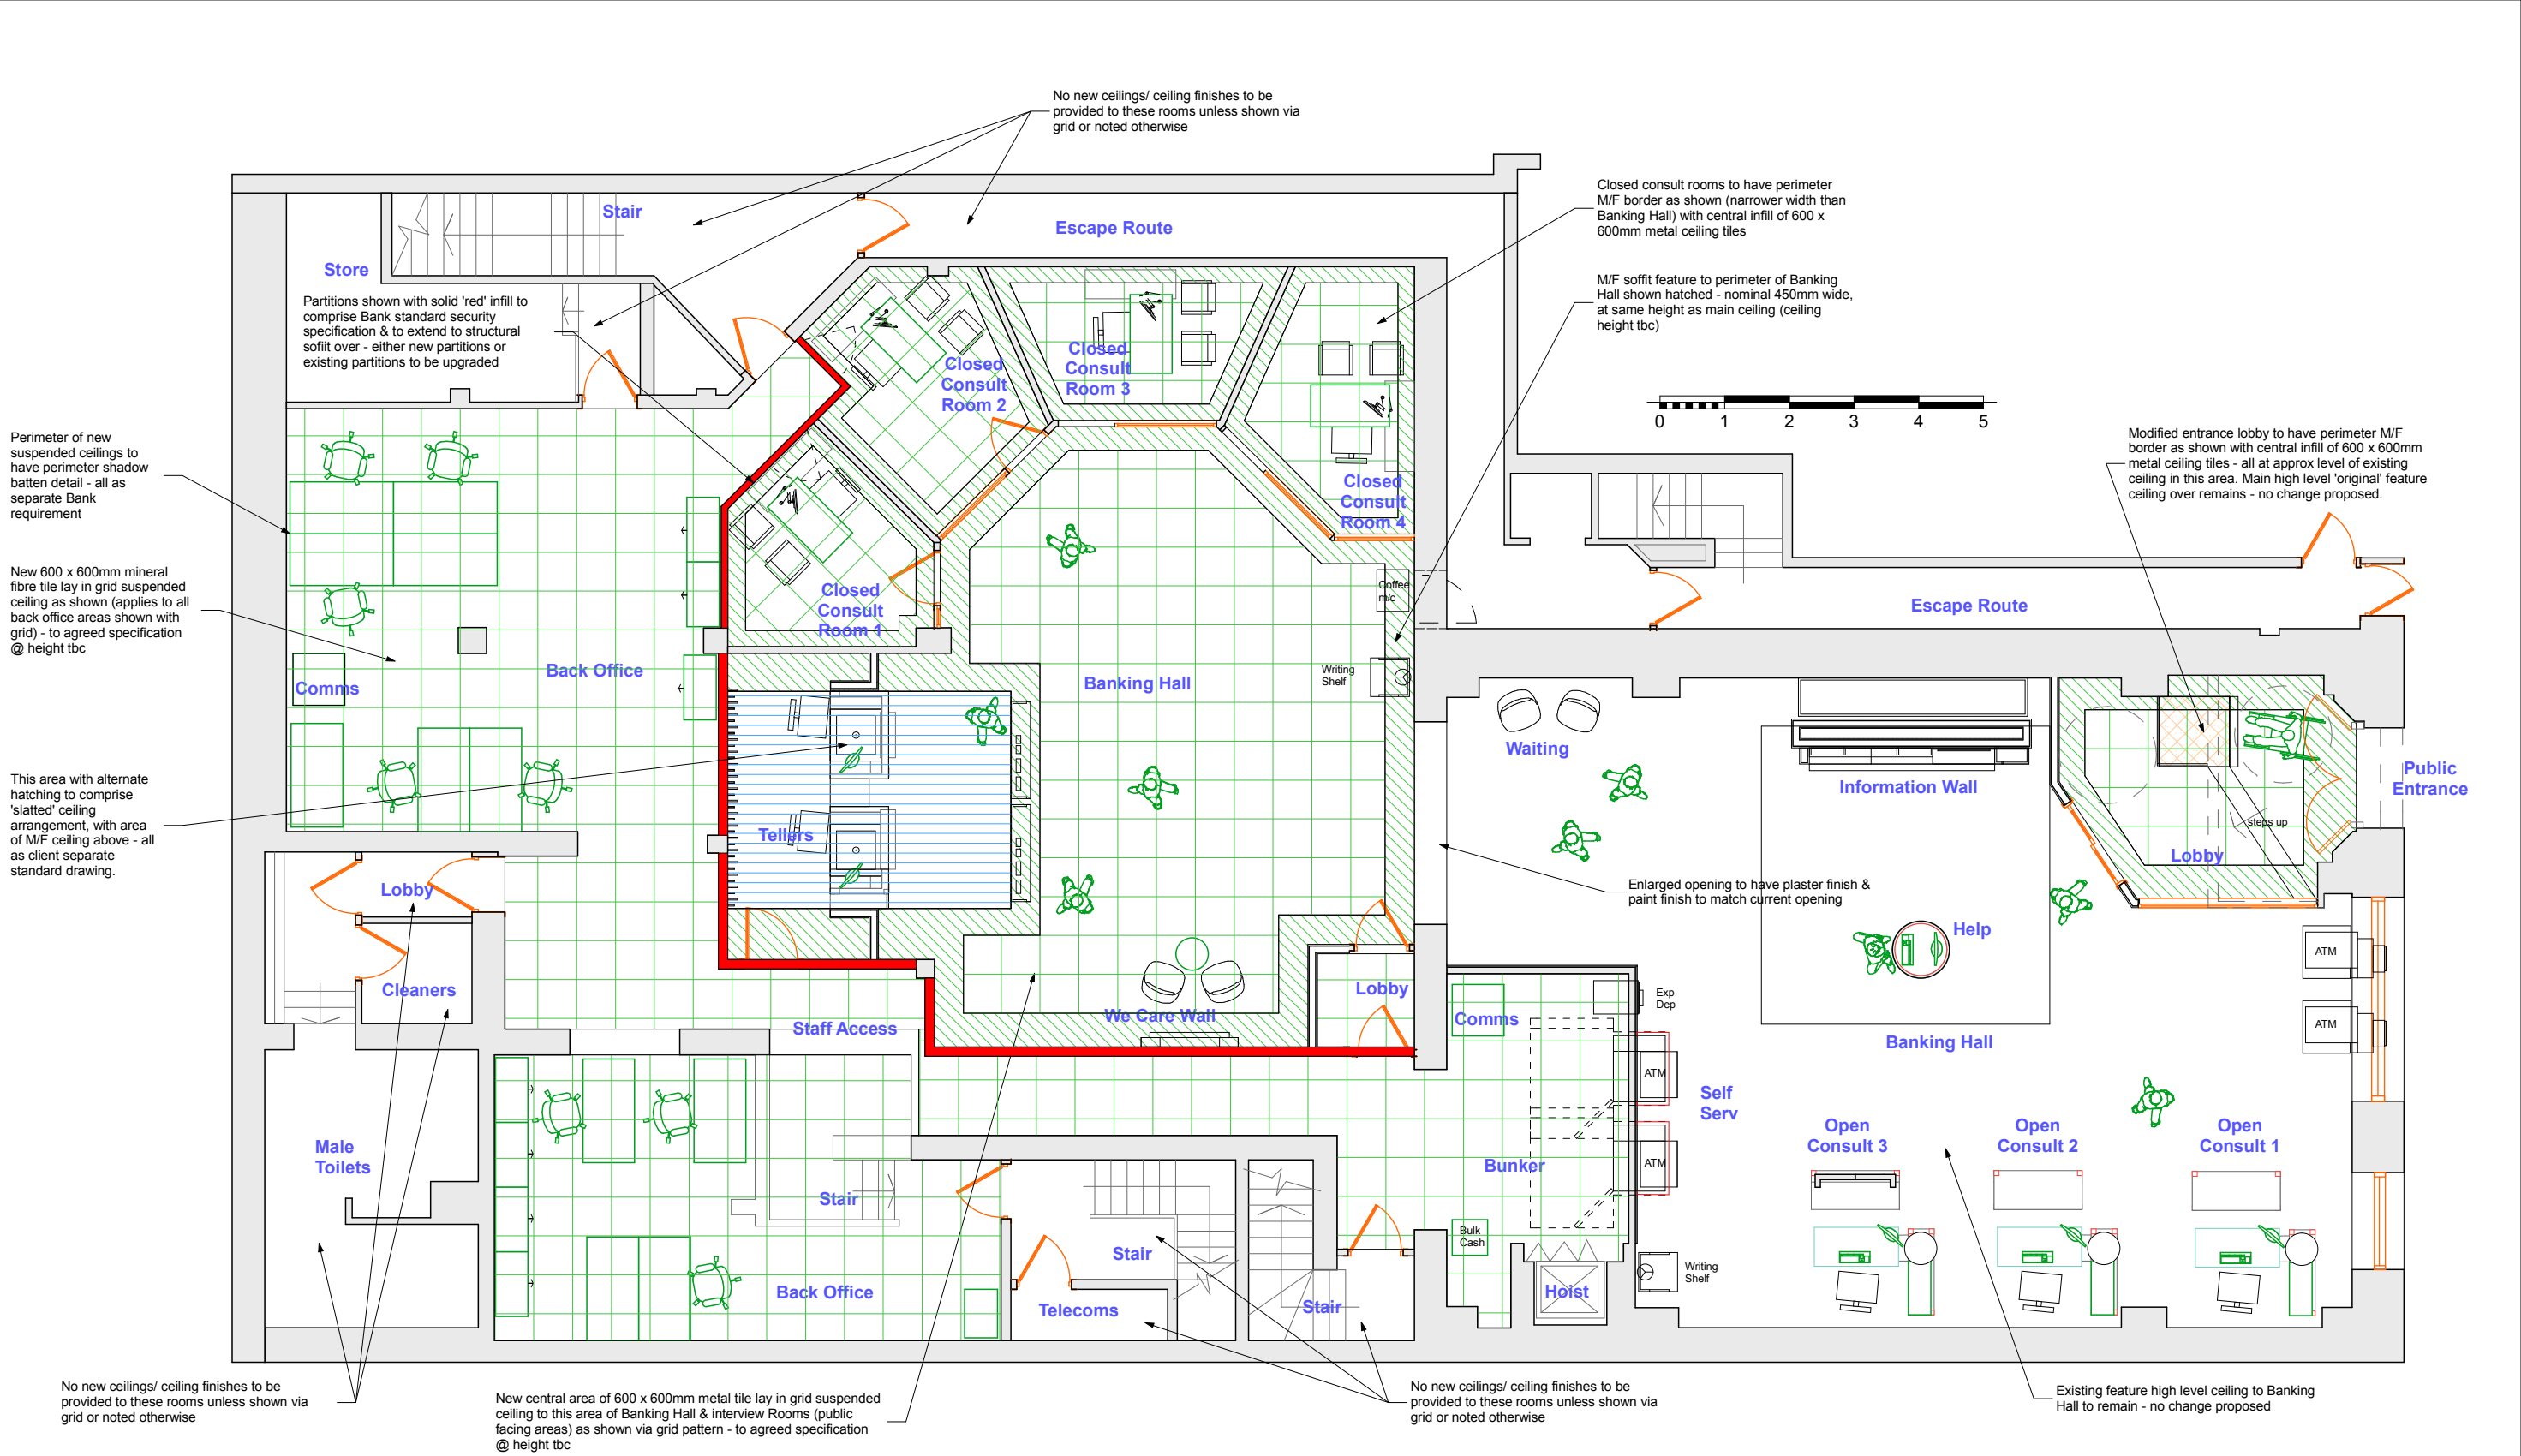

GROUND FLOOR PLAN INDICATING CEILING FINISH PROPOSALS

Title Ceiling Proposals		VAUGHAN MONCKTON ARCHITECTURE LTD 105 LONG ROW, HORSFORTH, LEEDS, LS18 5AT Telephone: 01132 253 530 Fax: 01132 253 722	
Project Proposed Branch Alterations at: 40 New Street, Huddersfield for: Yorkshire Bank		Drawn P.B.	Date May 2016
		Scale 1:100 @ A3	Drawing No. 2058/61/03 Rev. -