


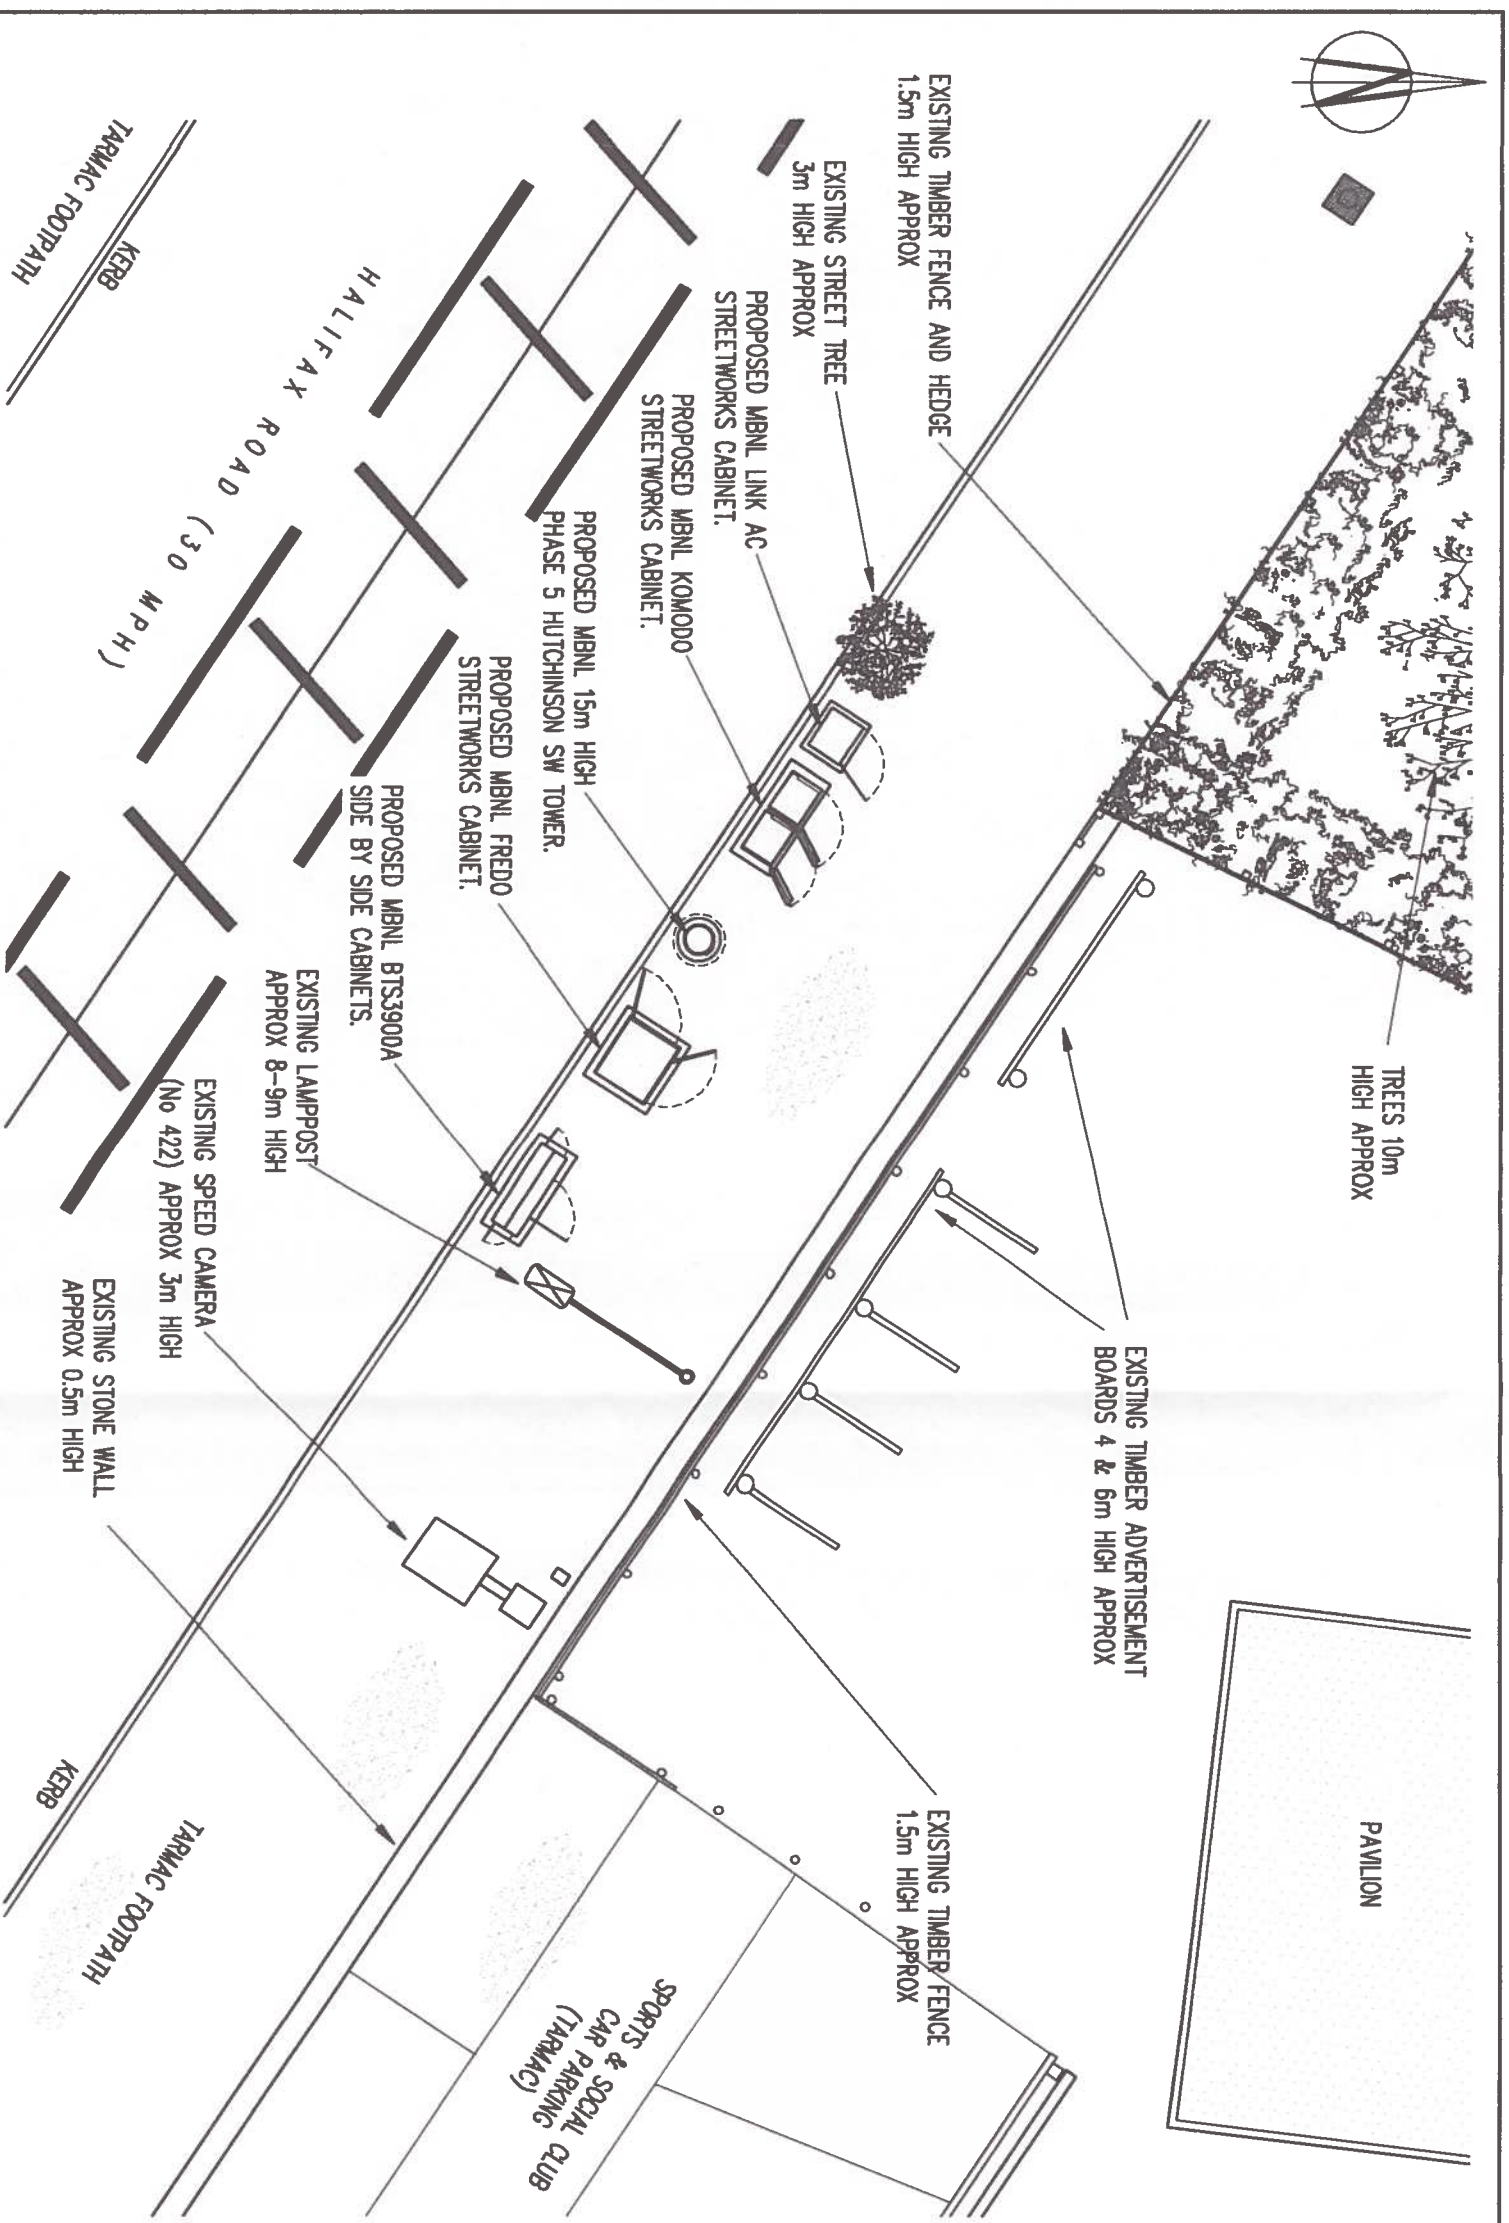

- NOTE**
1. STREETWORKS SAFETY SIGN ATTACHED TO TOWER 2000 BELOW ANTENNA ON ACCESS SIDE
 2. ELECTRICAL SAFETY SIGN TO BE FITTED ON OUTSIDE OF METER CABINET DOOR.
 3. ENTRY SIGN TO BE FITTED ON INSIDE OF STREETWORKS CABINET DOORS.
 4. ANTENNA-1 SAFETY SIGN TO BE FITTED TO BACK OF ANTENNA AND TO TOWER 200 BELOW EACH ANTENNA ON BORE SIGHT

SITE PLAN

0m 1m 5m

SCALE 1:100

A3	REVISED TO SUT MODIFICATION REV R2	05/09/16	TM	PSH
A2	SITE RELOCATED TO SUT TRIAL ONE RESULTS	03/09/16	TM	PSH
A1	PRELIMINARY ISSUE FOR COMMENT	24/03/16	TM	PSH
No.	Revision	Date	By	chkd

6 Anglo Office Park
67 White Lion Road
Amersham
HP7 9FB

Tel: 01494 762 923
Email: info@mbnl.co.uk

WHP Wilkinson Helsby

St. James Business Centre,
Wilderspool Causeway, Warrington
WA4 6PS
Tel: 01925 424100 Fax: 01925 424101
e-mail: info@wilkinson-helsby.co.uk

Site Name & Address:

HALIFAX ROAD DNS
HALIFAX ROAD, DEMSBURY
YORKSHIRE WF17 7BA

Title:

PROPOSED TELECOMMUNICATIONS
STREETWORKS INSTALLATION
SITE LAYOUT

Purpose of Issue:

APPROVAL

Drawing No:

KKS198 - 02

Cell No:

68802

MBNL ID:

KKS198

Issue:	Scale:	AS	SI	AT	CD	PS	SH
A3	TM	Date: 24/03/16	App: SPM	Date: 24/03/16			