


ROOF PLAN

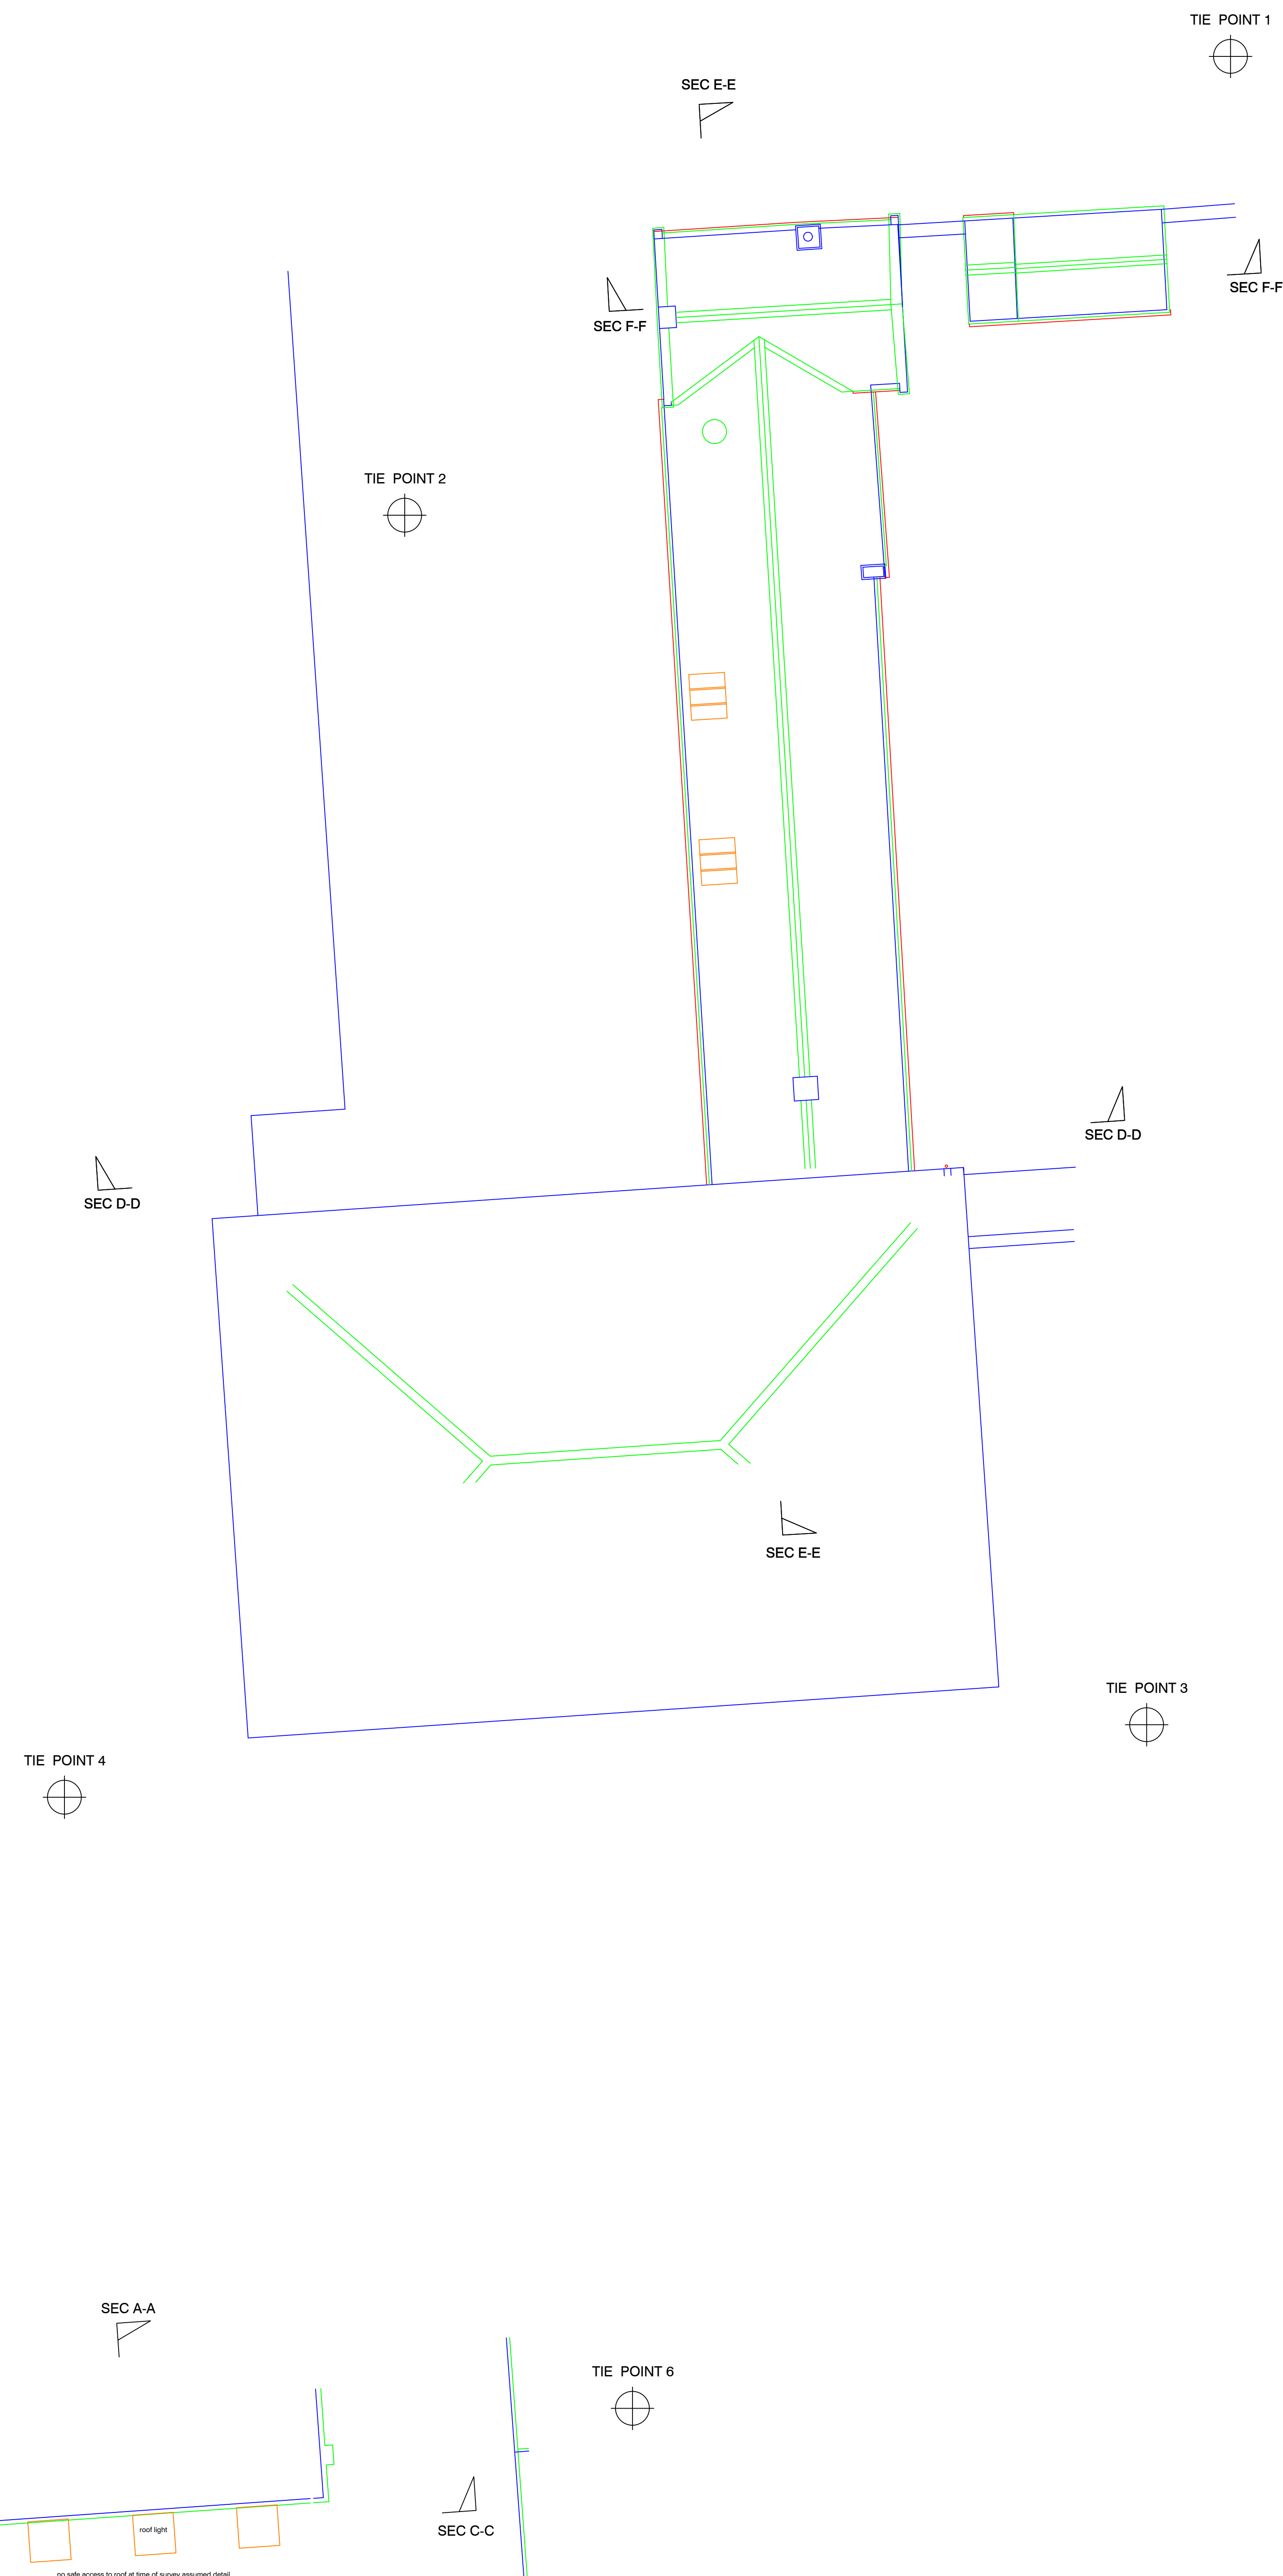

Symbol & Abbreviation Key.

SANITARY (INDICATIVE ONLY)

- WC
- BIDET
- URINAL
- WASH HAND BASIN
- SINK
- SLUICE
- SINK & DRAINER
- SHOWER TRAY
- BATH

ANNOTATION

- ah 1.99 ARCH HEIGHT
- spr 1.78 SPRINGER HEIGHT
- bh 2.43 BEAM HEIGHT TO UNDERSIDE
- us 2.43 UNDERSIDE
- dh 1.99 DOOR HEIGHT
- fc 1.55 FLOOR TO CILL HEIGHT
- ch 0.89 CILL TO HEAD HEIGHT
- cs 2.88 CEILING HEIGHT
- ls 1.99 HIGHEST / LOWEST POINT OF SLOPING CEILING
- ss 2.88 SUSPENDED CEILING HEIGHT


OTHER ABBREVIATIONS

- a/c AIR CONDITIONING UNIT
- bl BOILER
- ck COOKER
- cbd CUPBOARD
- elec ELECTRICS
- fb FLOOR BOARDS (SYMBOL INDICATES BOARD DIRECTION)
- fp FIREPLACE
- pr PIPE RISER
- rad RADIATOR
- rl ROOF LIGHT
- rsd ROLLER SHUTTER DOOR
- tk TANK

Notes.
Levels and coordinates related to archive survey 4687A/B-2D provided by client.

Rev	Details of Revision			Drawn	Date

Surveyed	Drawn	Date	Checked	Date	Approved	Date
JDB/AS	JDB	30/06/2020	GD	30/06/20	GD	30/06/20

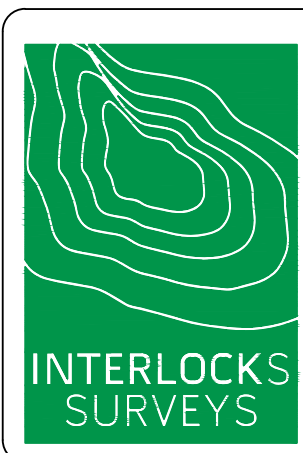

Interlocks Surveys Limited
St. Andrews House
Radford Semele
Leamington Spa
Warwickshire
CV31 1TF

T: 01926 330123
F: 01926 330120
E: info@interlockssurveys.co.uk

Client.

 
KIRKLEES COUNCIL
GROUND FLOOR SOUTH
CIVIC CENTRE 3
MARKET STREET
HUDDERSFIELD HD1 2EY

Title.

MEASURED BUILDING
KING JAMES SCHOOL
42A ST HELENS GATE
HUDDERSFIELD
HD4 6SG

ROOF PLAN

TIE POINT 5




SEC C-C



SEC B-B



 TIE POINT 7




SEC A-A



SEC C-C



 TIE POINT 6




SEC B-B



SEC A-A



 TIE POINT 8



roof light

roof light

no safe access to roof at time of survey assumed detail

Symbol & Abbreviation Key.

SANITARY (INDICATIVE ONLY)

- WC
- BIDET
- URINAL
- WASH HAND BASIN
- SINK
- SLUICE
- SINK & DRAINER
- SHOWER TRAY
- BATH

ANNOTATION

- ah 1.99 ARCH HEIGHT
- spr 1.78 SPRINGER HEIGHT
- bh 2.43 BEAM HEIGHT TO UNDERSIDE
- uh 2.43 UNDERSIDE
- dh 1.99 DOOR HEIGHT
- f-c 1.55 FLOOR TO CILL HEIGHT
- c-h 0.89 CILL TO HEAD HEIGHT
- ch 2.00 CEILING HEIGHT
- hc 1.00 HIGHEST / LOWEST POINT OF SLOPING CEILING
- huc 2.80 SUSPENDED CEILING HEIGHT

OTHER ABBREVIATIONS

- a/c AIR CONDITIONING UNIT
- bl BOILER
- ck COOKER
- cbd CUPBOARD
- elec ELECTRICS
- fb FLOOR BOARDS (SYMBOL INDICATES BOARD DIRECTION)
- fp FIREPLACE
- pr PIPE RISER
- rad RADIATOR
- rl ROOF LIGHT
- rsd ROLLER SHUTTER DOOR
- tk TANK

Notes.

Levels and coordinates related to archive survey 4687A/B-2D provided by client.

Rev	Details of Revision	Drawn	Date

Surveyed	Drawn	Date	Checked	Date	Approved	Date
JDB/AS	JDB	30/06/2020	GD	30/06/20	GD	30/06/20

Interlocks Surveys Limited
St. Andrews House
Radford Semele
Leamington Spa
Warwickshire
CV31 1TF

T: 01926 330123
F: 01926 330120
E: info@interlocksurveys.co.uk

Client.

KIRKLEES COUNCIL
GROUND FLOOR SOUTH
CIVIC CENTRE 3
HUDDERSFIELD HD1 2EY

Title.

MEASURED BUILDING
KING JAMES SCHOOL
42A ST HELENS GATE
HUDDERSFIELD
HD4 6SG

Dwg No. **200330 FP-4** Sheet **2 of 2**

Scale 1:100 A2 Sheet Rev. -