



ELEVATION A (1:20@A1)

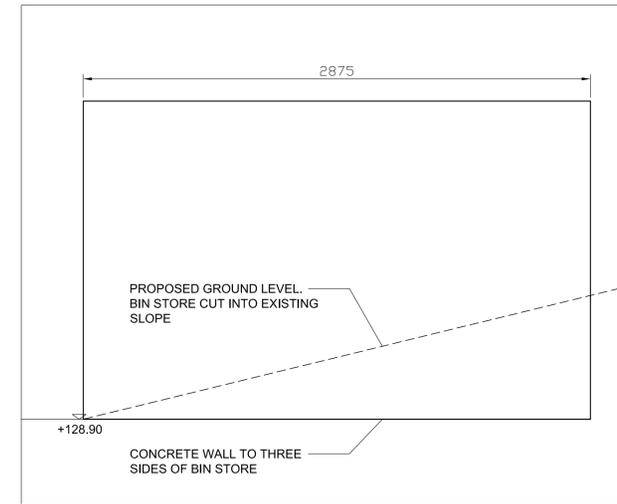

ELEVATION B (1:20@A1)

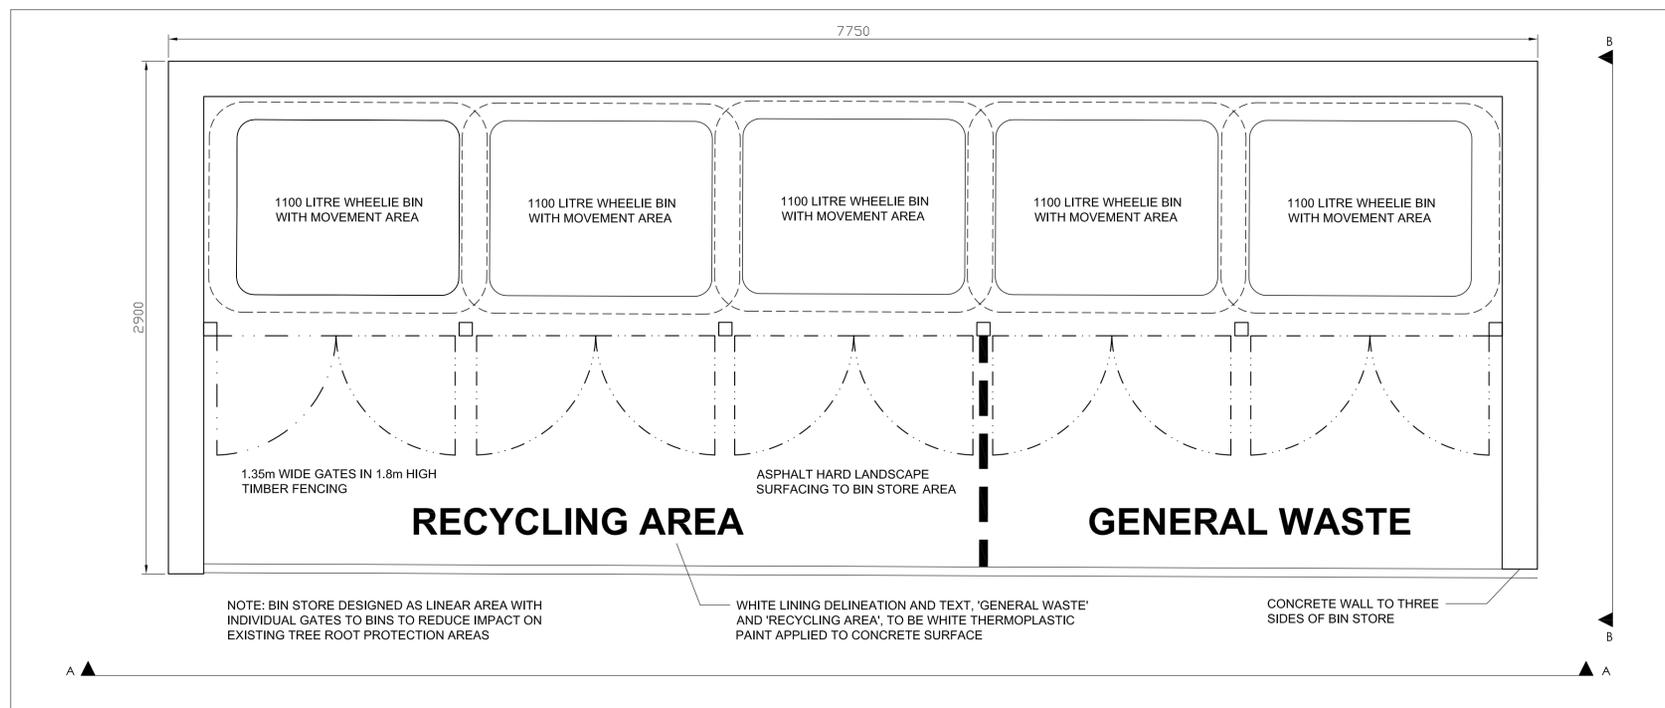

PROPOSED LAYOUT PLAN (1:20@A1)



PROPOSED BIN STORE LOCATION PLAN (1:200@A1)

NOTES:

DO NOT SCALE. Use figured dimensions only. The contractor is requested to check all dimensions before the work is put in hand. Copyright of this drawing belongs solely to Iteriad Ltd ©. This drawing must only be used for the purpose for which it is supplied and its contents must not be reproduced for any purpose without written permission. Areas indicated, or areas calculated from this drawing should be used for valuation purposes or as the basis for development contracts. Iteriad Ltd is a limited liability company registered in England and Wales. Number 7966573

KEY PLAN

TO BE READ IN CONJUNCTION WITH:

- SRP1088-ITR-XX-00-DR-L-0001 - Landscape Masterplan
- SRP1088-ITR-XX-00-DR-L-0002 - Landscape Strategy Plan
- SRP1088-ITR-XX-00-DR-L-0003 - External Access and Security Plan
- SRP1088-ITR-XX-00-DR-L-0101 - Landscape GA 1 of 2
- SRP1088-ITR-XX-00-DR-L-0102 - Landscape GA 2 of 2
- SRP1088-ITR-XX-00-DR-L-0201 - Landscape Levels 1 of 2
- SRP1088-ITR-XX-00-DR-L-0202 - Landscape Levels 2 of 2
- SRP1088-ITR-XX-00-M3-L-8001 - Landscape Revit Model
- SRP1088-ITR-VV-XX-SP-L-1000 - Outline Hard and Soft Landscape Material Specification

P01	FIRST ISSUE - PLANNING	MS	KH	03.07.23
REV	DETAILS	DRAWN BY	CHECKED BY	CHECKED DATE

DRAWING RECORD

STATUS
FOR REVIEW, COMMENT AND APPROVAL

CLIENT

MASTERPLANNERS/LANDSCAPE ARCHITECTS
(iteriad)
Studio
2 Cragwood Cottages,
Eckington,
Windsore,
Gumfries
LA23 1LQ
T: (+44) 15394 43018
E: studio@iteriad.com
W: www.iteriad.com

PROJECT TITLE
St Peters Primary

DRAWING TITLE
Proposed Bin Store Details

SCALE	DRAWN BY	DATE
Varies@A1	MS	JUL '23

JOB/DRAWING NUMBER	REVISION
SRP1088-ITR-XX-00-DR-L-0312	P01