


**Notes**

Do not scale from drawing, use figured dimensions only.  
 All dimensions must be checked and verified on site prior to commencement of work and architect to be notified of any discrepancies.  
 This drawing is intended to permit overall scheme proposals only and cannot be used for construction purposes without further information.

Rev	Drawn	Checked	Date

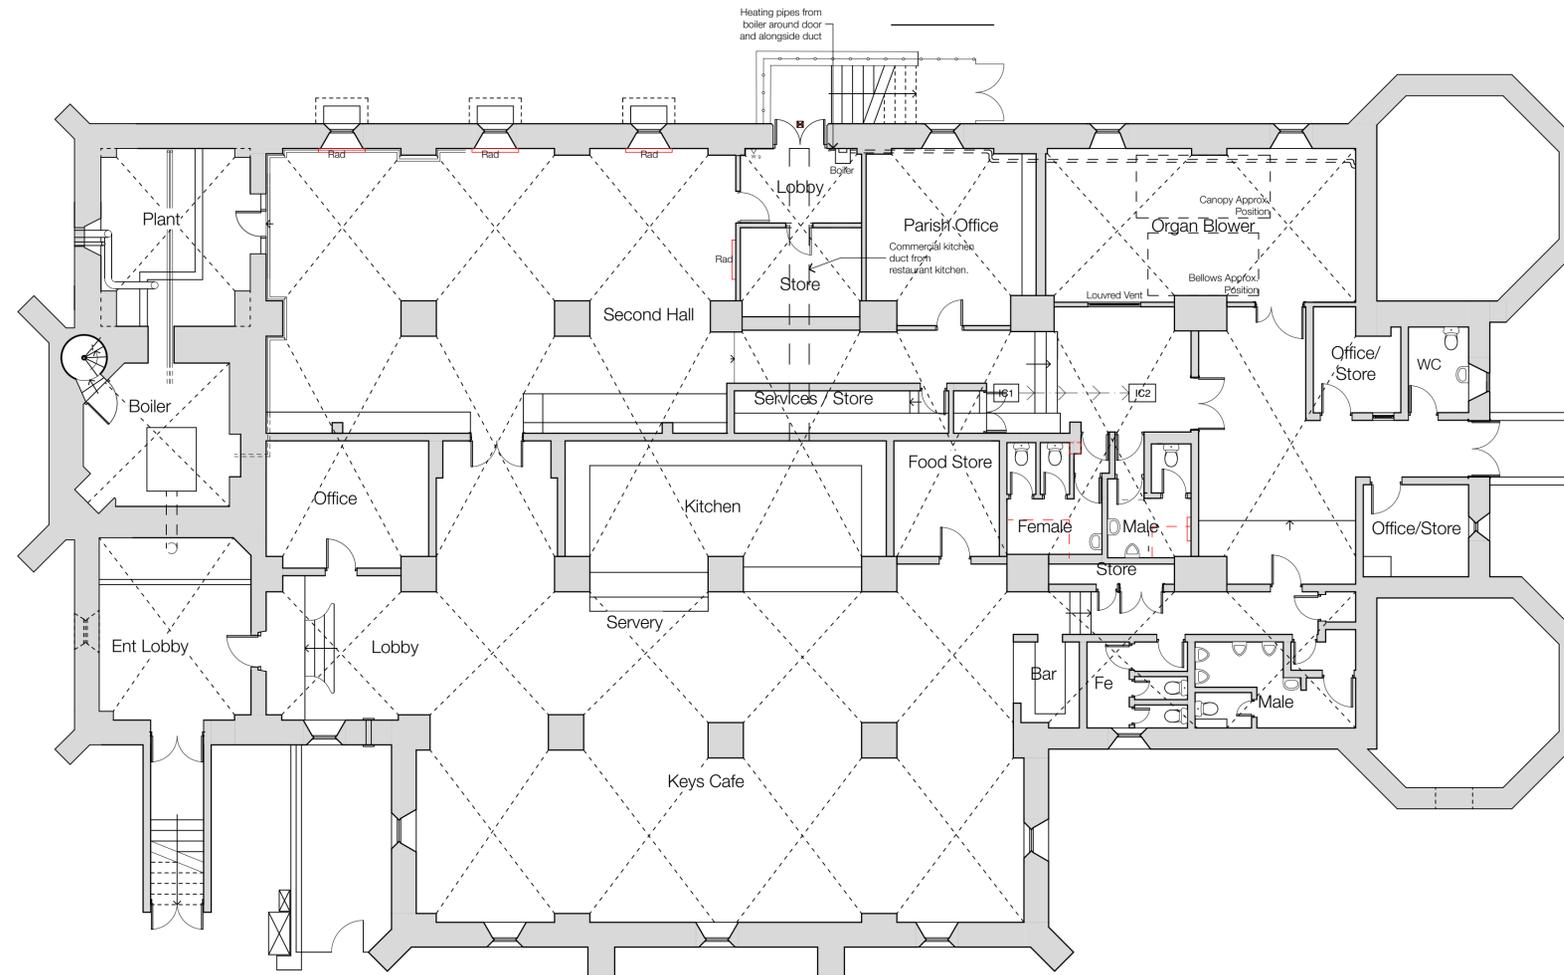

Proposed Lower Ground Floor Plan 1:100

Job Title Crypt Kitchen Proposals, St Peter's Church, Huddersfield	
Client PCC of Huddersfield Parish Church	
Status Preliminary	Company AD
Drawing Existing Lower Ground Floor Plan	Scale @ A1 1:100
Date June 2021	Drawn KMA
Drawing No. 3404 (0-) 01	Revision

**ONE17**  
 ARCHITECTS & INTERIOR DESIGNERS

The Dyehouse, Armitage Bridge  
 Huddersfield, West Yorkshire HD4 7PD  
 T 01484 668 000 F 01484 668 001  
 E solutions@one17design.com

**ONE17DESIGN.COM**