
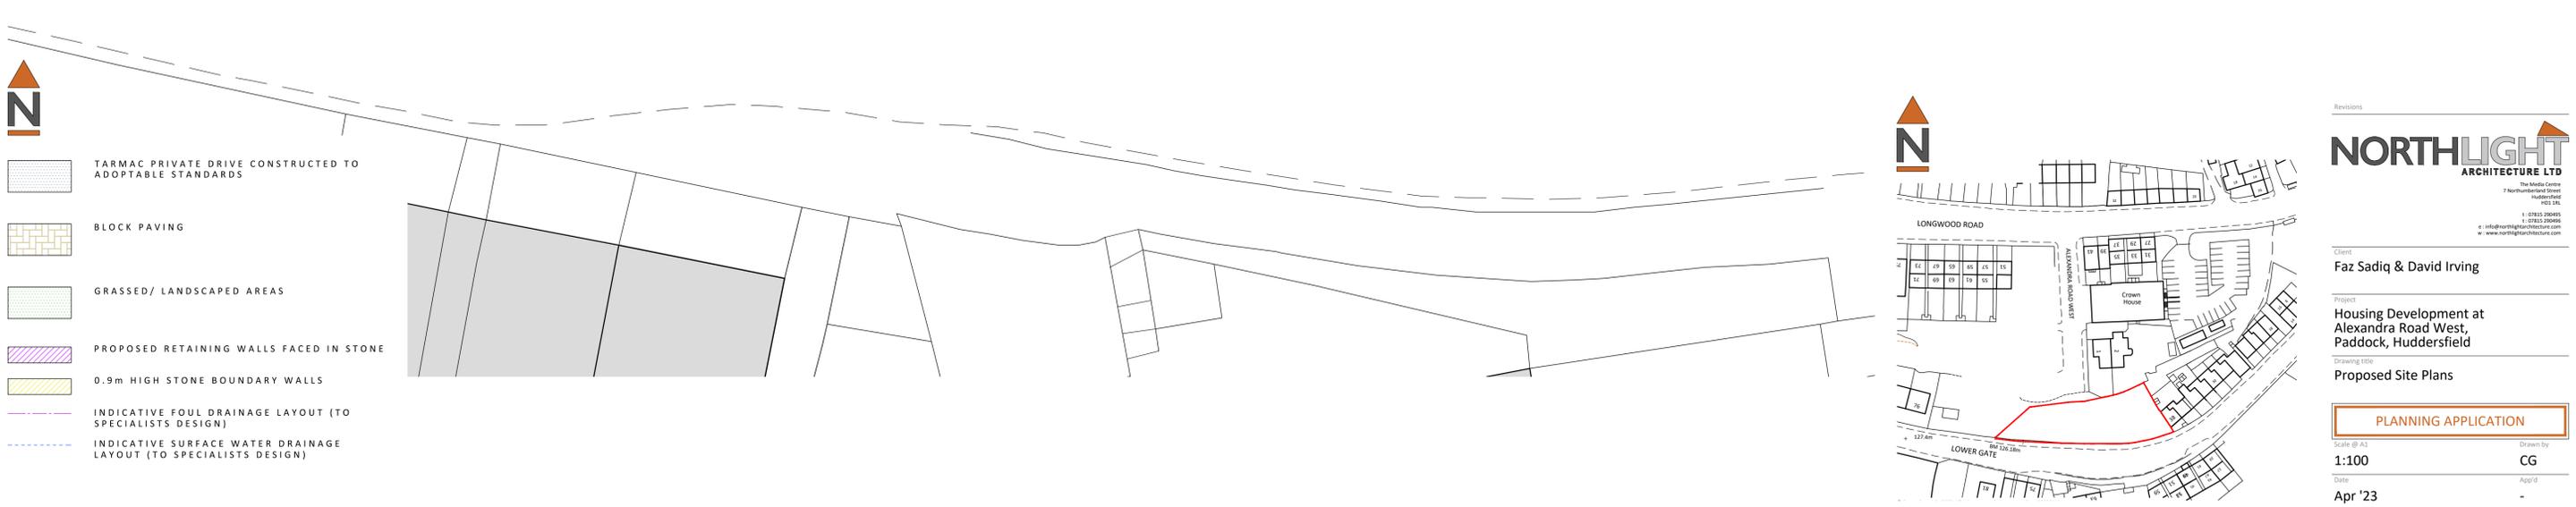


Do not scale from this drawing. Northlight Architecture Ltd must be notified immediately should any discrepancies be found. The contractor must check all dimensions on site before construction or manufacture of materials. This drawing or any portion of it may not be reproduced without the consent of Northlight Architecture Ltd.

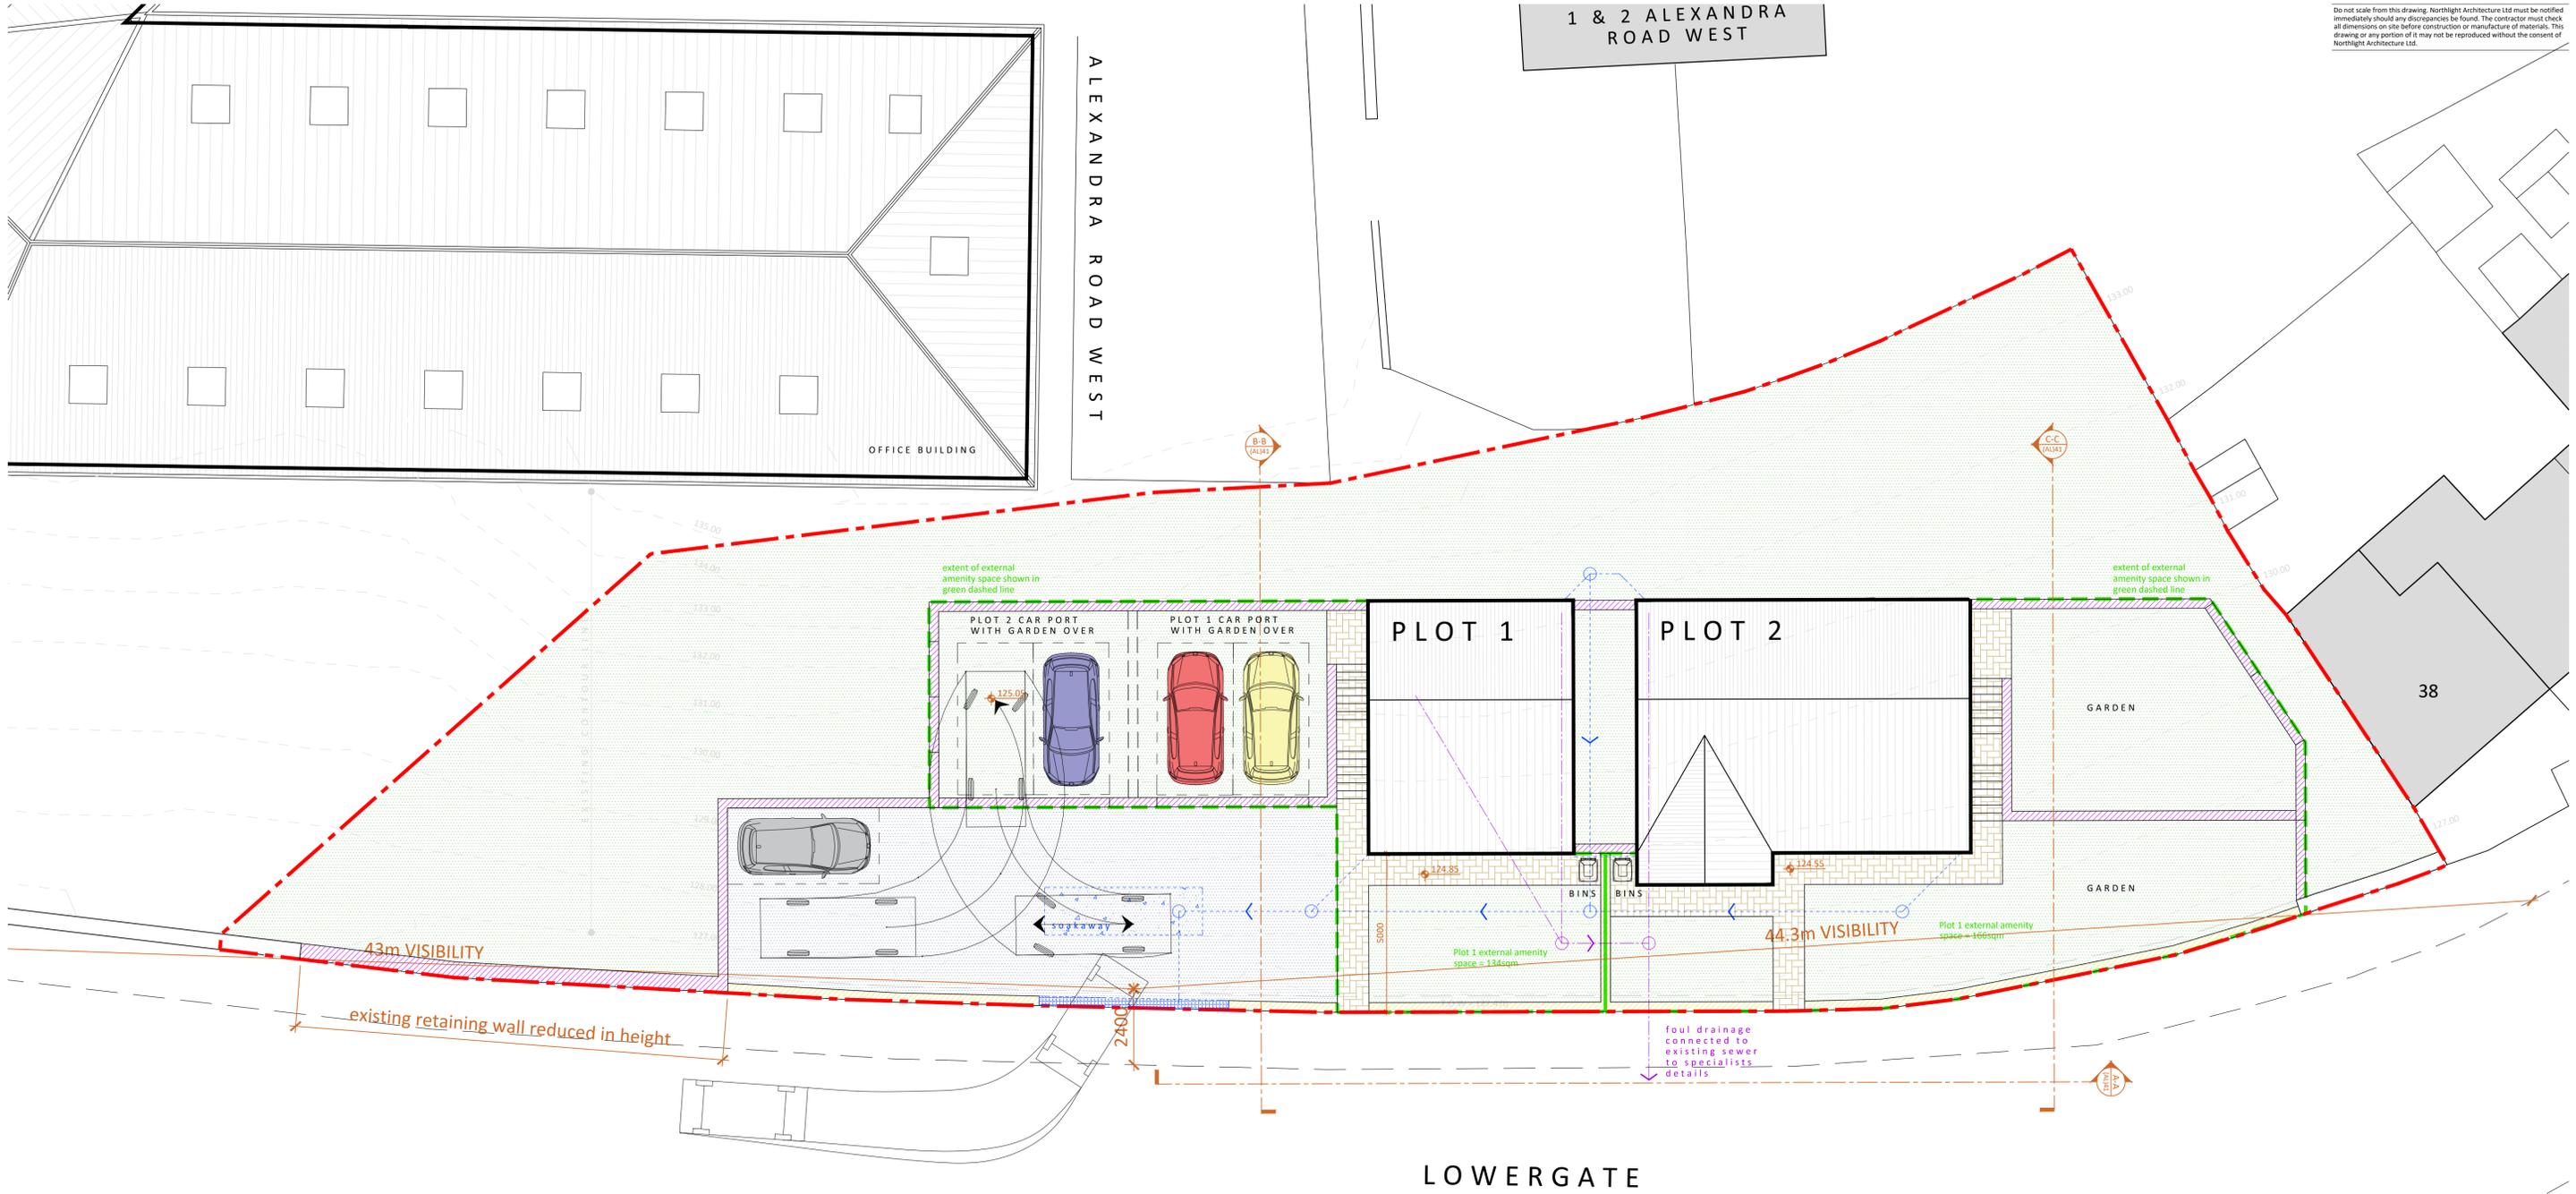

1 PROPOSED SITE PLAN
SCALE 1:100

2 SITE LOCATION PLAN
SCALE 1:1250

- TARMAC PRIVATE DRIVE CONSTRUCTED TO ADOPTABLE STANDARDS
- BLOCK PAVING
- GRASSED/ LANDSCAPED AREAS
- PROPOSED RETAINING WALLS FACED IN STONE
- 0.9m HIGH STONE BOUNDARY WALLS
- INDICATIVE FOUL DRAINAGE LAYOUT (TO SPECIALISTS DESIGN)
- INDICATIVE SURFACE WATER DRAINAGE LAYOUT (TO SPECIALISTS DESIGN)

Revisions

NORTHLIGHT ARCHITECTURE LTD
The Media Centre
7 Northumbria Road
Huddersfield
HD1 1NQ
t: 01484 250445
f: 01484 250446
e: info@northlightarchitecture.com
www.northlightarchitecture.com

Client
Faz Sadiq & David Irving

Project
Housing Development at Alexandra Road West, Paddock, Huddersfield

Drawing Title
Proposed Site Plans

PLANNING APPLICATION

Scale: @ A1	Drawn by
1:100	CG
Date	App'd
Apr '23	-
Drawing no	Rev
20.1127/(AL)40	-

© Northlight Architecture Ltd 2020