



EXTERNAL LIGHTING CONTROLS - NTS

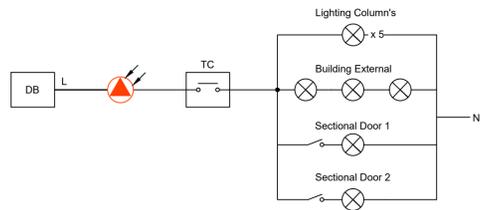

LEGEND

-  AAZLED200/ASY  
ANSELL Aztec 200W LED Flood Light
-  KINGFISHER 6CT76 TUBULAR  
COLUMN 6MTR CW STM169 BRACKET
-  AAZLED50/ASY  
ANSELL Aztec 50W LED Flood Light
-  FUSION PHOTOCELL DL4061
-  1G  
IP66 MASTERSEAL LIGHT SWITCH

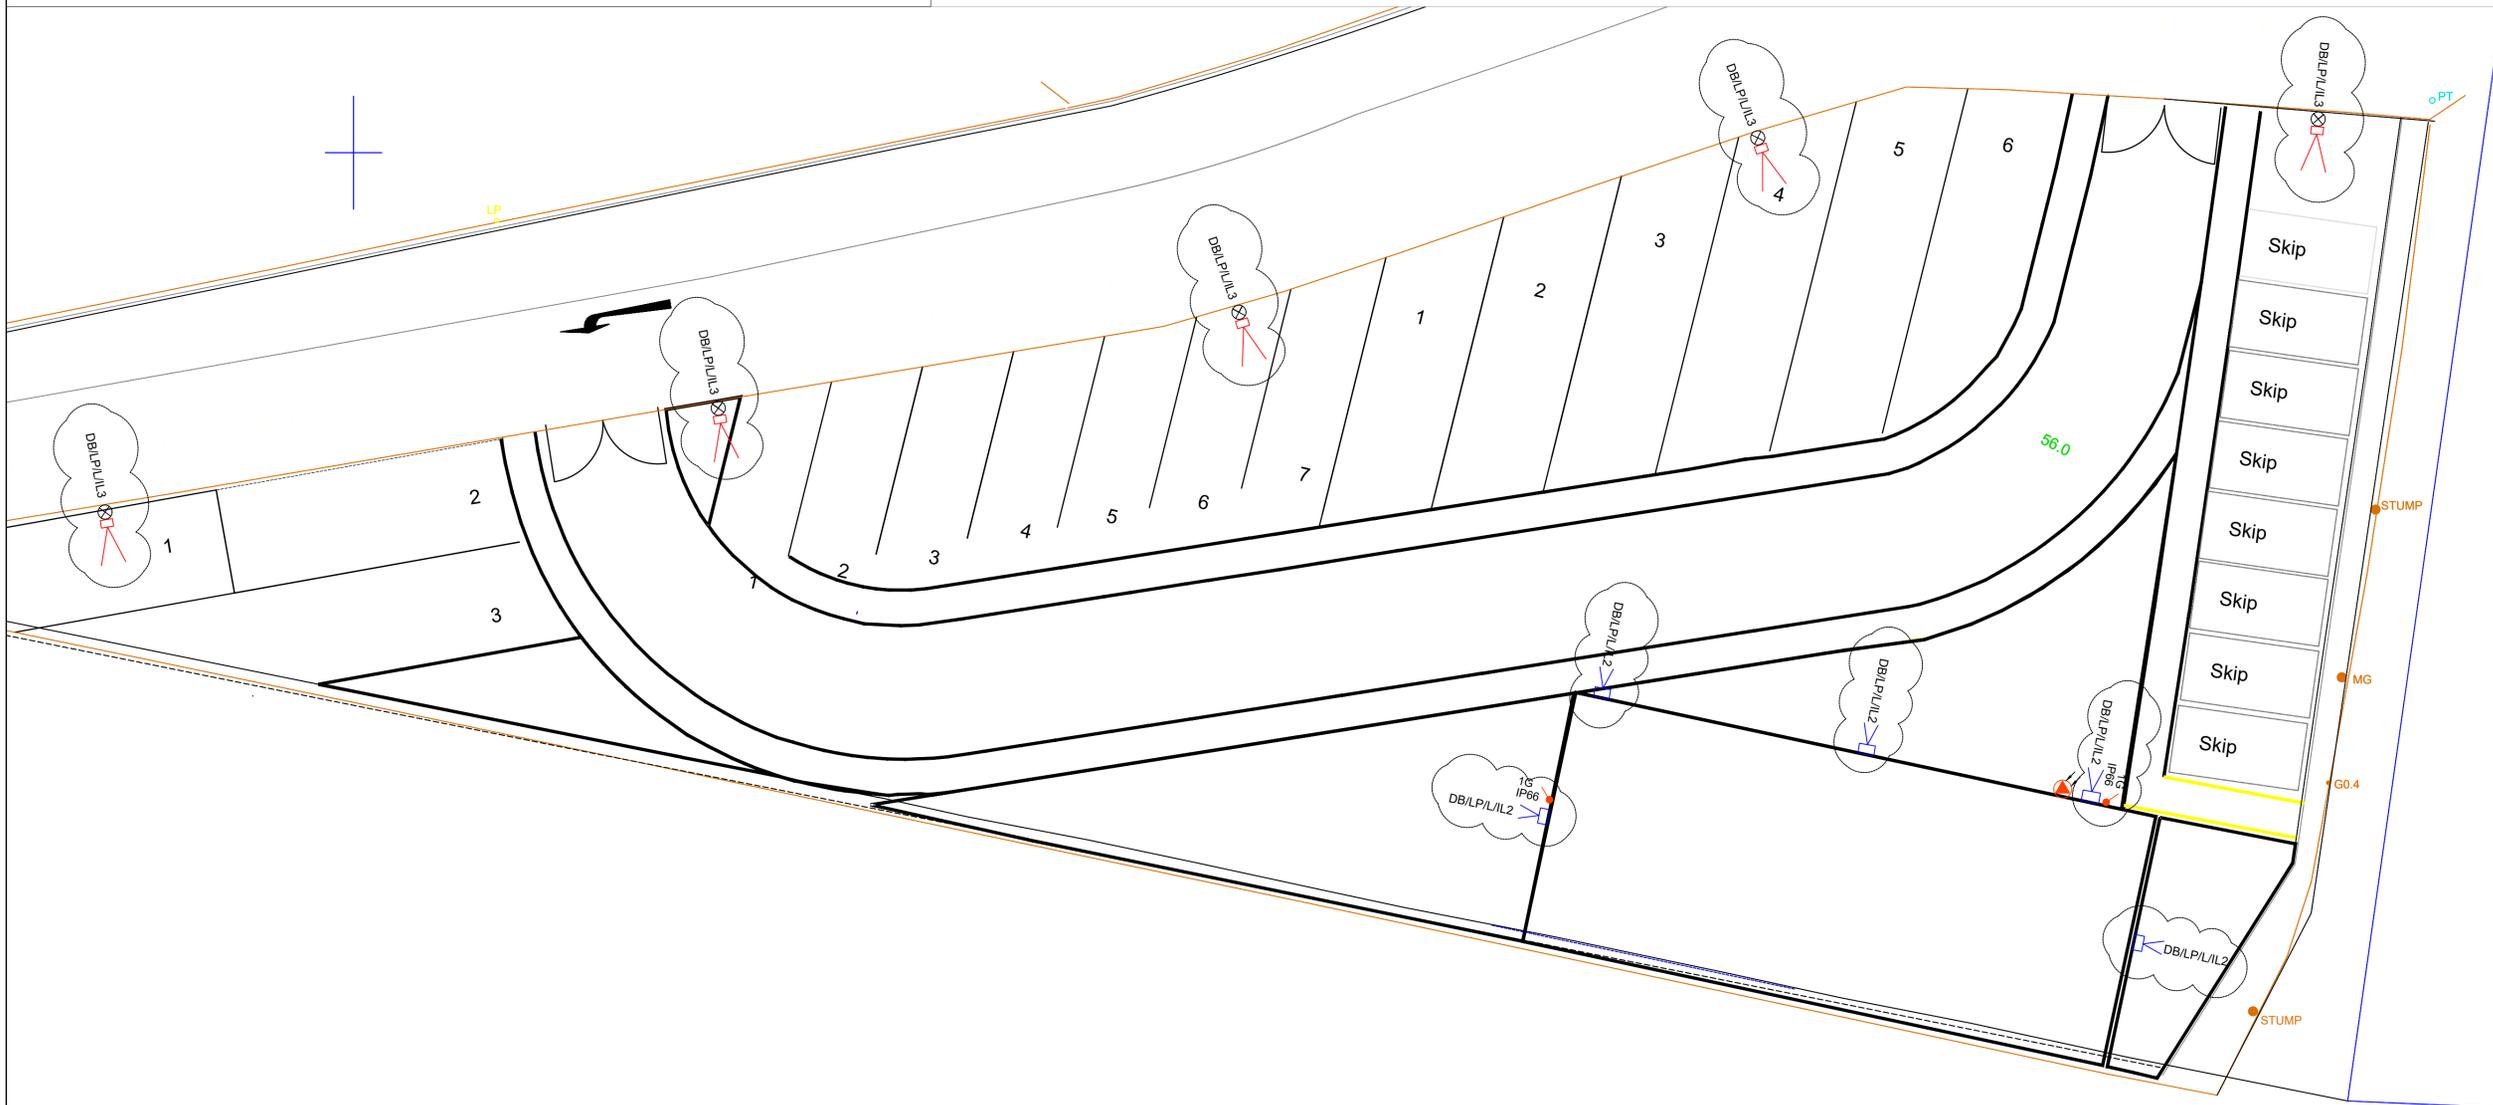

FOR COMMENT



Hawley Building Services Ltd  
2nd Floor, Parkview House,  
Woodvale Road, Brighouse  
West Yorkshire  
HD6 4AB

Rev	Date	Comment
P01	27/02/23	Issued for comment
P02	06/03/23	Updated with new devices
P03	09/03/23	Updated product codes
P04	20/03/23	Added Circuit References
P05	21/03/23	Updated as per Kirklees Council Comments

Contact Details:  
support@hbsmep.co.uk

Project Name:  
Beck Lane Depot

Drawing Title:  
External Lighting Layout

Date:  
27/02/2023

Project No:  
PRO597

Scale & Drawing Size:  
1:125

Drawing No:  
HBS-E001