

All drawings are to be read in conjunction with specification and all other drawings that relate to this house type.


All notes refer to all drawings of this house type.

Electrical layout is schematic - Completed installation to comply with I.E.E regs & all relevant codes of practices.

Electrical components fit to comply with approved part M.

Do not scale from this drawing. Brightline Design to be notified of any discrepancies

Verify relevant dimensions on site before commencing work or preparation shop drawings. This Drawing is copyright.

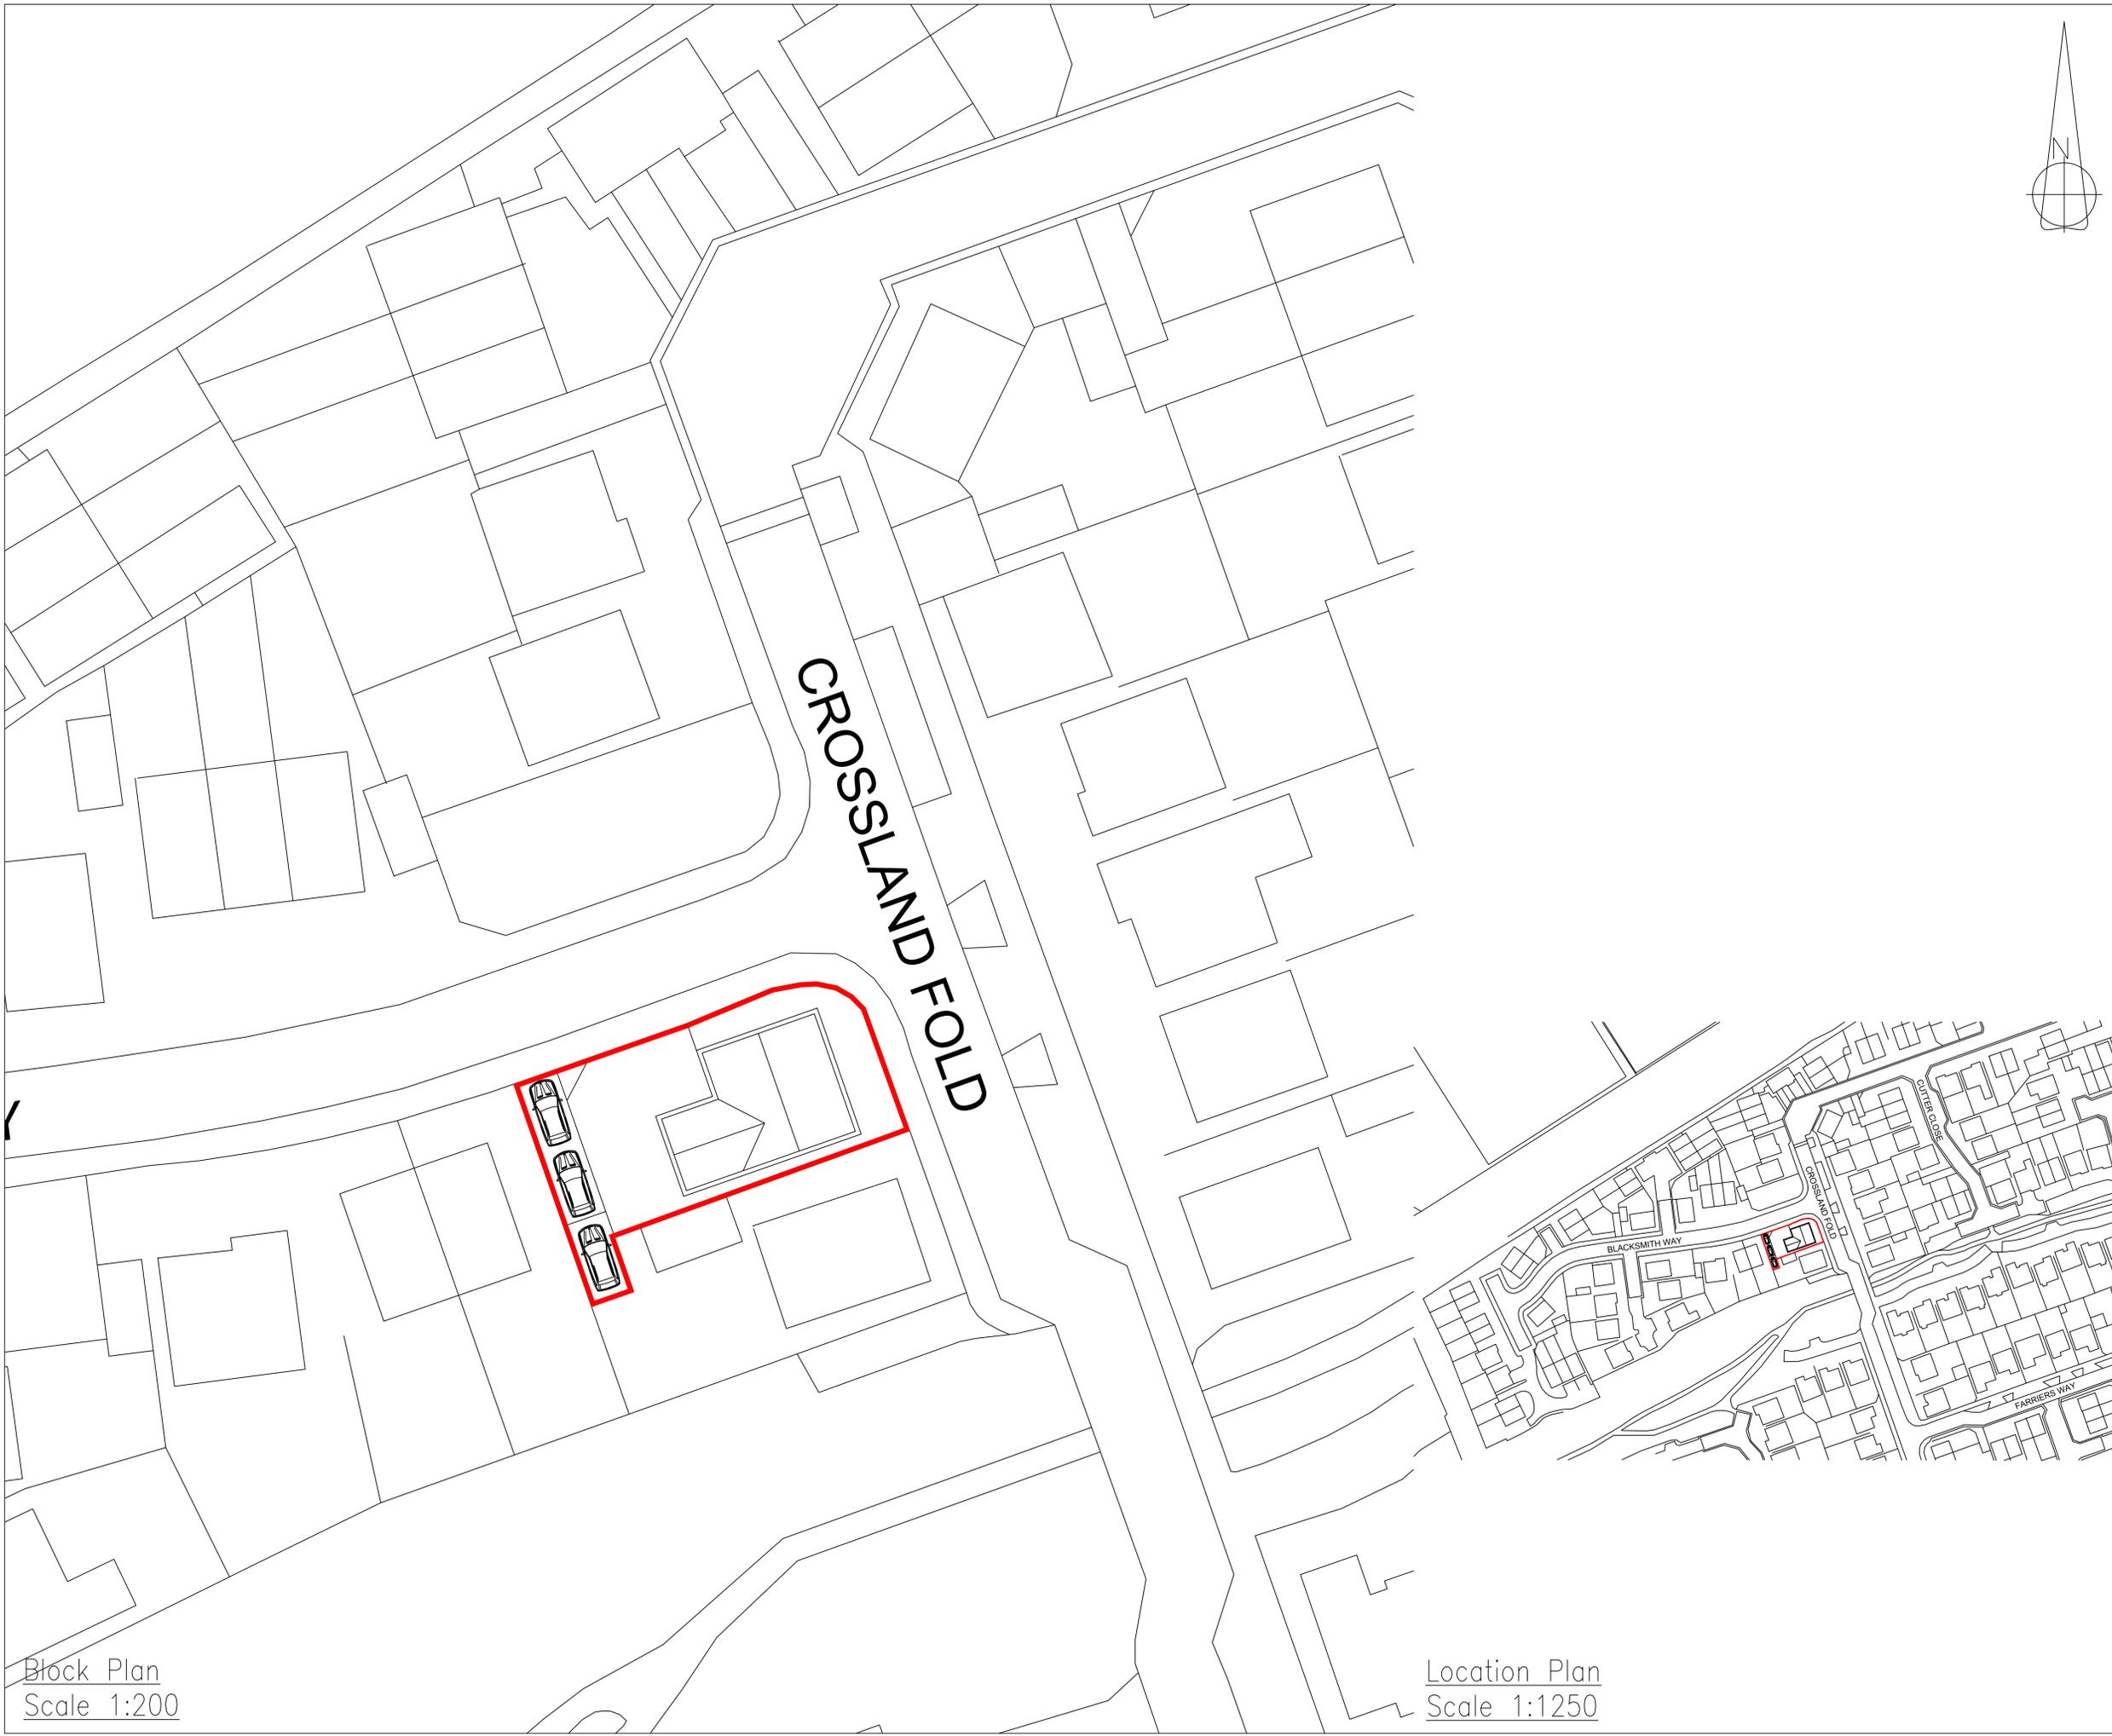

CROSSLAND FOLD

Block Plan
Scale 1:200

Location Plan
Scale 1:1250

BRIGHTLINE DESIGN

ARCHITECTURAL SERVICES

5 Sunnysbank Road, Greetland, Halifax. HX4 8JP
Telephone - 07590 677 717/
Email - info@brightlinedesign.co.uk
Web: www.brightlinedesign.co.uk

Client
Mr and Mrs Beaumont

Project
27, Crosland Fold, Lindley,
Huddersfield, HD3 3QH

Drawing
Block Plan & Location Plan.

Scale 1:200/1250@A1	Date MAY23	Drawn R.FOSTER
Drawing No. 23-013-03	Checked by J.WHIP	Revision A



Barn Conversion • Loft Conversion • Basement Conversion
New Build • Extension
Refurbishments • Domestic Work