
 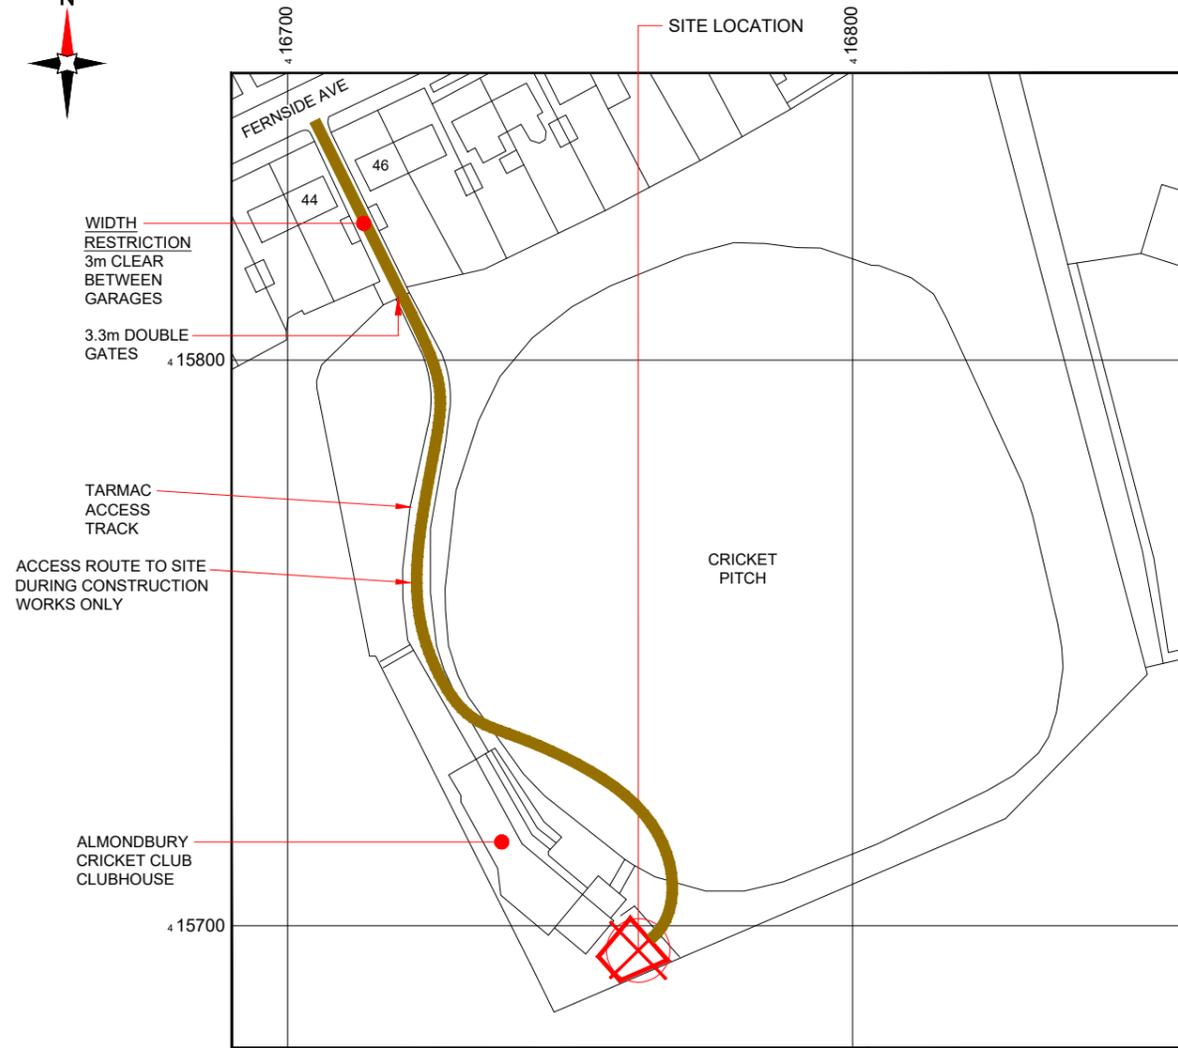


Reproduced by permission of Ordnance Survey on behalf of the Controller of Her Majesty's Stationery Office All rights reserved. © Crown Copyright licence no. 0100031673

 
SITE AREA PLAN
Scale 1:50,000



Reproduced by permission of Ordnance Survey on behalf of the Controller of Her Majesty's Stationery Office All rights reserved. © Crown Copyright licence no. 0100031673

NGR E: 416760 N: 415695

SITE LOCATION PLAN
Scale 1:1250



SITE PHOTOGRAPH



GOOGLE MAPS QR CODE

 
GOOGLE MAP - [Hyperlink to map of the site](#)

GOOGLE STREETVIEW - [Hyperlink to streetview of the site](#)

NOTES:

1. ALL DIMENSIONS IN MM UNLESS OTHERWISE NOTED.

From the M62 junction 23 take the A640 to Huddersfield. At the junction with the A62 turn right onto the A62. Continue on the A62 until the roundabout with the A629. Turn right onto the A629. After 990m turn right onto Almondbury Bank. After 960m turn left onto Fernside Avenue. The cricket club entrance is on the right hand side after 340m. The site is located at the far end of the clubhouse.



Master:	MBNL / EE / H3G:	Project:	Purpose of Issue:	Issue:
M001	MBNL	NTQ	Planning	A
Date:	23/03/23	Revision / Upgrade Description:		
Drawn:	J. BOOTE	First Issue		
Checked:	J. STOCKDALE			
Approved:	J. STOCKDALE			

Hutchison 3G UK Limited
Star House, 20 Grenfell Road
Maidenhead, SL6 1EH
Tel: 01628 765 000
Fax: 01628 765 001

Hatfield Business Park
Hatfield
Hertfordshire
AL10 9BW
Tel: 01707 315000
Fax: 01707 319001

Mobile Broadband Network Limited
Sixth Floor, Thames Tower, Station Road, Reading, RG1 1LX

Design Consultant & Principal Contractor:

WHP Telecoms
Unit 1 Maple Park,
Low Fields Avenue, Leeds
LS12 6HH
Tel: 01133023550
e-mail: info@whptelecoms.com

Site Name: **ALMONDBURY CRICKET CLUB**

Site ID: **1700355**

Address: **ALMONDBURY CRICKET CLUB,
FERNSIDE AVENUE,
ALMONDBURY, HUDDERSFIELD,
WEST YORKSHIRE,
HD5 8PF**

Title: **002 SITE LOCATION PLAN**

Project: **NTQ**

Purpose of Issue: **GENERAL ARRANGEMENT**

EE Cell ID:	MBNL Cell ID:	3UK Cell ID:
96739	KKS251	-

Master Drawing No:	Issue:
1700355_KKS251_96739_M001	A


100mm
50mm
10mm



Asset Reference	Asset Description:	Asset Status:	Antenna / Dish / MHA / RRU / Equipment Access Description:	Asset Reference	Asset Description:	Asset Status:	Antenna / Dish / MHA / RRU / Equipment Access Description:
A1-A2	Antenna	Proposed	Rigger access only	AMPA1-6	MHA	Proposed	Rigger access only
B1-B2	Antenna	Proposed	Rigger access only	AMPB1-6	MHA	Proposed	Rigger access only
C1-C2	Antenna	Proposed	Rigger access only	AMPC1-6	MHA	Proposed	Rigger access only
CAB1-5	Cabinet	Proposed	Unrestricted access	BB1-8	BOB Bottom	Proposed	Unrestricted access
TD1	Dish	Proposed	Rigger access only	AR1-18	Active Router	Proposed	Rigger access only
TD2	Dish	Proposed	Rigger access only	PR1-18	Passive Router	Proposed	Unrestricted access
TD3	Dish	Proposed	Rigger access only	RRU BTM 1-24	RRU Ground Level	Proposed	Unrestricted access
TD4	Dish	Proposed	Rigger access only				


NOTES:
1. ALL DIMENSIONS IN MM UNLESS OTHERWISE NOTED.

SHARED CONFIGURATION SITE	
RF CONFIG	H3b

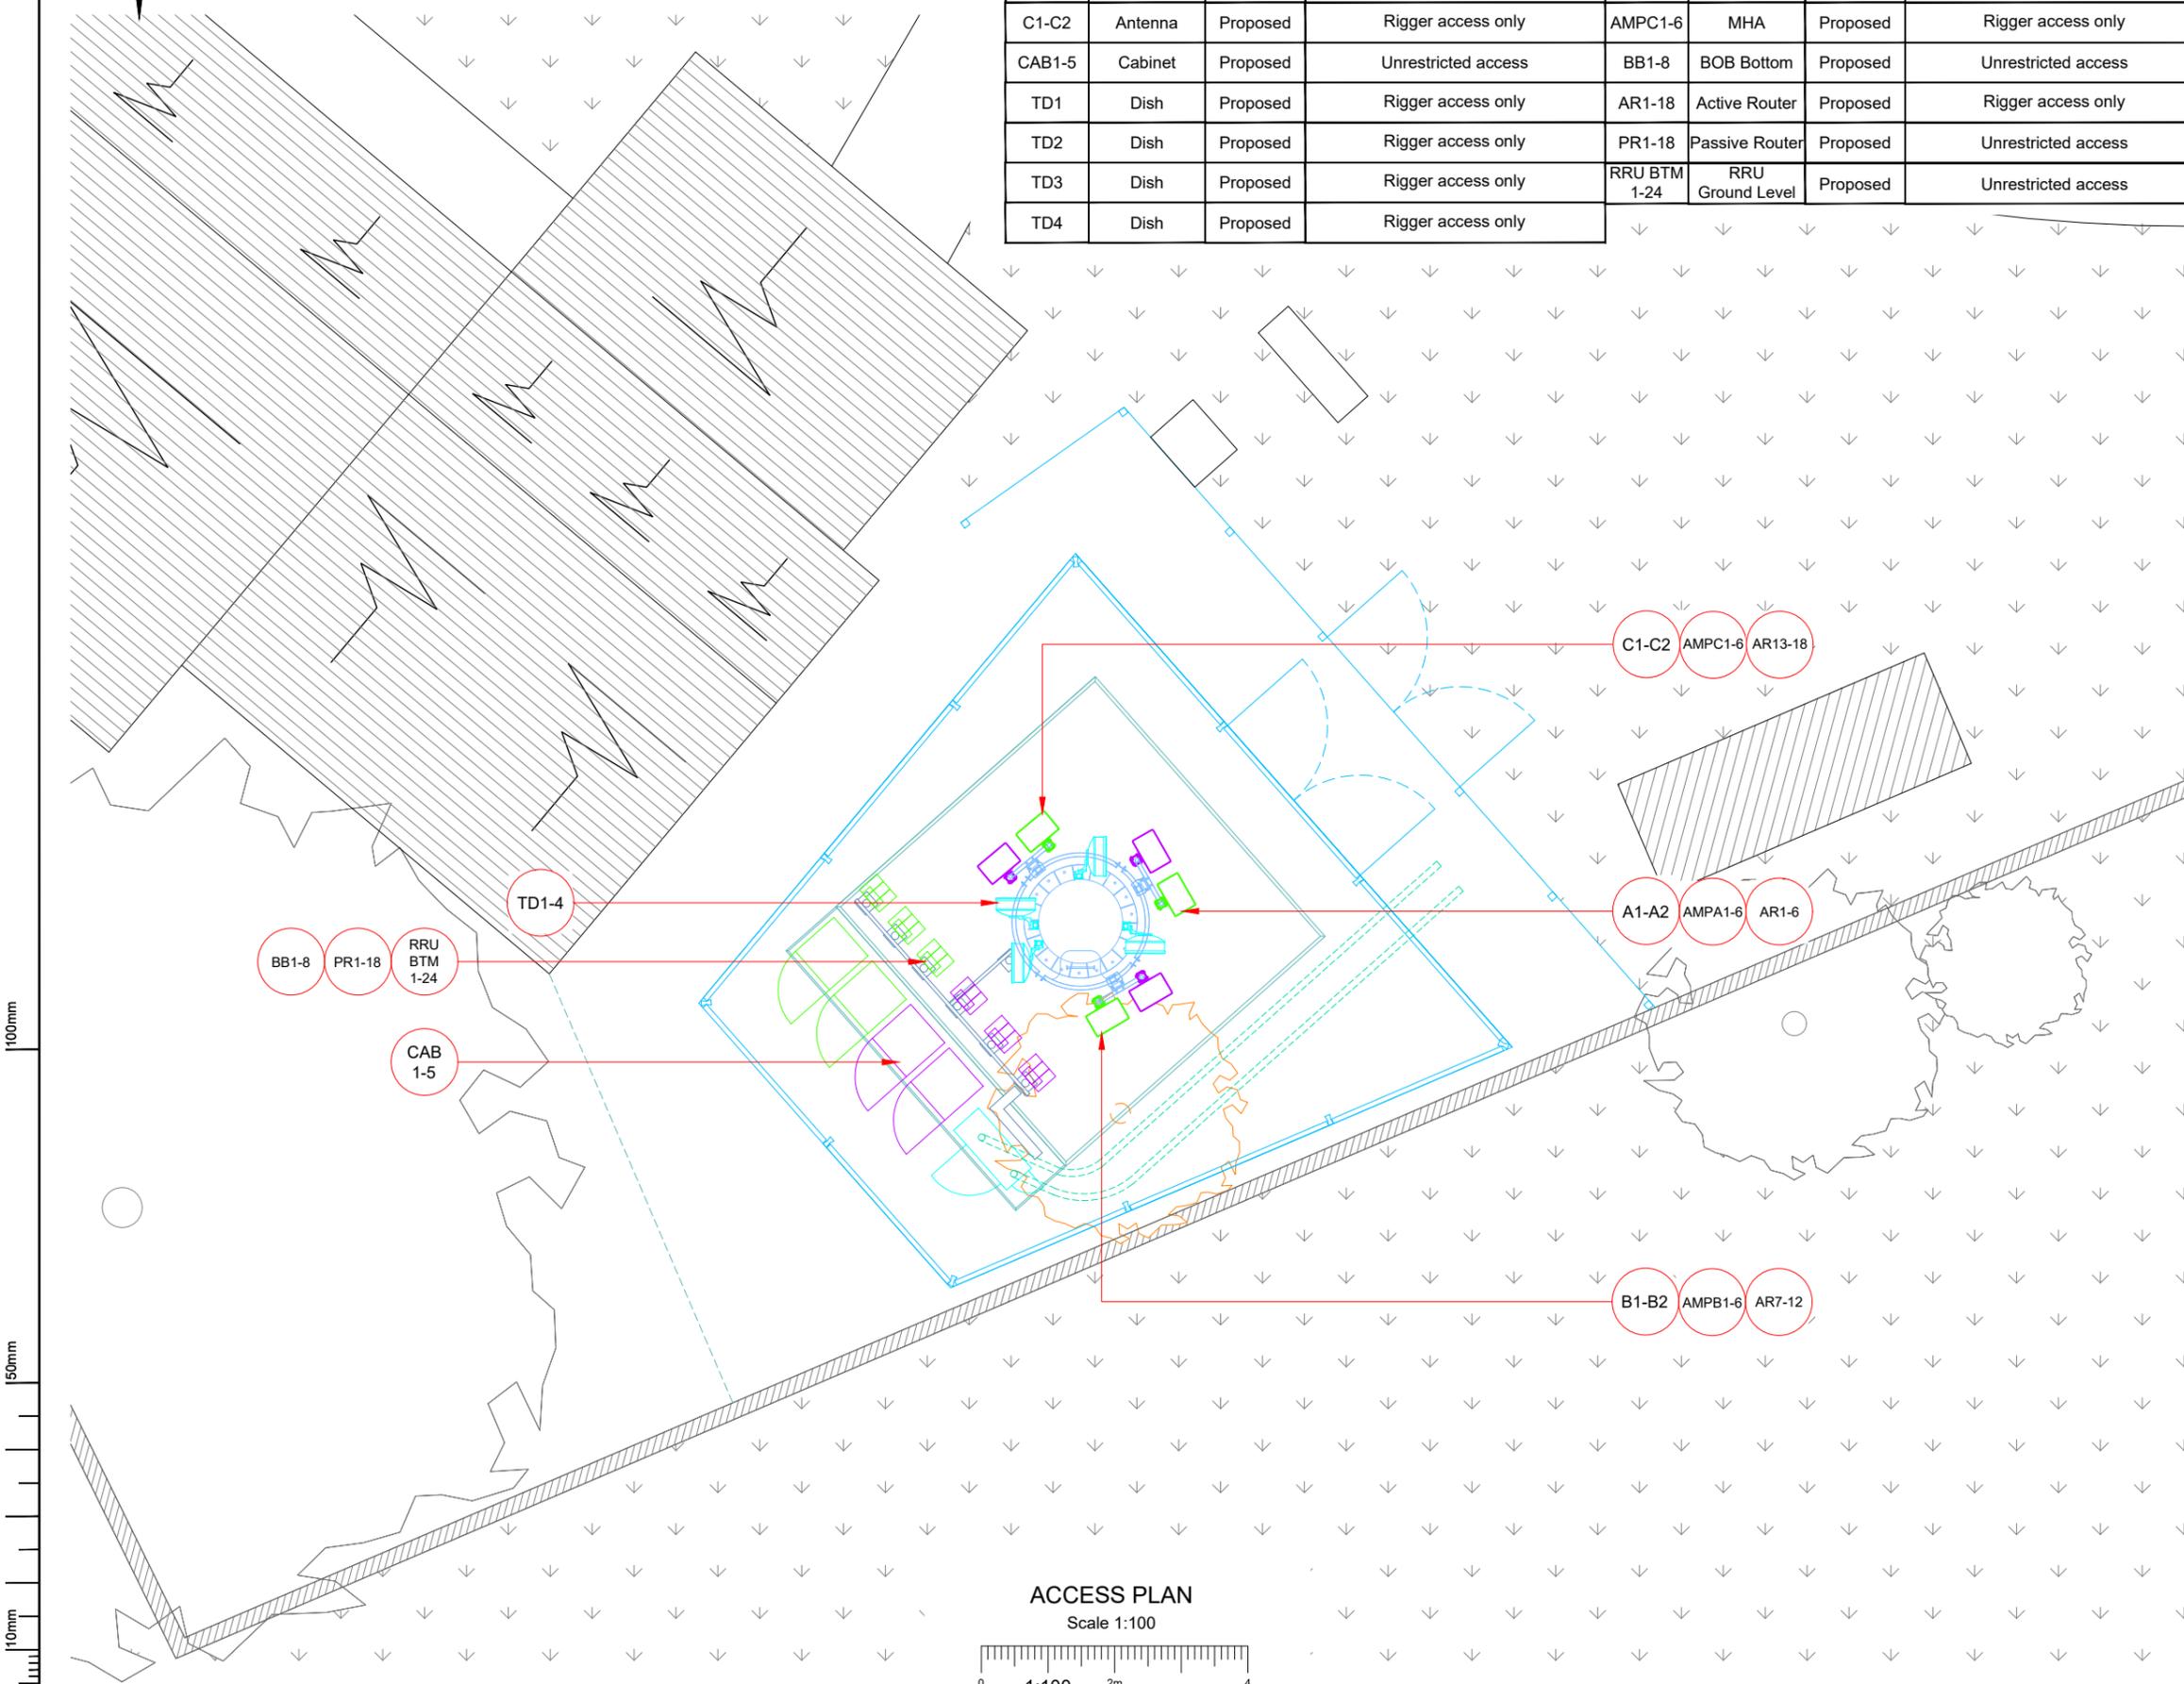

100mm
50mm
10mm

 ACCESS PLAN
Scale 1:100



Master: M001	MBNL / EE / H3G	Project: NTQ	Purpose of Issue: Planning	Issue: A
Date: 23/03/23	Revision / Upgrade Description: First Issue			
Drawn: J. BOOTE				
Checked: J. STOCKDALE				
Approved: J. STOCKDALE				

Hutchison 3G UK Limited
 Star House, 20 Grenfell Road
 Maidenhead, SL6 1EH
 Tel: 01628 765 000
 Fax: 01628 765 001
H3G Base Station Information line:
0845 6043000
Available 8am-8pm Monday to Friday

Hatfield Business Park
 Hatfield
 Hertfordshire
 AL10 9BW
 Tel: 01707 315000
 Fax: 01707 319001

MBNL Mobile Broadband Network Limited
Sixth Floor, Thames Tower, Station Road, Reading, RG1 1LX

Design Consultant & Principal Contractor:

WHP Telecoms
Unit 1 Maple Park,
Low Fields Avenue, Leeds
LS12 6HH
Tel: 01133023550
e-mail: info@whptelecoms.com

Site Name: **ALMONDBURY CRICKET CLUB**

Site ID: **1700355**

Address: **ALMONDBURY CRICKET CLUB,
FERNSIDE AVENUE,
ALMONDBURY, HUDDERSFIELD,
WEST YORKSHIRE,
HD5 8PF**



Title: **003 ACCESS PLAN**

Project: **NTQ**

Purpose of Issue: **GENERAL ARRANGEMENT**

EE Cell ID: 96739	MBNL Cell ID: KKS251	3UK Cell ID: -
-----------------------------	--------------------------------	--------------------------

Master Drawing No: **1700355_KKS251_96739_M001** Issue: **A**

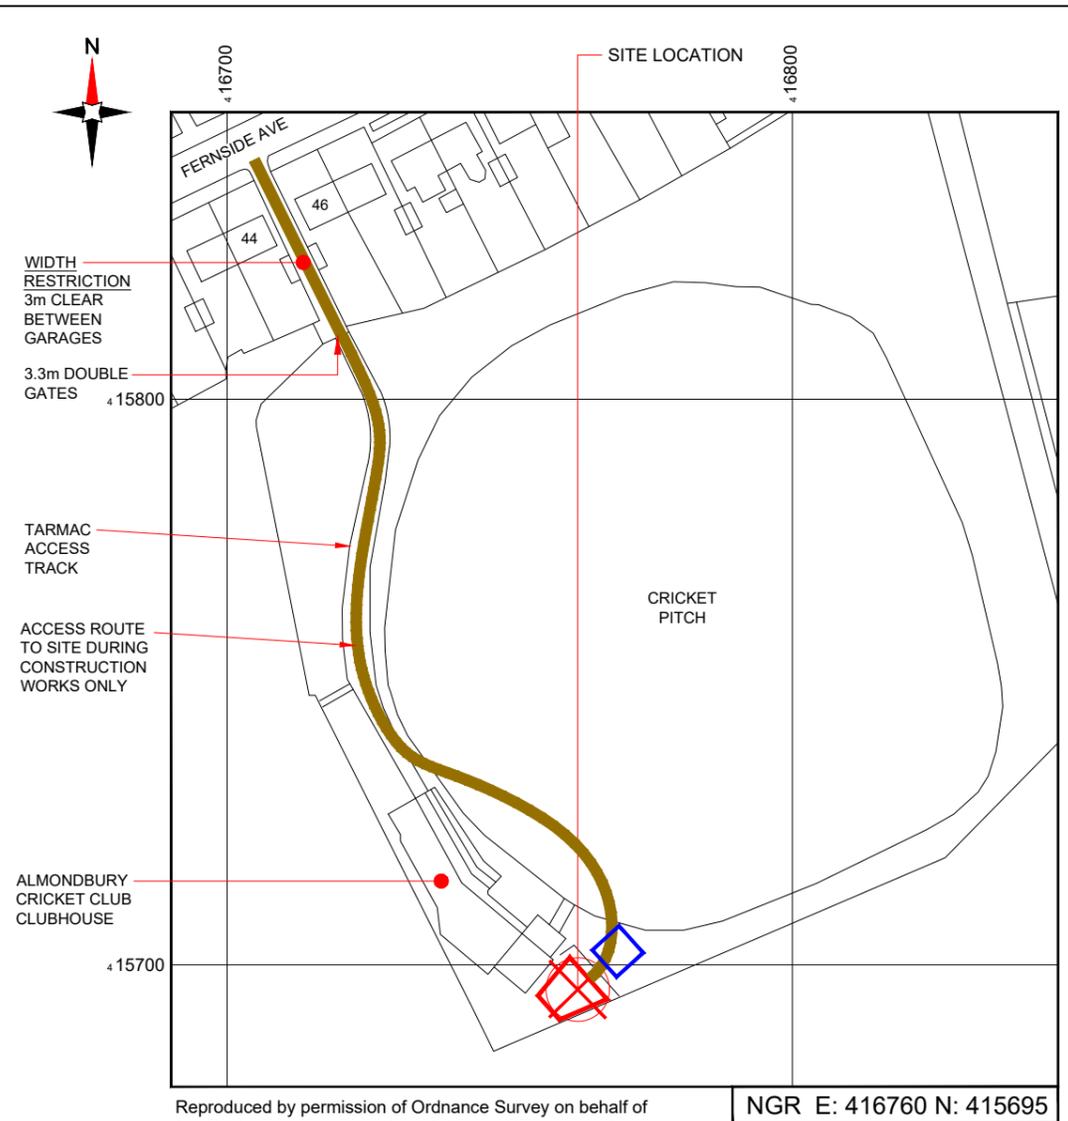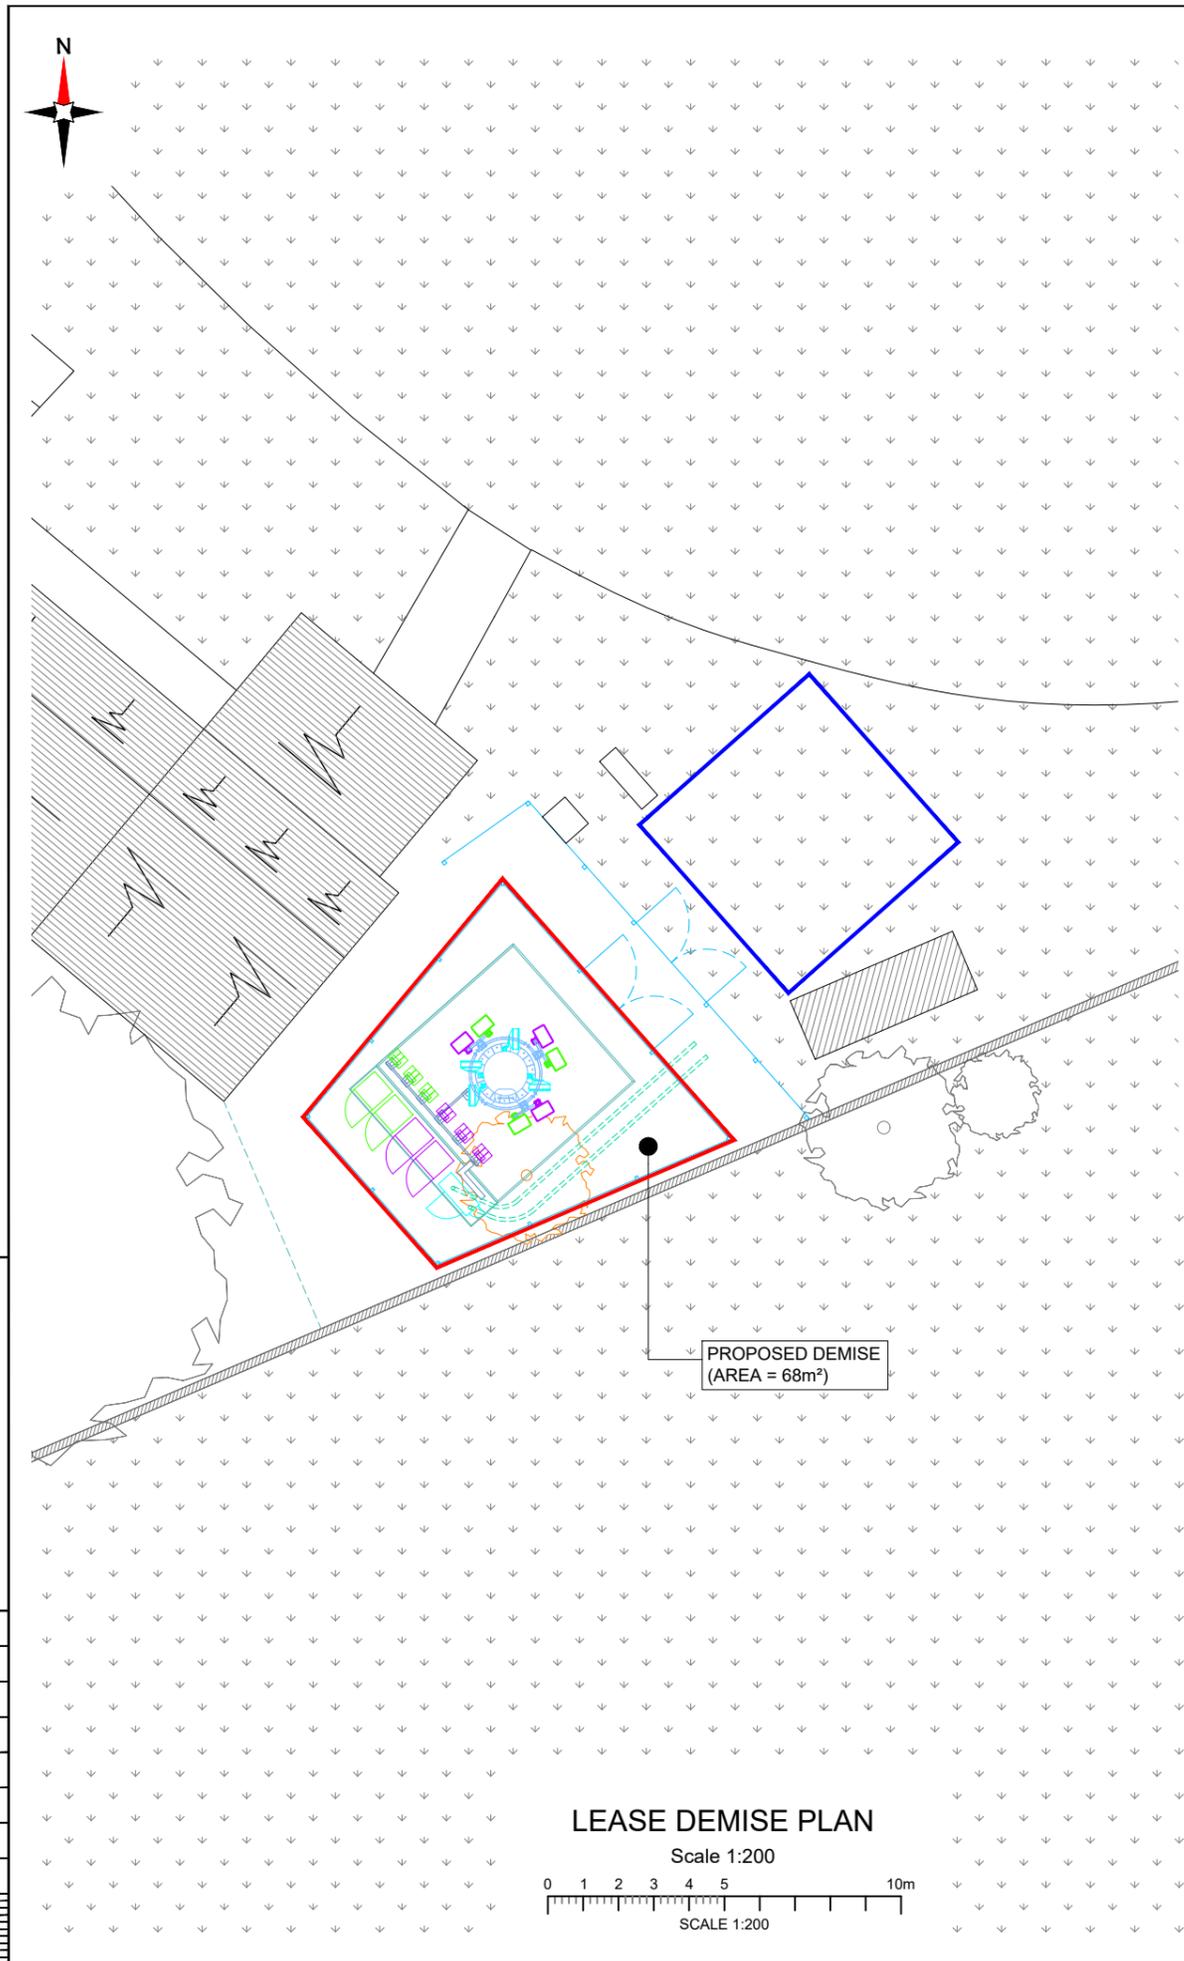

Reproduced by permission of Ordnance Survey on behalf of the Controller of Her Majesty's Stationery Office All rights reserved. © Crown Copyright licence no. 0100031673

NEW CODE:

Demise:	Outlined in Red	
Access Route:	Solid Brown	
Set Down Area:	Outlined in Blue	

Master:	MBNL / EE / H3G:	Project:	Purpose of Issue:	Issue:
M001	MBNL	NTQ	Planning	A
Date:	23/03/23	Revision / Upgrade Description:		
Drawn:	J. BOOTE	First Issue		
Checked:	J. STOCKDALE			
Approved:	J. STOCKDALE			

 Hutchison 3G UK Limited Star House, 20 Grenfell Road Maidenhead, SL6 1EH Tel: 01628 765 000 Fax: 01628 765 001 H3G Base Station Information line: 0845 6043000 Available from 8pm Monday to Friday	 Hatfield Business Park Hatfield Hertfordshire AL10 9BW Tel: 01707 315000 Fax: 01707 319001

MBNL Mobile Broadband Network Limited
 Sixth Floor, Thames Tower, Station Road, Reading, RG1 1LX

Design Consultant & Principal Contractor:

WHP Telecoms
 Unit 1 Maple Park,
 Low Fields Avenue, Leeds
 LS12 6HH
 Tel: 01133023550
 e-mail: info@whptelecoms.com

Site Name: **ALMONDBURY CRICKET CLUB**

Site ID: **1700355**

Address: **ALMONDBURY CRICKET CLUB,
 FERNSIDE AVENUE,
 ALMONDBURY, HUDDERSFIELD,
 WEST YORKSHIRE,
 HD5 8PF**

Title: **004 LEASE DEMISE**


Project: **NTQ**

Purpose of Issue: **GENERAL ARRANGEMENT**

EE Cell ID:	MBNL Cell ID:	3UK Cell ID:
96739	KKS251	-

Master Drawing No: **1700355_KKS251_96739_M001** Issue: **A**

100mm
50mm
10mm

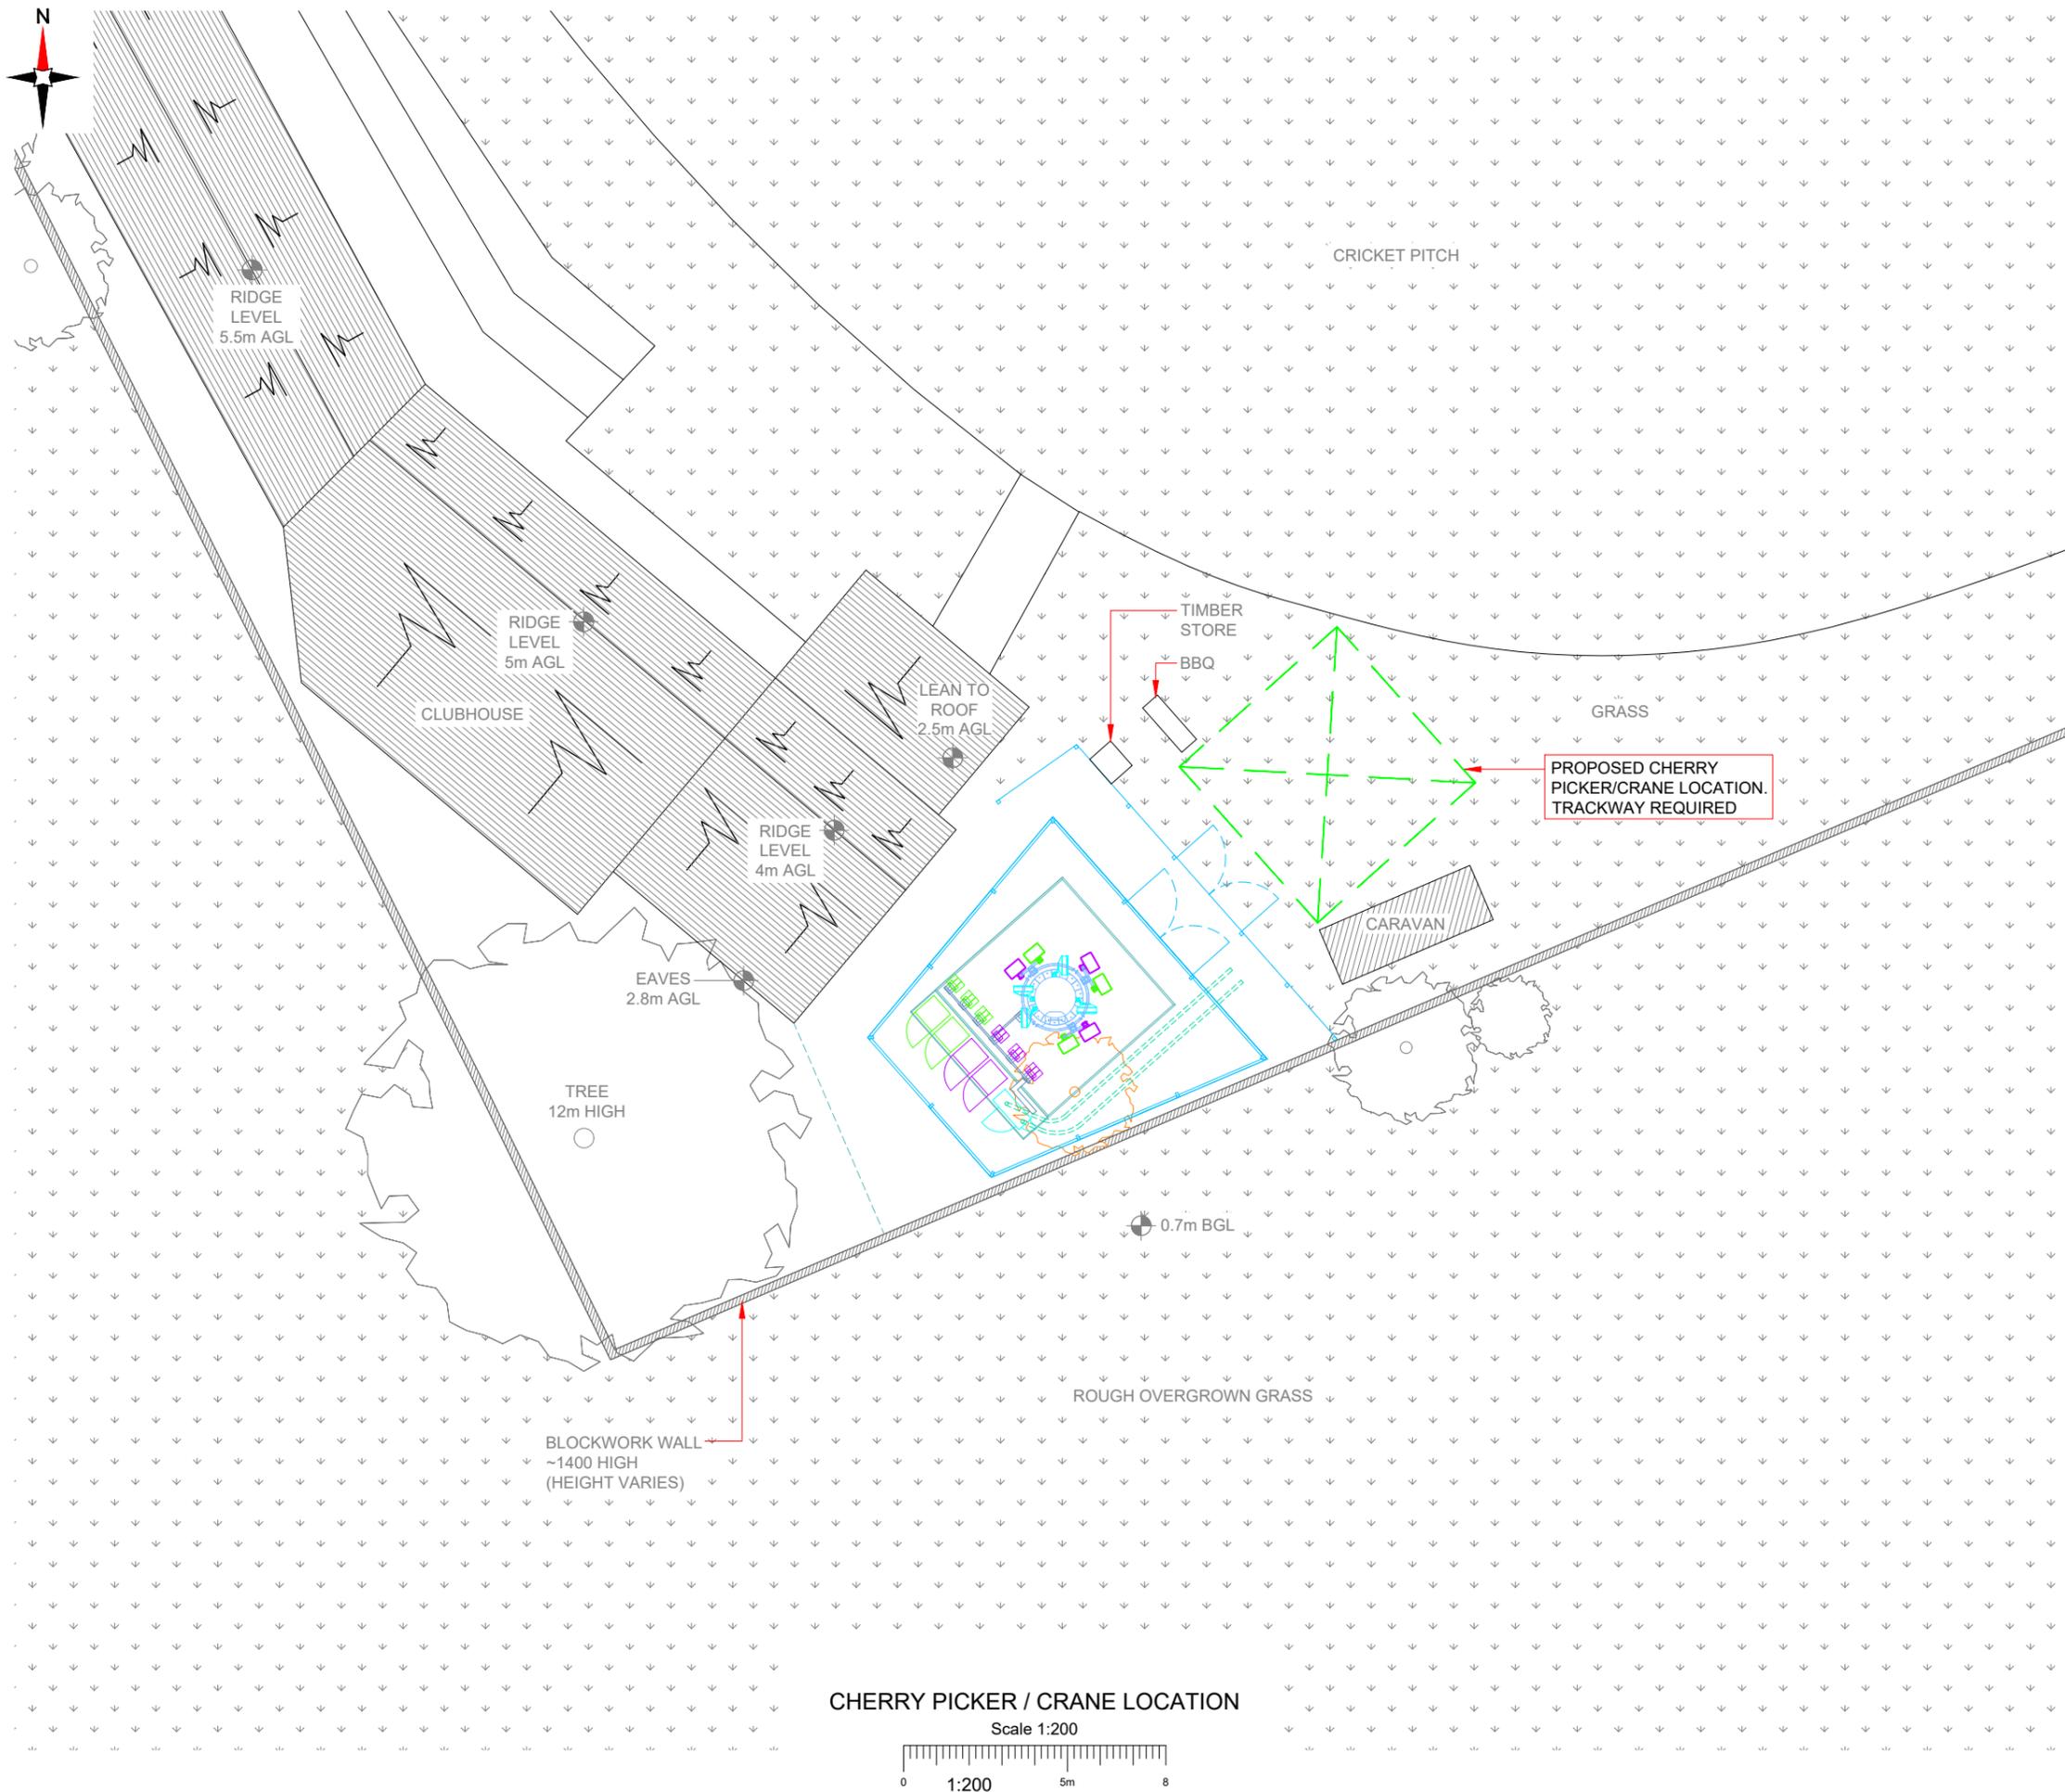

NOTES:

1. ALL DIMENSIONS IN MM UNLESS OTHERWISE NOTED.

PROPOSED CRANE OR CHERRY PICKER LOCATION:

Master:	MBNL / EE / H3G:	Project:	Purpose of Issue:	Issue:
M001	MBNL	NTQ	Planning	A
Date:	23/03/23	Revision / Upgrade Description:		
Drawn:	J. BOOTE	First Issue		
Checked:	J. STOCKDALE			
Approved:	J. STOCKDALE			

 Hutchison 3G UK Limited Star House, 20 Grenfell Road Maidenhead, SL6 1EH Tel: 01628 765 000 Fax: 01628 765 001 H3G Base Station Information line: 0845 6043000 Available 8am-8pm Monday to Friday	 Hatfield Business Park Hatfield Hertfordshire AL10 9BW Tel: 01707 315000 Fax: 01707 319001
--	---

MBNL Mobile Broadband Network Limited
Sixth Floor, Thames Tower, Station Road, Reading, RG1 1LX

Design Consultant & Principal Contractor:

WHP Telecoms
 Unit 1 Maple Park,
 Low Fields Avenue, Leeds
 LS12 6HH
 Tel: 01133023550
 e-mail: info@whptelecoms.com

Site Name: **ALMONDBURY CRICKET CLUB**

Site ID: **1700355**

Address: **ALMONDBURY CRICKET CLUB,
 FERNSIDE AVENUE,
 ALMONDBURY, HUDDERSFIELD,
 WEST YORKSHIRE,
 HD5 8PF**

Title: **005 CHERRY PICKER & CRANE LOCATION**

Project: **NTQ**


Purpose of Issue: **GENERAL ARRANGEMENT**

EE Cell ID:	MBNL Cell ID:	3UK Cell ID:
96739	KKS251	-

Master Drawing No: **1700355_KKS251_96739_M001** Issue: **A**

100mm
50mm
10mm

CHERRY PICKER / CRANE LOCATION
 Scale 1:200
 0 1:200 5m 8

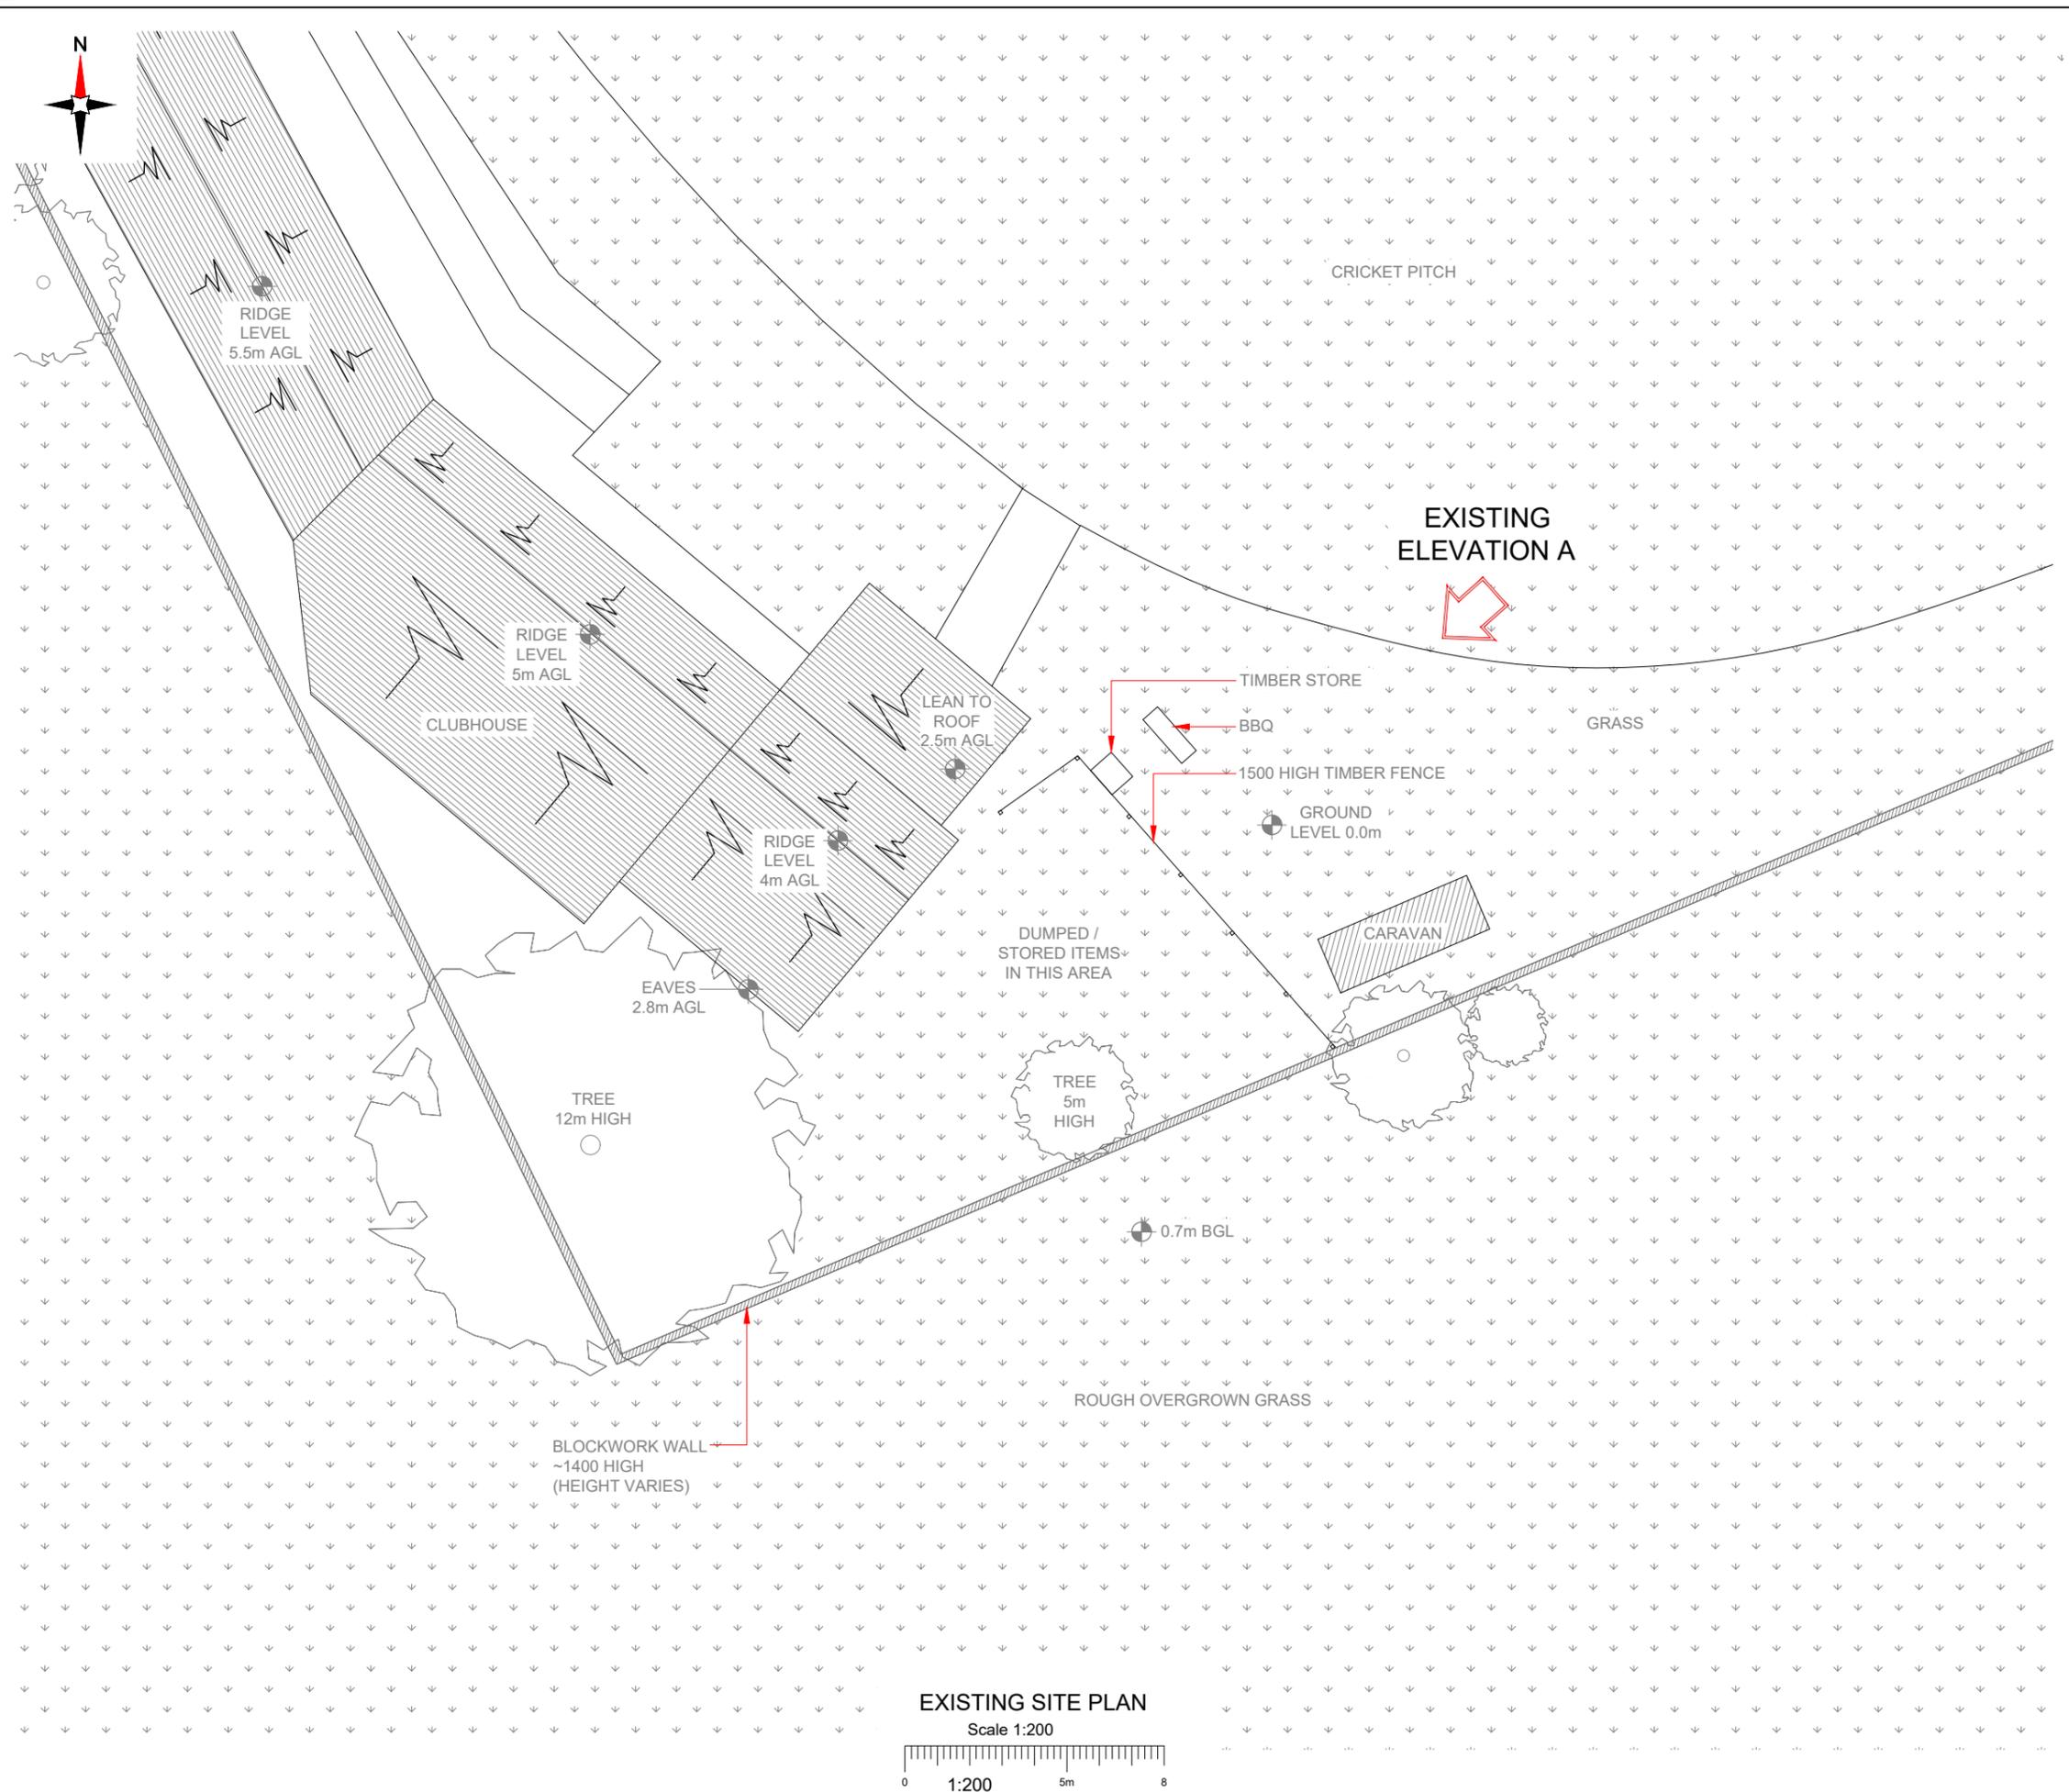

EXISTING SITE PLAN
Scale 1:200

NOTES:

- ALL DIMENSIONS IN MM UNLESS OTHERWISE NOTED.

Master: M001	MBNL / EE / H3G:	Project: NTQ	Purpose of Issue: Planning	Issue: A
Date: 23/03/23	Revision / Upgrade Description:			
Drawn: J. BOOTE	First Issue			
Checked: J. STOCKDALE				
Approved: J. STOCKDALE				


 Hutchison 3G UK Limited Star House, 20 Grenfell Road Maidenhead, SL6 1EH Tel: 01628 765 000 Fax: 01628 765 001 H3G Base Station Information line: 0845 6043000 Available 8am-8pm Monday to Friday	 Hatfield Business Park Hatfield Hertfordshire AL10 9BW Tel: 01707 315000 Fax: 01707 319001
--	---

MBNL Mobile Broadband Network Limited
Sixth Floor, Thames Tower, Station Road, Reading, RG1 1LX

Design Consultant & Principal Contractor:

WHP Telecoms
 Unit 1 Maple Park,
 Low Fields Avenue, Leeds
 LS12 6HH
 Tel: 01133023550
 e-mail: info@whptelecoms.com

Site Name:	ALMONDBURY CRICKET CLUB				
Site ID:	1700355				
Address:	ALMONDBURY CRICKET CLUB, FERNside AVENUE, ALMONDBURY, HUDDERSFIELD, WEST YORKSHIRE, HD5 8PF				
Title:	100 EXISTING SITE PLAN				
Project:	NTQ				
Purpose of Issue:	GENERAL ARRANGEMENT				
EE Cell ID:	96739	MBNL Cell ID:	KKS251	3UK Cell ID:	-
Master Drawing No:	1700355_KKS251_96739_M001			Issue:	A

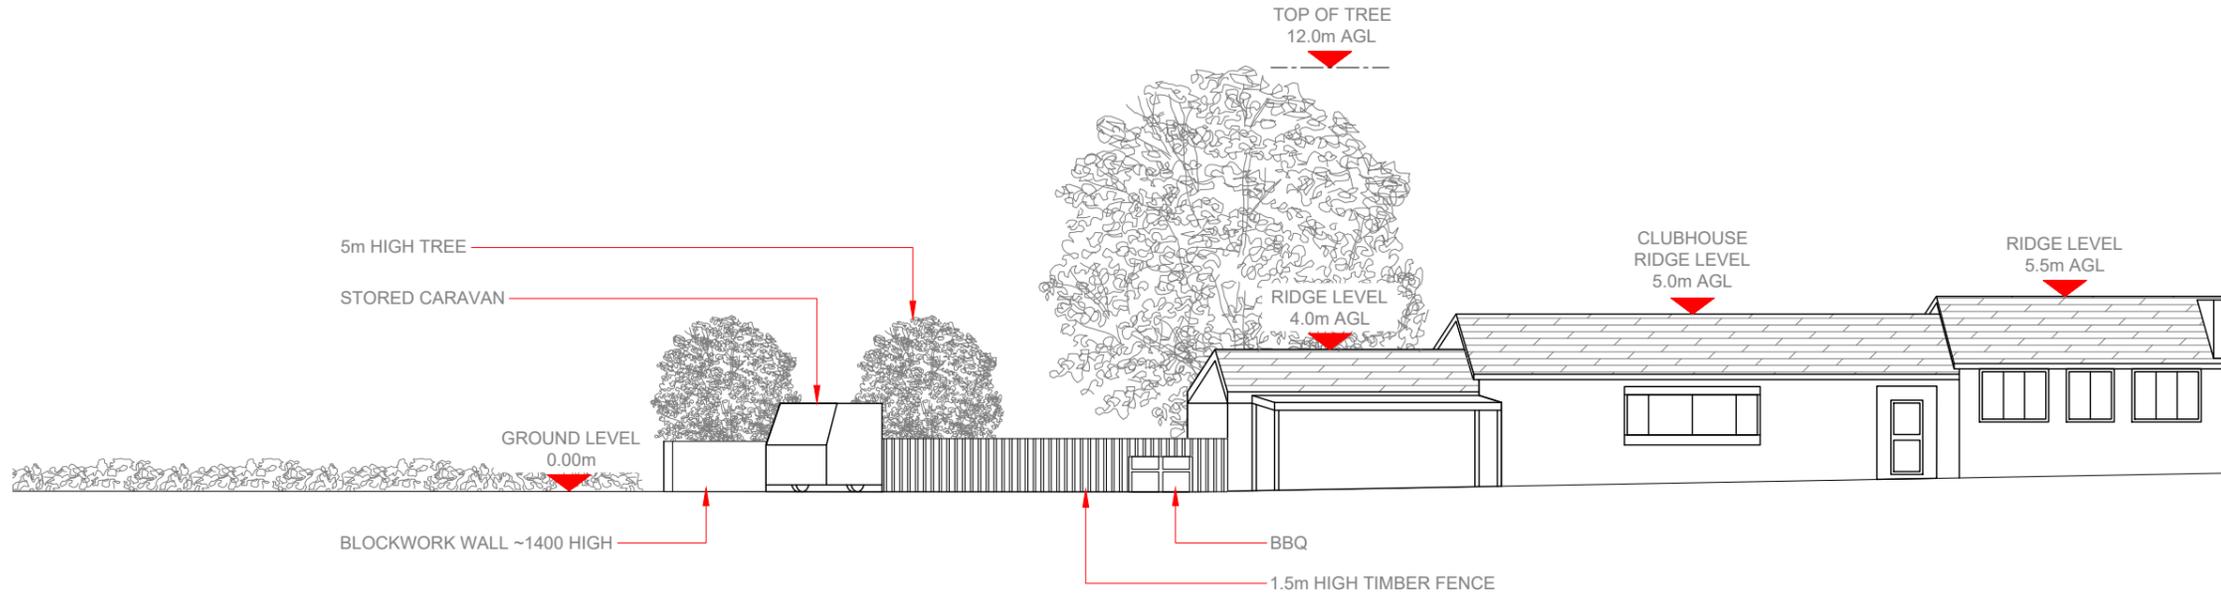

EXISTING ELEVATION A

Scale 1:200



NOTES:

1. ALL DIMENSIONS IN MM UNLESS OTHERWISE NOTED.

Master:	MBNL / EE / H3G:	Project:	Purpose of Issue:	Issue:
M001	MBNL	NTQ	Planning	A
Date:	23/03/23	Revision / Upgrade Description:		
Drawn:	J. BOOTE	First Issue		
Checked:	J. STOCKDALE			
Approved:	J. STOCKDALE			

<p>Hutchison 3G UK Limited Star House, 20 Grenfell Road Maidenhead, SL6 1EH Tel: 01628 765 000 Fax: 01628 765 001</p> <p>H3G Base Station Information line: 0845 6043000 Available 8am-8pm Monday to Friday</p>	<p>Hatfield Business Park Hatfield Hertfordshire AL10 9BW</p> <p>Tel: 01707 315000 Fax: 01707 319001</p>

Design Consultant & Principal Contractor:

WHP Telecoms
Unit 1 Maple Park,
Low Fields Avenue, Leeds
LS12 6HH

Tel: 01133023550
e-mail: info@whptelecoms.com

Site Name:
ALMONDBURY CRICKET CLUB

Site ID:
1700355

Address:
**ALMONDBURY CRICKET CLUB,
FERNSIDE AVENUE,
ALMONDBURY, HUDDERSFIELD,
WEST YORKSHIRE,
HD5 8PF**

Title:
150 EXISTING ELEVATION A


Project:
NTQ

Purpose of Issue:
GENERAL ARRANGEMENT

EE Cell ID: 96739	MBNL Cell ID: KKS251	3UK Cell ID: -
-----------------------------	--------------------------------	--------------------------

Master Drawing No: 1700355_KKS251_96739_M001	Issue: A
--	--------------------

100mm
50mm
10mm

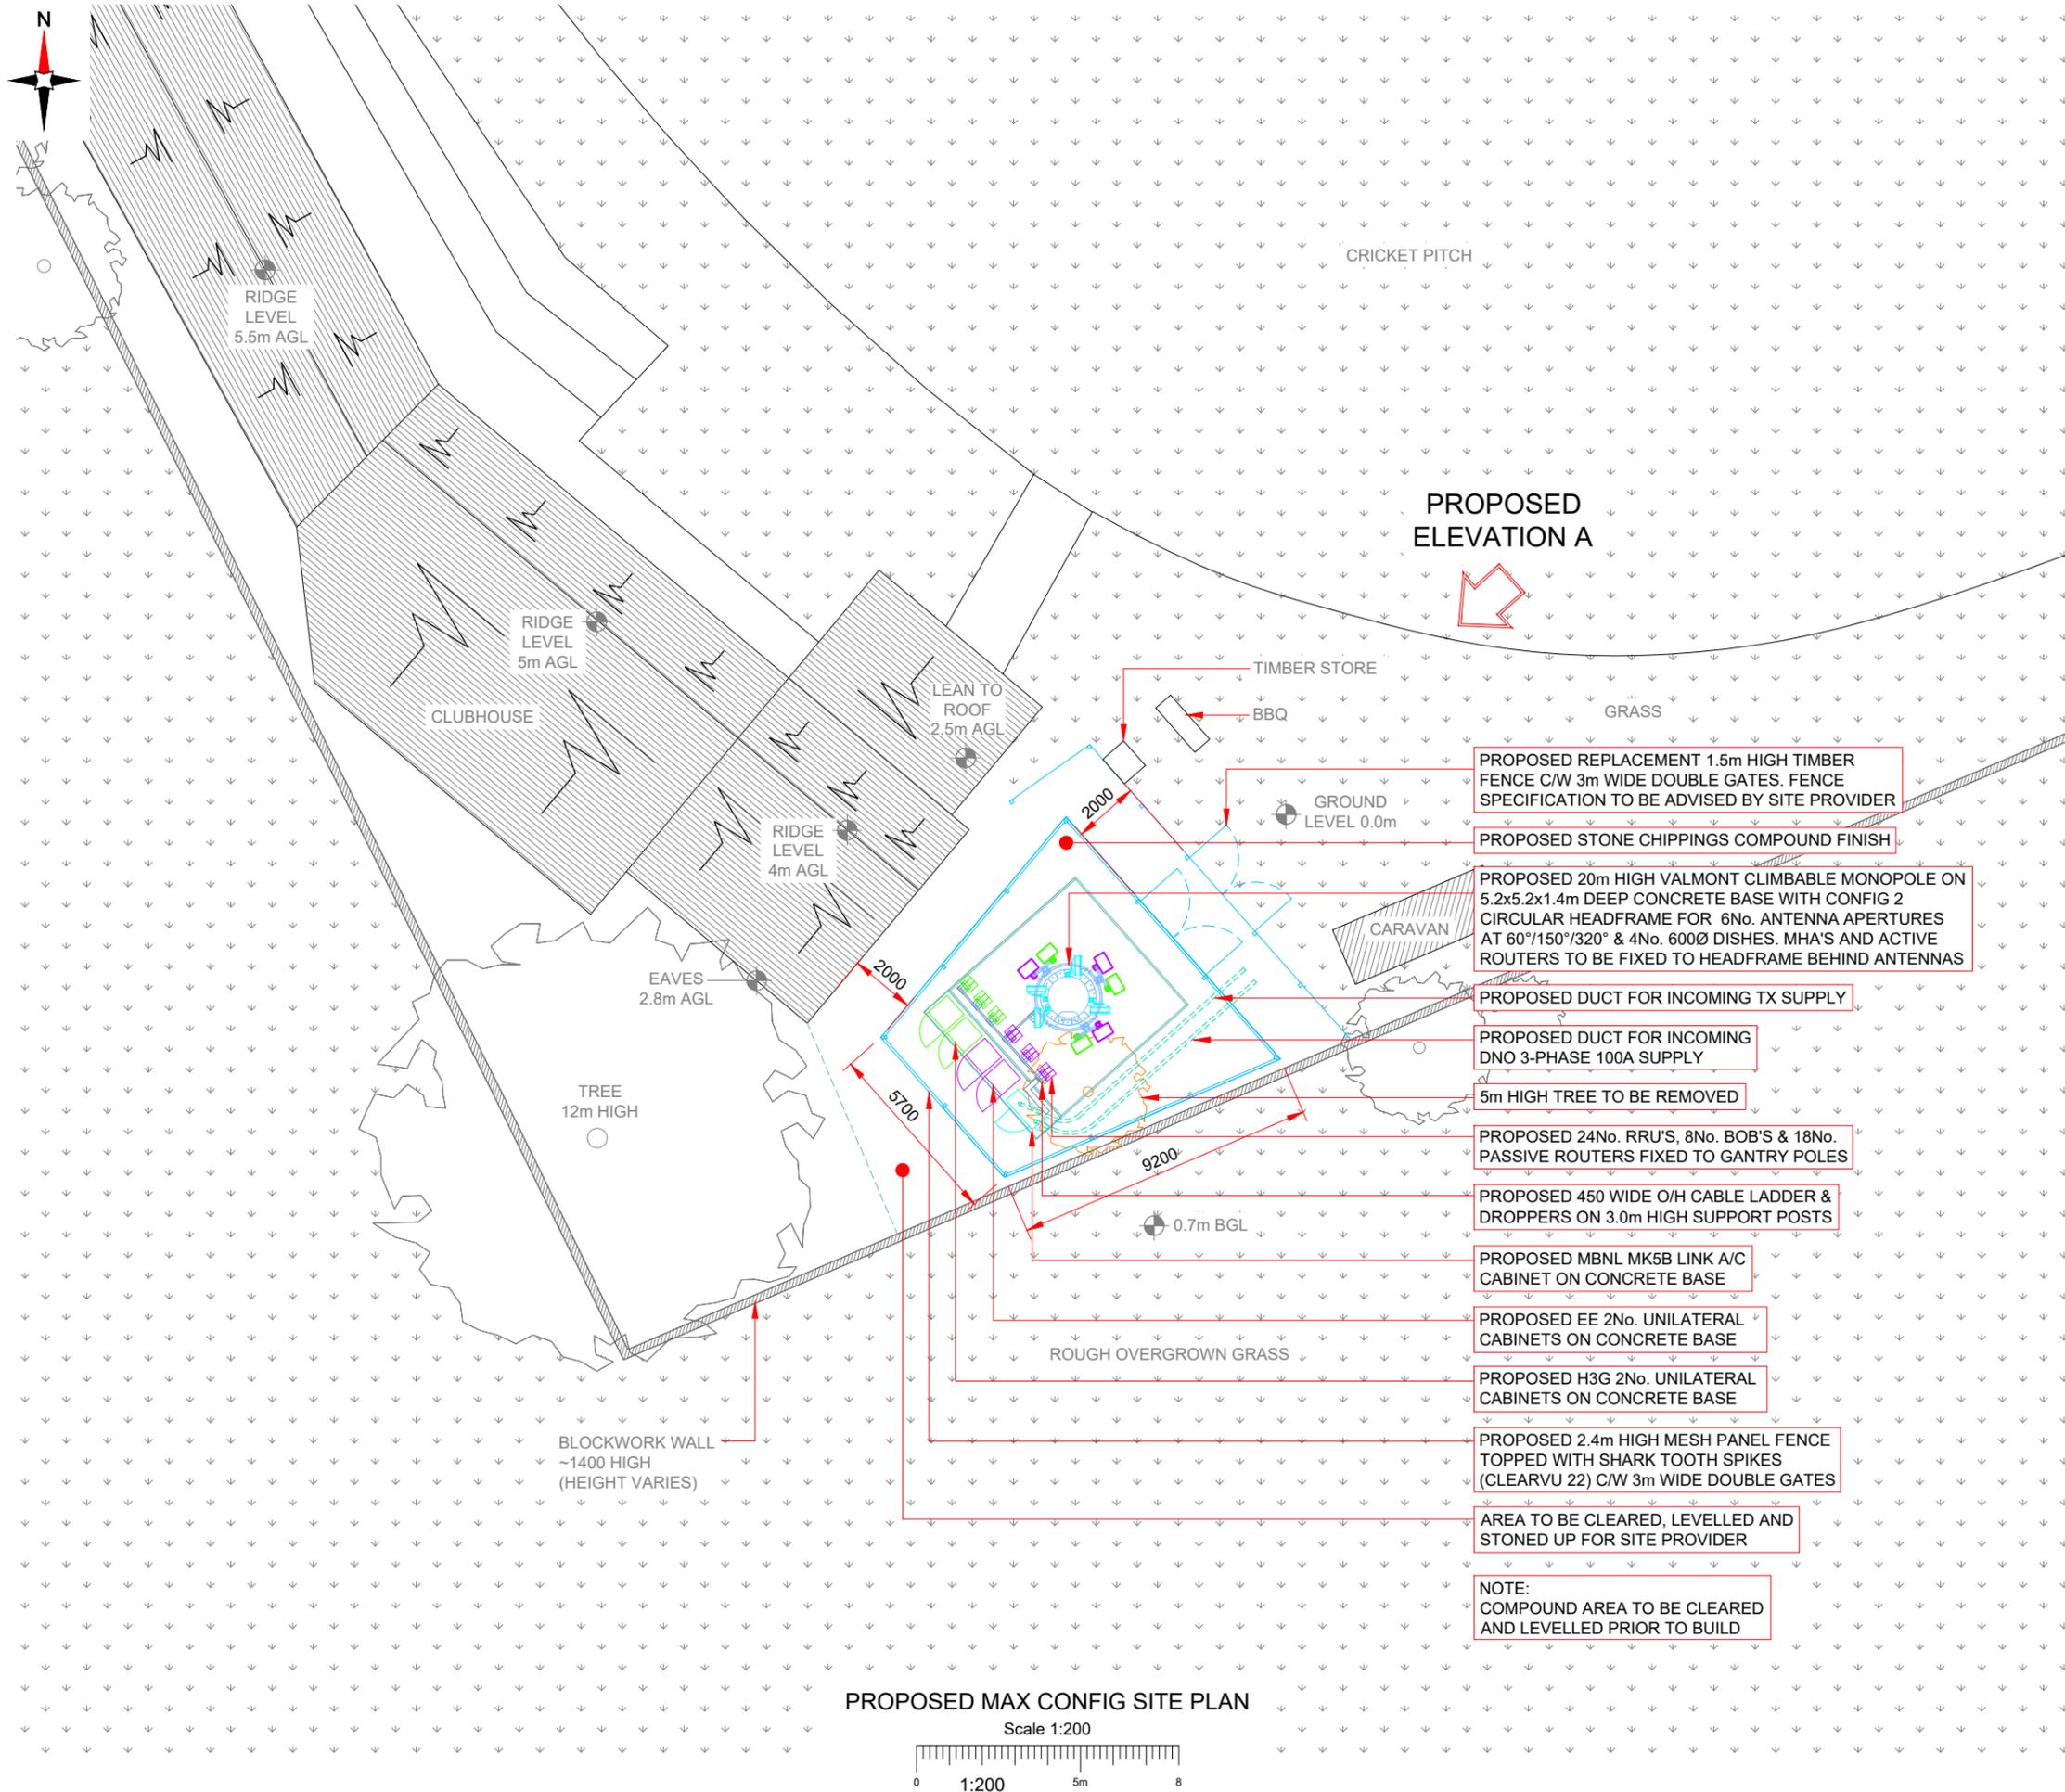

- PROPOSED REPLACEMENT 1.5m HIGH TIMBER FENCE C/W 3m WIDE DOUBLE GATES. FENCE SPECIFICATION TO BE ADVISED BY SITE PROVIDER
- PROPOSED STONE CHIPPINGS COMPOUND FINISH
- PROPOSED 20m HIGH VALMONT CLIMBABLE MONOPOLE ON 5.2x5.2x1.4m DEEP CONCRETE BASE WITH CONFIG 2 CIRCULAR HEADFRAME FOR 6No. ANTENNA APERTURES AT 60°/150°/320° & 4No. 600Ø DISHS. MHA'S AND ACTIVE ROUTERS TO BE FIXED TO HEADFRAME BEHIND ANTENNAS
- PROPOSED DUCT FOR INCOMING TX SUPPLY
- PROPOSED DUCT FOR INCOMING DNO 3-PHASE 100A SUPPLY
- 5m HIGH TREE TO BE REMOVED
- PROPOSED 24No. RRU'S, 8No. BOB'S & 18No. PASSIVE ROUTERS FIXED TO GANTRY POLES
- PROPOSED 450 WIDE O/H CABLE LADDER & DROPPERS ON 3.0m HIGH SUPPORT POSTS
- PROPOSED MBNL MK5B LINK A/C CABINET ON CONCRETE BASE
- PROPOSED EE 2No. UNILATERAL CABINETS ON CONCRETE BASE
- PROPOSED H3G 2No. UNILATERAL CABINETS ON CONCRETE BASE
- PROPOSED 2.4m HIGH MESH PANEL FENCE TOPPED WITH SHARK TOOTH SPIKES (CLEARVU 22) C/W 3m WIDE DOUBLE GATES
- AREA TO BE CLEARED, LEVELLED AND STONED UP FOR SITE PROVIDER
- NOTE: COMPOUND AREA TO BE CLEARED AND LEVELLED PRIOR TO BUILD

PROPOSED MAX CONFIG SITE PLAN
Scale 1:200

NOTES:

- ALL DIMENSIONS IN MM UNLESS OTHERWISE NOTED.

SHARED CONFIGURATION SITE	
RF CONFIG	H3b

Master: M001	MBNL / EE / H3G: MBNL	Project: NTQ	Purpose of Issue: Planning	Issue: A
Date: 23/03/23	Drawn: J. BOOTE	Revision / Upgrade Description: First Issue		
Checked: J. STOCKDALE	Approved: J. STOCKDALE			

Hutchison 3G UK Limited
Star House, 20 Grenfell Road
Maidenhead, SL6 1EH
Tel: 01628 765 000
Fax: 01628 765 001

H3G Base Station Information Line:
0845 6043000
Available from 8pm Monday to Friday

Hatfield Business Park
Hatfield
Hertfordshire
AL10 9BW

Tel: 01707 315000
Fax: 01707 319001

MBNL Mobile Broadband Network Limited
Sixth Floor, Thames Tower, Station Road, Reading, RG1 1LX

Design Consultant & Principal Contractor:

WHP Telecoms
Unit 1 Maple Park,
Low Fields Avenue, Leeds
LS12 6HH

Tel: 01133023550
e-mail: info@whptelecoms.com

Site Name: **ALMONDBURY CRICKET CLUB**

Site ID: **1700355**

Address: **ALMONDBURY CRICKET CLUB,
FERNSIDE AVENUE,
ALMONDBURY, HUDDERSFIELD,
WEST YORKSHIRE,
HD5 8PF**


Title: **215 PROPOSED MAX CONFIGURATION
SITE PLAN**

Project: **NTQ**

Purpose of Issue: **GENERAL ARRANGEMENT**

EE Cell ID: 96739	MBNL Cell ID: KKS251	3UK Cell ID: -
--------------------------	-----------------------------	-----------------------

Master Drawing No: **1700355_KKS251_96739_M001** Issue: **A**

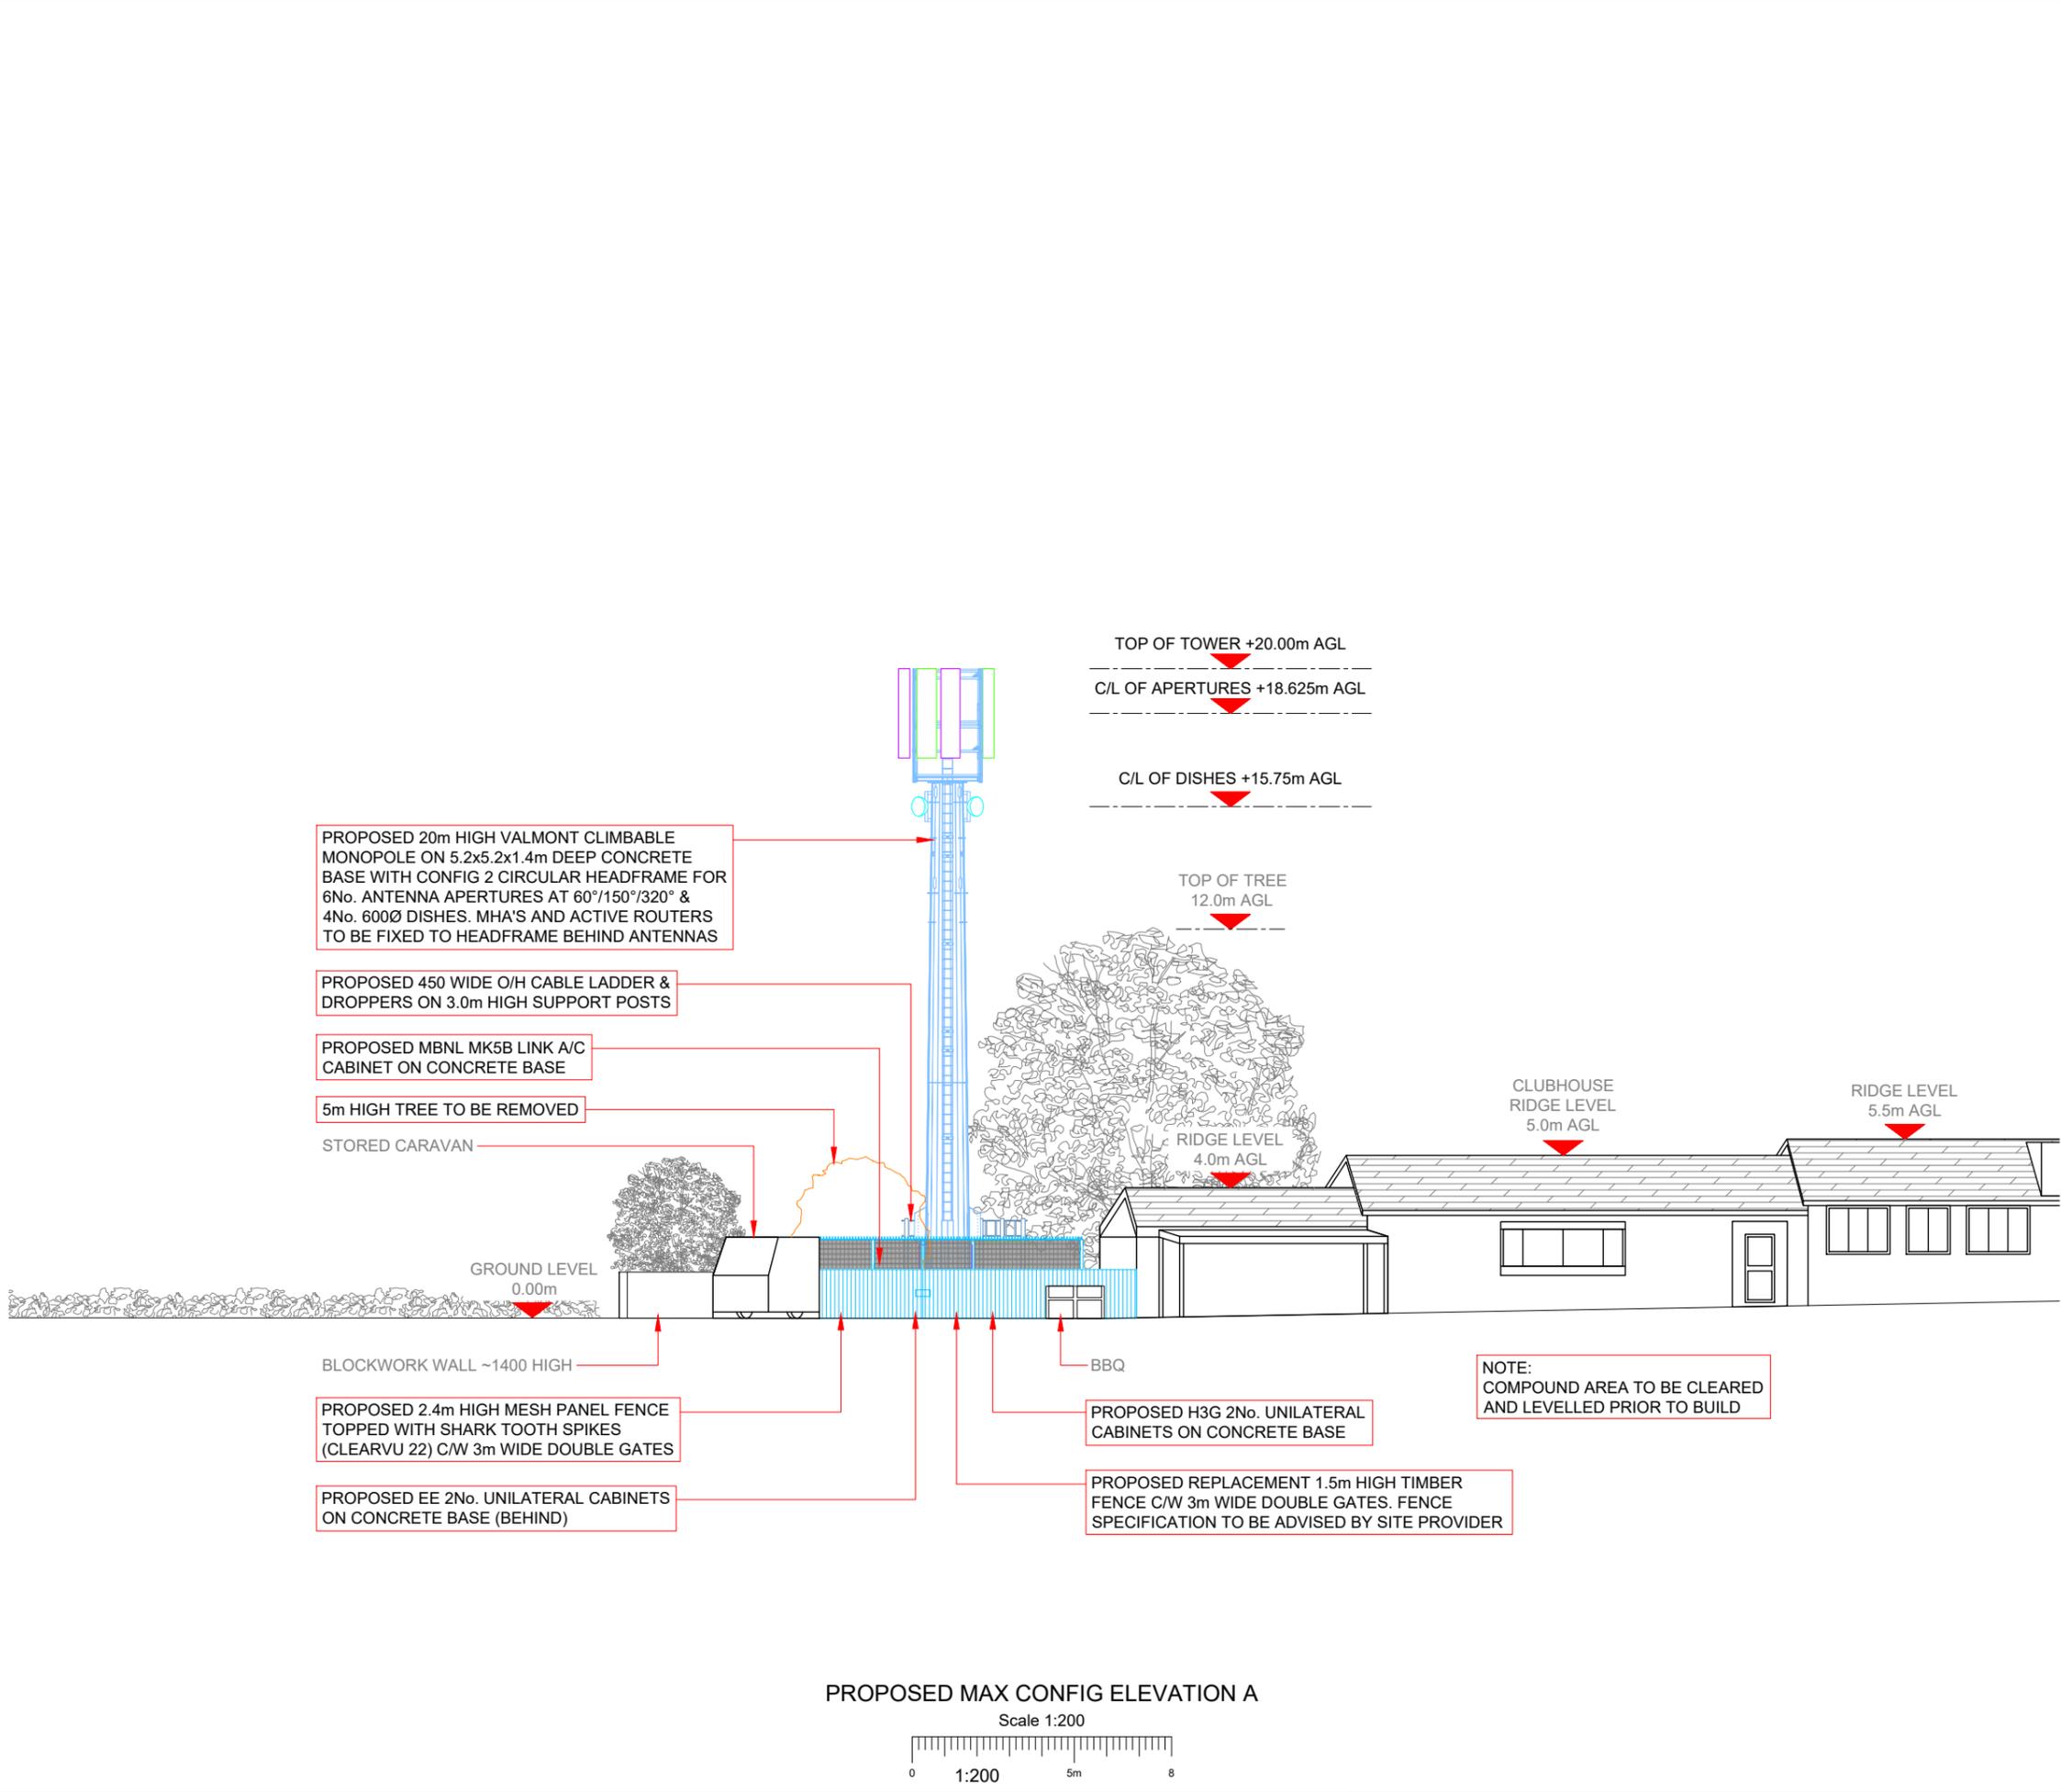

NOTES:
1. ALL DIMENSIONS IN MM UNLESS OTHERWISE NOTED.

SHARED CONFIGURATION SITE	
RF CONFIG	H3b

Master: M001	MBNL / EE / H3G: MBNL	Project: NTQ	Purpose of Issue: Planning	Issue: A
Date: 23/03/23	Revision / Upgrade Description: First Issue			
Drawn: J. BOOTE				
Checked: J. STOCKDALE				
Approved: J. STOCKDALE				

 Hutchison 3G UK Limited Star House, 20 Grenfell Road Maidenhead, SL6 1EH Tel: 01628 765 000 Fax: 01628 765 001 H3G Base Station Information line: 0845 6043000 Available 8am-8pm Monday to Friday	 Hatfield Business Park Hatfield Hertfordshire AL10 9BW Tel: 01707 315000 Fax: 01707 319001
--	---

MBNL Mobile Broadband Network Limited
Sixth Floor, Thames Tower, Station Road, Reading, RG1 1LX

Design Consultant & Principal Contractor:

WHP Telecoms
 Unit 1 Maple Park,
 Low Fields Avenue, Leeds
 LS12 6HH
 Tel: 01133023550
 e-mail: info@whptelecoms.com

Site Name: **ALMONDBURY CRICKET CLUB**

Site ID: **1700355**

Address: **ALMONDBURY CRICKET CLUB,
FERNESIDE AVENUE,
ALMONDBURY, HUDDERSFIELD,
WEST YORKSHIRE,
HD5 8PF**

Title: **265 PROPOSED MAX CONFIGURATION
ELEVATION A**

Project: **NTQ**

Purpose of Issue: **GENERAL ARRANGEMENT**

EE Cell ID: 96739	MBNL Cell ID: KKS251	3UK Cell ID: -
-----------------------------	--------------------------------	--------------------------

Master Drawing No: **1700355_KKS251_96739_M001** Issue: **A**

100mm
50mm
10mm

Max Configuration Antenna Aperture Schedule & RF Equipment Capacity

Antenna Aperture ID	Antenna Aperture Size (Length x Width x Depth)	Aperture Height C/L	Aperture Max Weight (kg)	Proposed Bearing	Tech:	Operator: Shared/ EE/H3G	Antenna Aperture Coordinates		RRU No. Max Size & Weight L=500mm W=400mm D=150mm Weight=25kg	MHA No. Max Size & Weight L=300mm W=300mm D=150mm Weight=10kg	Main Feeder			BOB Max Size & Weight (300x300x250mm & 5kg)		Active Router No. Max Size & Weight (370x260x150mm & 10kg)	Passive Router No. Max Size & Weight (350x220x150mm & 10kg)
							Eastings	Northings			Size	Length	No.	No. Top	No. Bottom		
A1	2750x550x350mm	18.625m	130kg	60°	2G/4G/5G	EE	-	-	-	3	LDF5-50	25.0m	6	-	2	3	3
A2	2750x550x350mm	18.625m	130kg	60°	4G/5G	H3G	-	-	-	3	LDF5-50	25.0m	6	-	1	3	3
B1	2750x550x350mm	18.625m	130kg	150°	2G/4G/5G	EE	-	-	-	3	LDF5-50	25.0m	6	-	2	3	3
B2	2750x550x350mm	18.625m	130kg	150°	4G/5G	H3G	-	-	-	3	LDF5-50	25.0m	6	-	1	3	3
C1	2750x550x350mm	18.625m	130kg	320°	2G/4G/5G	EE	-	-	-	3	LDF5-50	25.0m	6	-	2	3	3
C2	2750x550x350mm	18.625m	130kg	320°	4G/5G	H3G	-	-	-	3	LDF5-50	25.0m	6	-	-	3	3

NOTE:
THERE MAY BE UP TO 2 ANTENNAS PER APERTURE
SUBJECT TO SITE SPECIFIC RADIO DESIGN

Passive Infrastructure Equipment Capacity		
A	B	C
H3b	H3b	H3b

STATUS KEY:
Installed: Existing
Retain: Existing and to remain
Relocate: Existing and to be relocated
Remove: Existing to be removed from site
Proposed: New on site

Master: M001	MBNL / EE / H3G: MBNL	Project: NTQ	Purpose of Issue: Planning	Issue: A
Date: 23/03/23	Revision / Upgrade Description:			
Drawn: J. BOOTE	First Issue			
Checked: J. STOCKDALE				
Approved: J. STOCKDALE				

 Hutchison 3G UK Limited Star House, 20 Grenfell Road Maidenhead, SL6 1EH Tel: 01628 765 000 Fax: 01628 765 001 H3G Base Station Information line: 0845 6043000 Available 8am-8pm Monday to Friday	 Hatfield Business Park Hatfield Hertfordshire AL10 9BW Tel: 01707 315000 Fax: 01707 319001
---	--

MBNL Mobile Broadband Network Limited
 Sixth Floor, Thames Tower, Station Road, Reading, RG1 1LX

Design Consultant & Principal Contractor:



WHP Telecoms
 Unit 1 Maple Park,
 Low Fields Avenue, Leeds
 LS12 6HH
 Tel: 01133023550
 e-mail: info@whptelecoms.com

Site Name: **ALMONDBURY CRICKET CLUB**

Site ID: **1700355**

Address: **ALMONDBURY CRICKET CLUB,
 FERNSIDE AVENUE,
 ALMONDBURY, HUDDERSFIELD,
 WEST YORKSHIRE,
 HD5 8PF**

Title: **304 MAX CONFIGURATION ANTENNA
 SCHEDULE & LINE CONFIGURATION**

Project: **NTQ**

Purpose of Issue: **GENERAL ARRANGEMENT**

EE Cell ID: 96739	MBNL Cell ID: KKS251	3UK Cell ID: -
-----------------------------	--------------------------------	--------------------------

Master Drawing No: **1700355_KKS251_96739_M001** Issue: **A**

100mm
50mm
10mm