


GENERAL NOTES
 GENERALLY PIPES WITHOUT SIZES SHOWN TO BE 100 MM DIAMETER.
 ALL PIPES FROM ROAD GULLIES 150MM DIAMETER. MAIN FOUL PIPES GENERALLY ARE 150MM DIAMETER.

- - - - - FOUL
- - - - - SURFACE WATER
- [Pattern] - EASEMENT

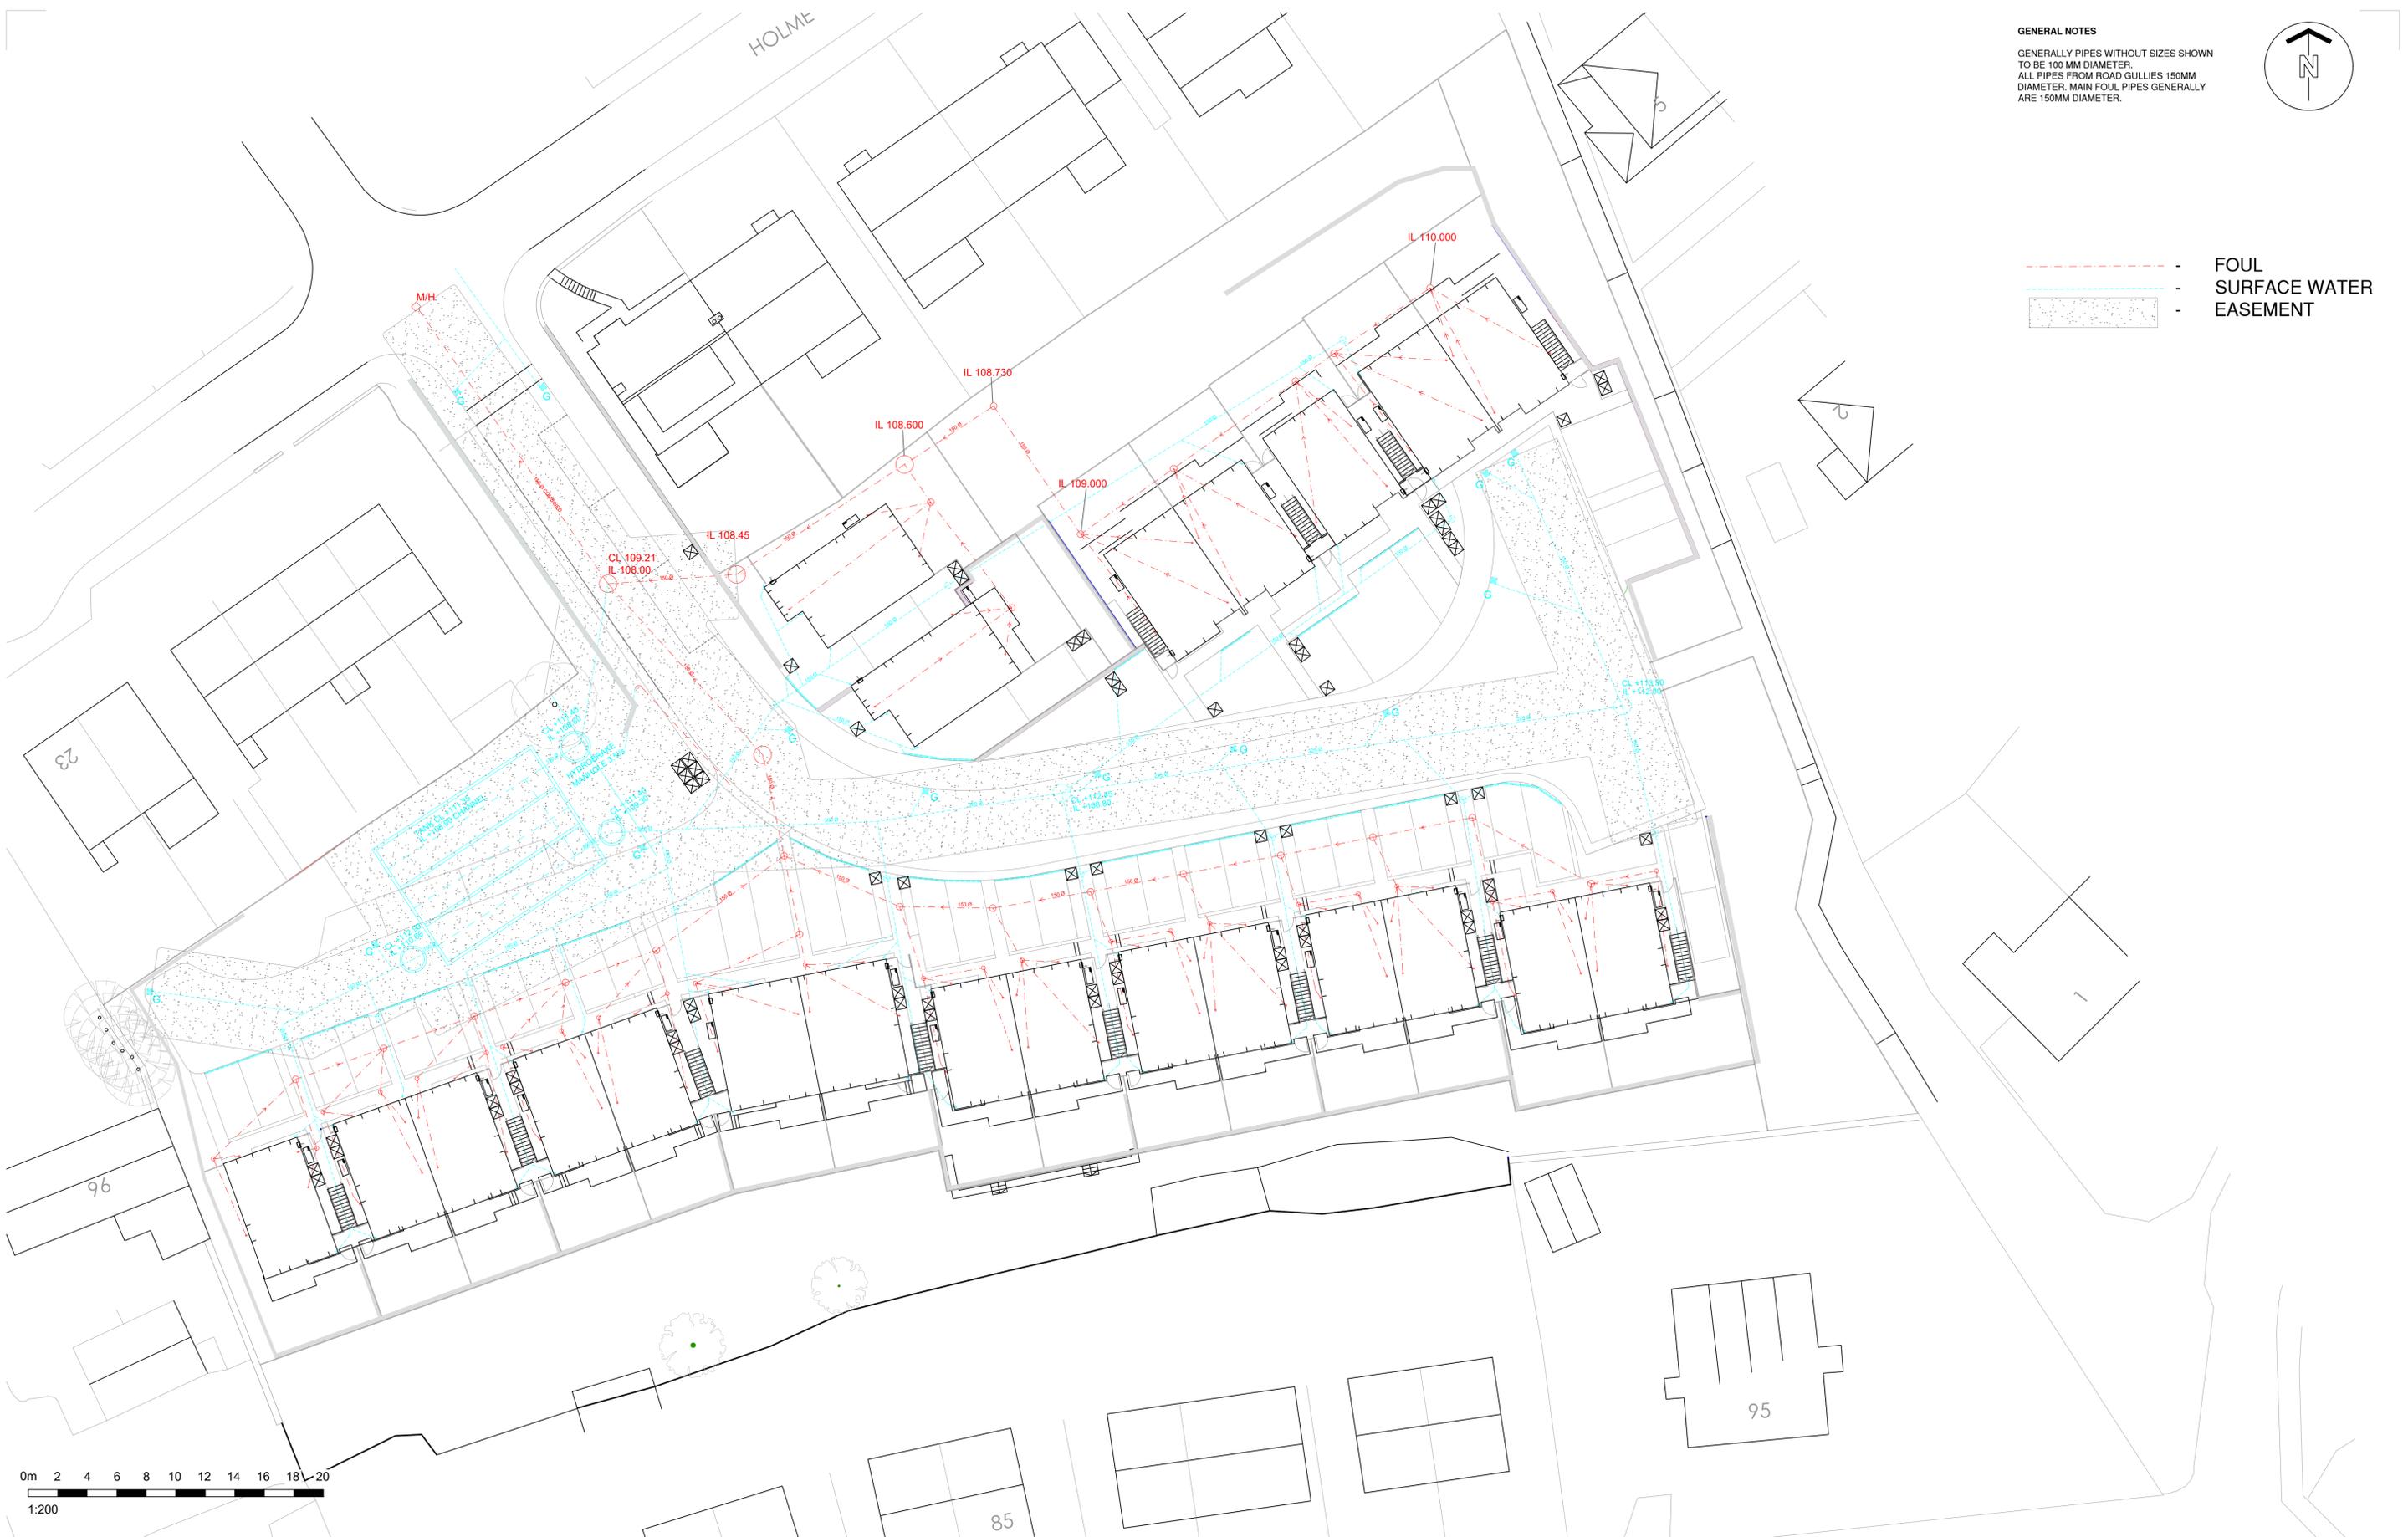

UNLESS STATED OTHERWISE, THE DESIGNS SHOWN ARE SUBJECT TO DETAIL SITE SURVEY AND INVESTIGATIONS AND/OR APPROVAL OF THE RELEVANT VARIOUS LOCAL AUTHORITY OFFICERS, STATUTORY UNDERTAKERS, FIRE OFFICERS AND ENGINEERS. THEY ARE PROJECT AND SITE SPECIFIC.
 THIS DRAWING SHOULD NOT BE SCALED FROM.
 ALL DIMENSIONS SHOULD BE CHECKED ON SITE.
 ANY DRAWING ERRORS OR DISCREPANCIES SHOULD BE REPORTED TO VAUGHAN ARCHITECTURE LTD.
 THIS DRAWING IS THE COPYRIGHT OF VAUGHAN ARCHITECTURE Ltd

DRAWING STATUS			
DRAWN BY: SDC			
SCALE: 1:200			
DATE: July 23			
B	Levels amended to suit site layout plan	07.23	SC RE
C	CL's amended to suit site levels	11.23	JW SC

A1



LEEDS
 LEICESTER
 PONTEFRACT

CLIENT Stonewater.
PROJECT TITLE Holme Avenue, Dalton Huddersfield. HD5 8DP
DRAWING TITLE Drainage Plan

PROJECT NO. VAD.23.14
DRAWING NO. PL 106
REVISION C



Leeds Office | No 2 | Infirmary Street | Leeds | LS1 2JP | 0113 493 1055
Leicester Office | Rutland House | 23-25 Friar Lane | Leicester | LE1 5QQ | 0116 326 8905
Pontefract Office | Pomfret Business Centre | 2 Harropwell Lane | Pontefract | WF8 1QY | 0113 493 1055
 office@vaughanarchitecture.co.uk | www.vaughanarchitecture.co.uk