


Contractor must verify all dimensions on site before commencing any work or shop drawings. If this drawing exceeds the quantities taken in any way, the building designers are to be informed before the work is initiated. Only figured dimensions to be taken from this drawing. Do not scale off this drawing. Drawing based on Ordnance Survey and/or existing record drawings - design and drawing content subject to Site Survey, Structural Survey, Site Investigations, Planning and Statutory Requirements and Approvals. All drainage layouts are schematic and invert levels must be established prior to construction.

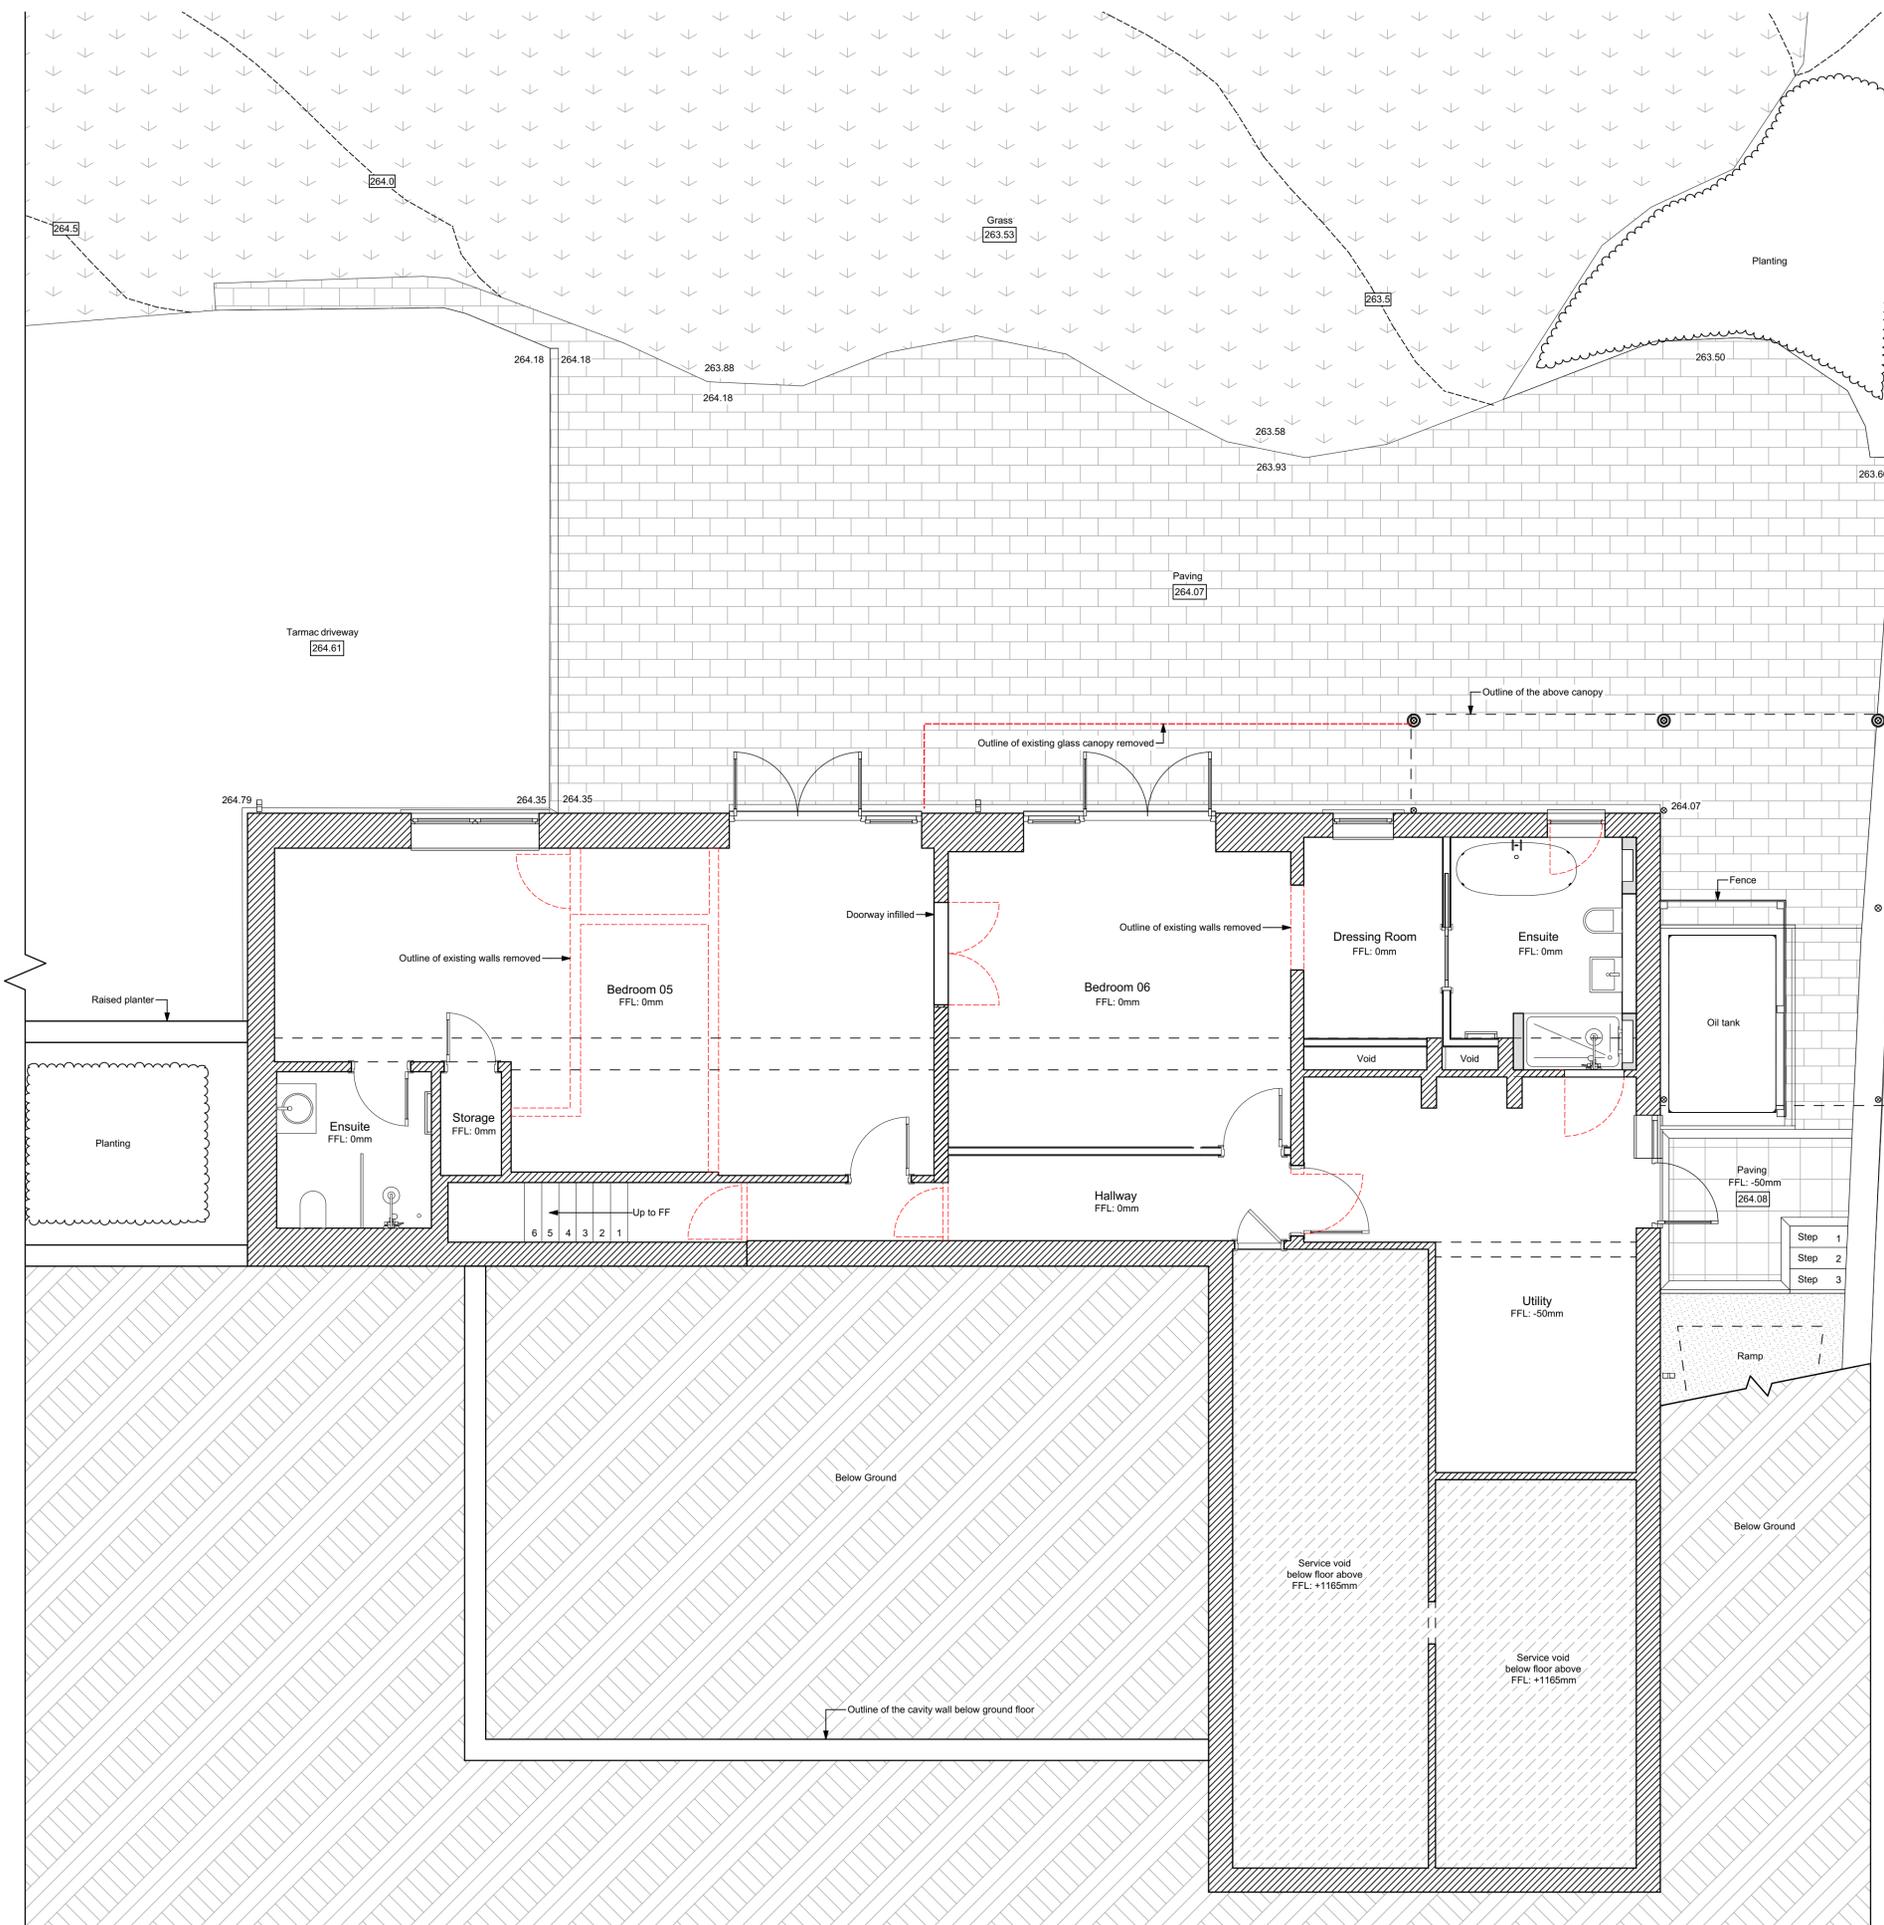

Proposed Ground Floor Plan 1:50

Project Status: PLANNING ONLY



4 Rushmead Court, Ossett, WF5 0NZ
tel: 01924 275 594
web: www.transformarchitects.co.uk email: info@transformarchitects.co.uk

Project Address: Strines Lodge
High Flatts
Birdsedge
Huddersfield
HD8 8XU

Client: Ms I Dewes

Drawing Title: Proposed Ground Floor Plan A1

Scale: 1:50

Date: 10.08.2023

Drawn By: MNB

Drawing Number: T1168 - PL16

Revision: Nil