


DO NOT SCALE, IF IN DOUBT ASK, DO NOT INTERROGATE CAD BASE

KEY:	
EX P SW	XX0, Xm @ 1X
CL:	EXISTING PRIVATE SURFACE WATER MH & DRAINAGE RUN
IL:	
EX P FW	XX0, Xm @ 1X
CL:	EXISTING PRIVATE SURFACE WATER MH & DRAINAGE RUN
IL:	
	EXISTING SURFACE GULLY
EX RE	EXISTING SURFACE RODDING EYE
EX RWP	EXISTING RAINWATER PIPE

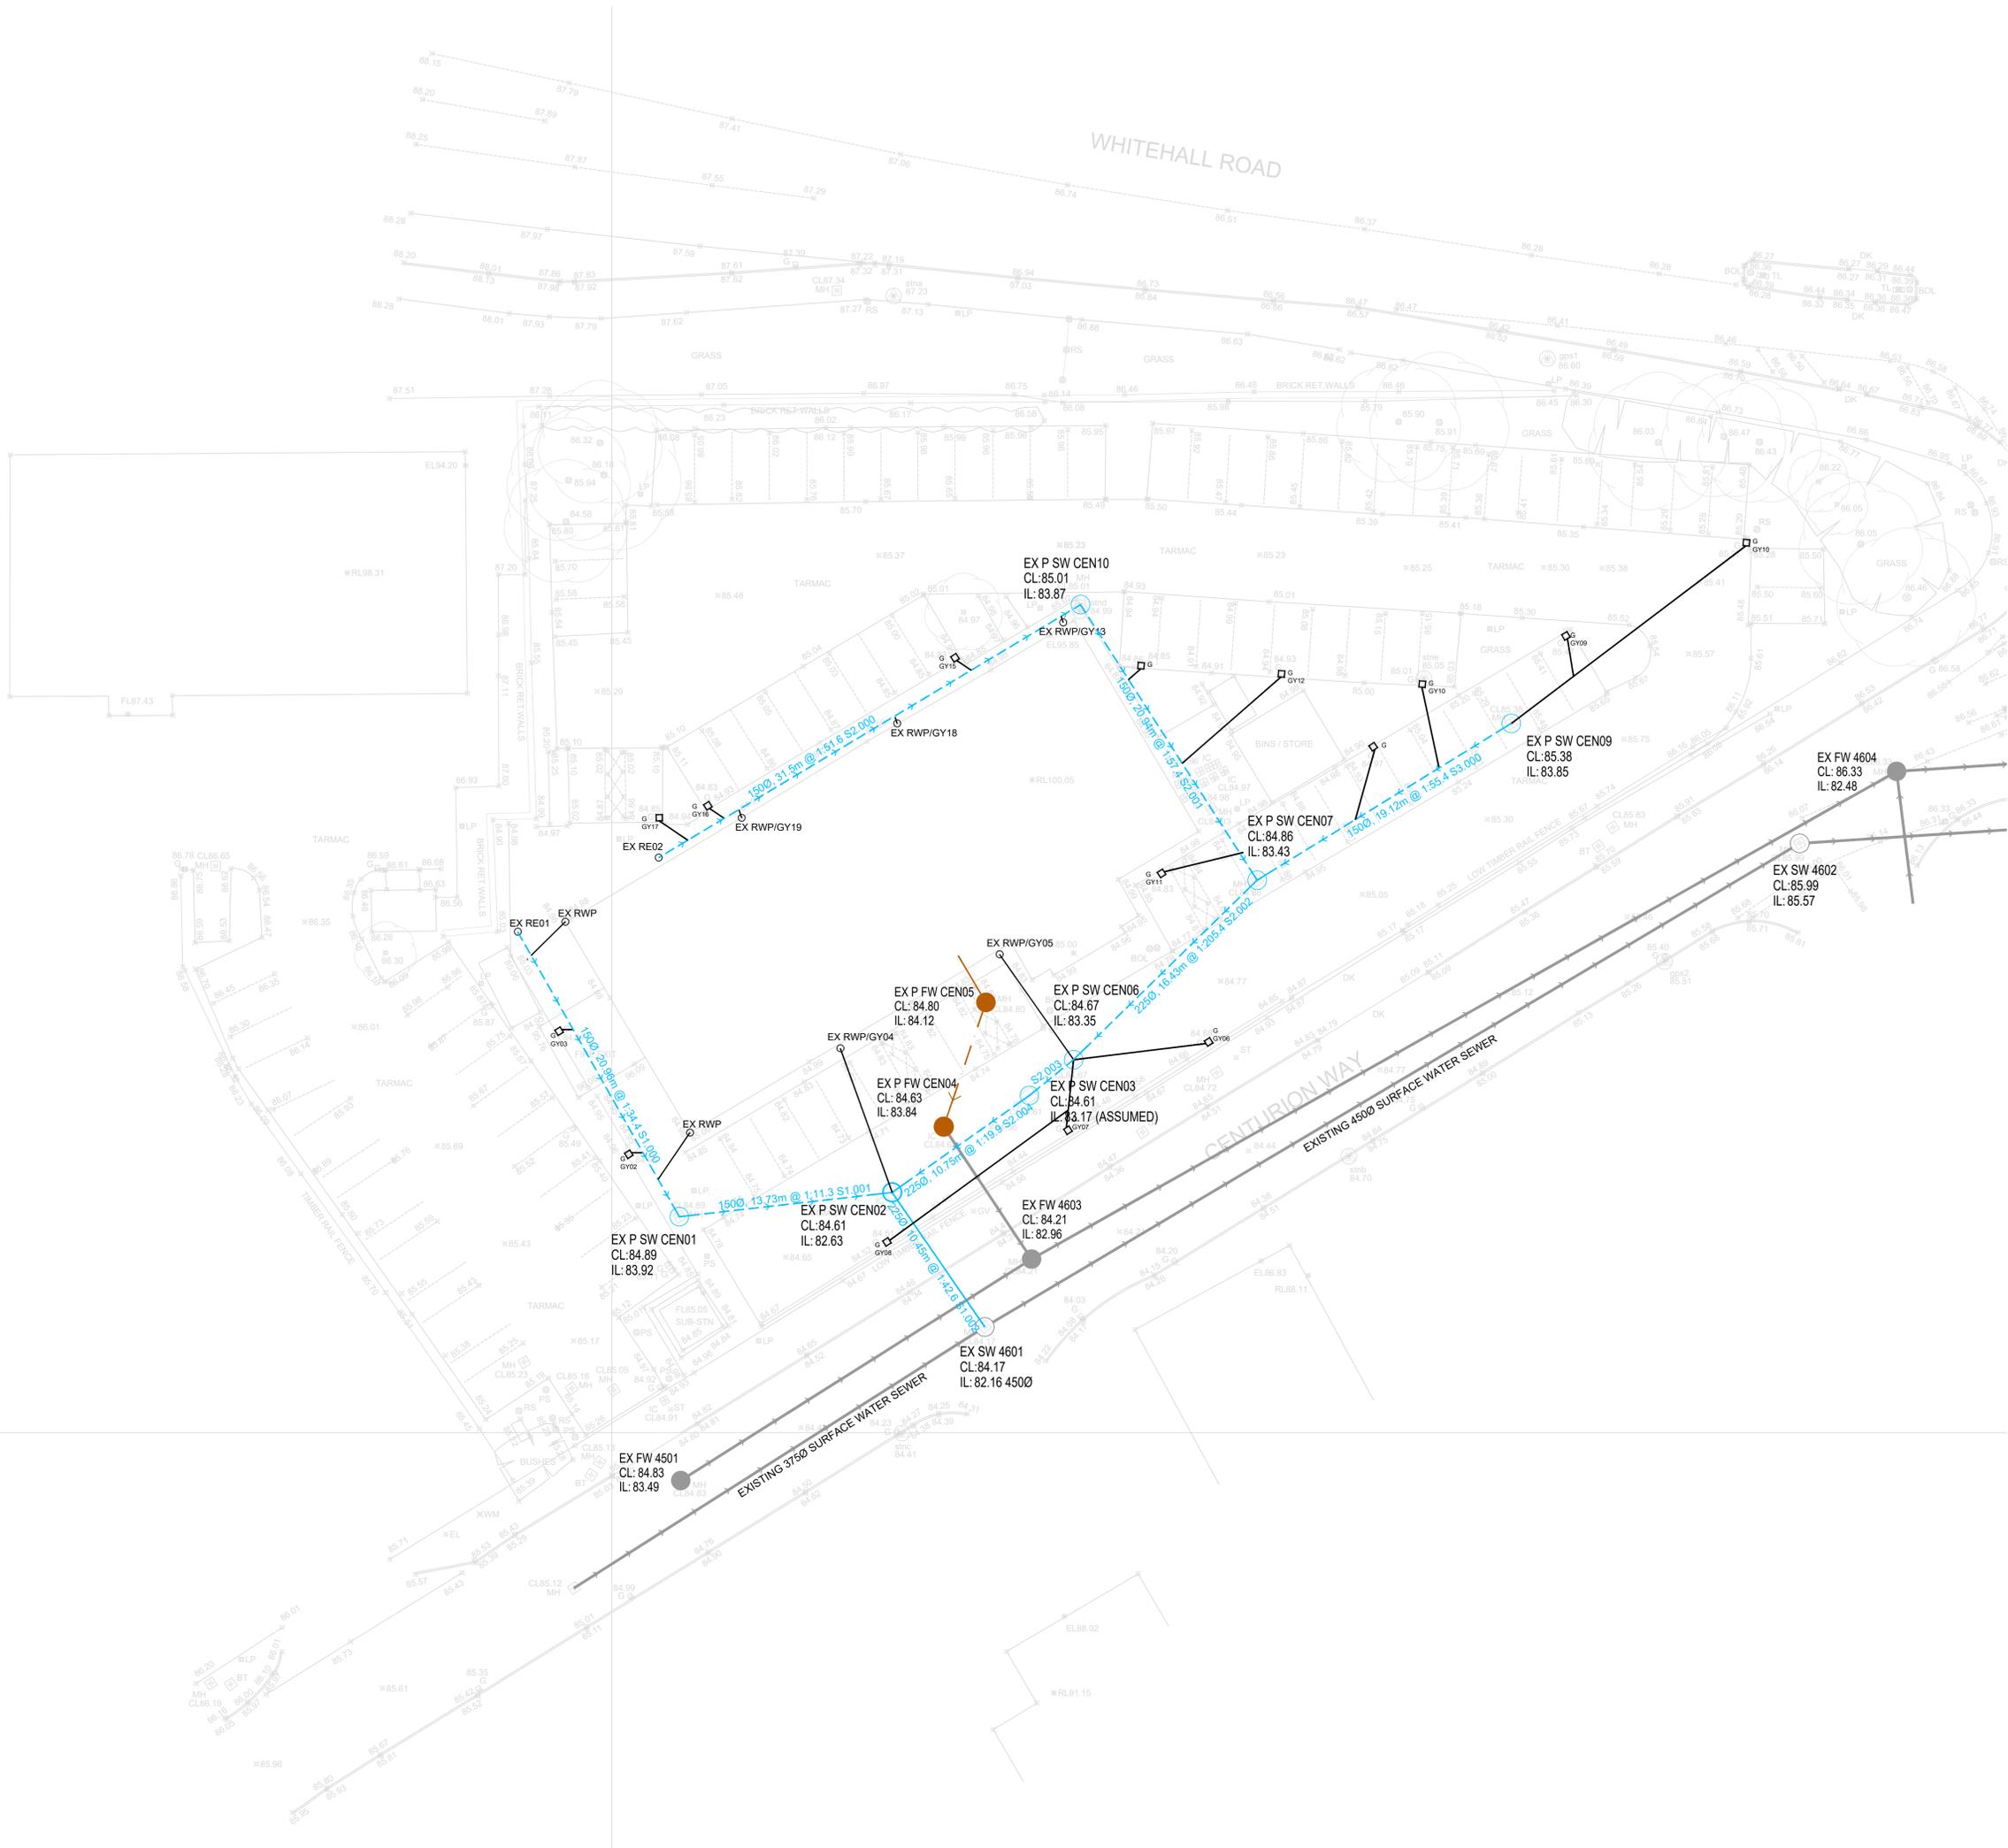

REV.	DATE	REVISION	BY	CHK
-		FIRST ISSUE	PH	NB

Euro Garages Ltd
 Proposed PFS & Drive 'Thru' Restaurant
 Centurion Way, Cleckheaton

Existing Drainage Layout Plan

Goodson Associates
 Consulting Civil, Structural & Transportation Engineers
 Fountain House, 4 South Parade,
 Leeds, LS1 5QX
 Also at Aberdeen, Edinburgh and Glasgow.

Tel: +44 (0)113 369 7925
 Fax: -
 Email: leeds@goodsons.com
 Web: www.goodsons.com

PLANNING

DATE CREATED:	June '22'	SCALE:	1:200 @ A1
CONTRACT No:	PI5622	DRAWING No:	502
REV:			-