





Ordnance Survey, (c) Crown Copyright 2024. All rights reserved. Licence number 100022432

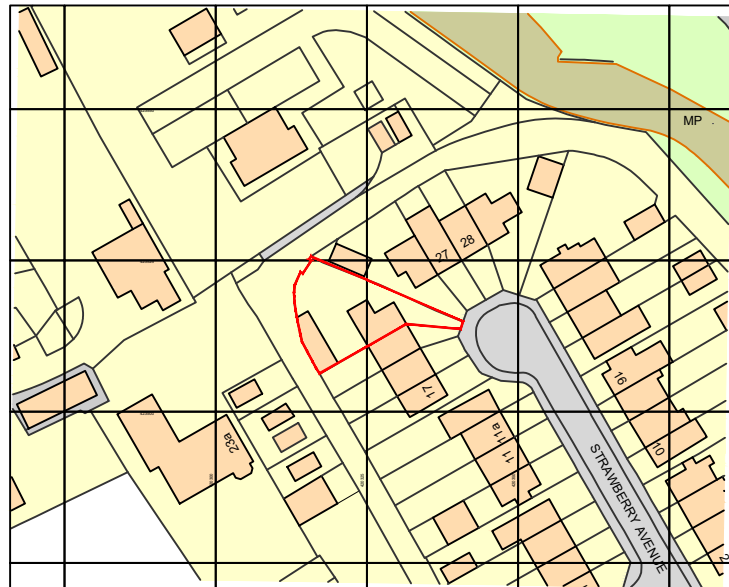


LOCATION PLAN 1:1250



EXISTING SITE PLAN 1:500

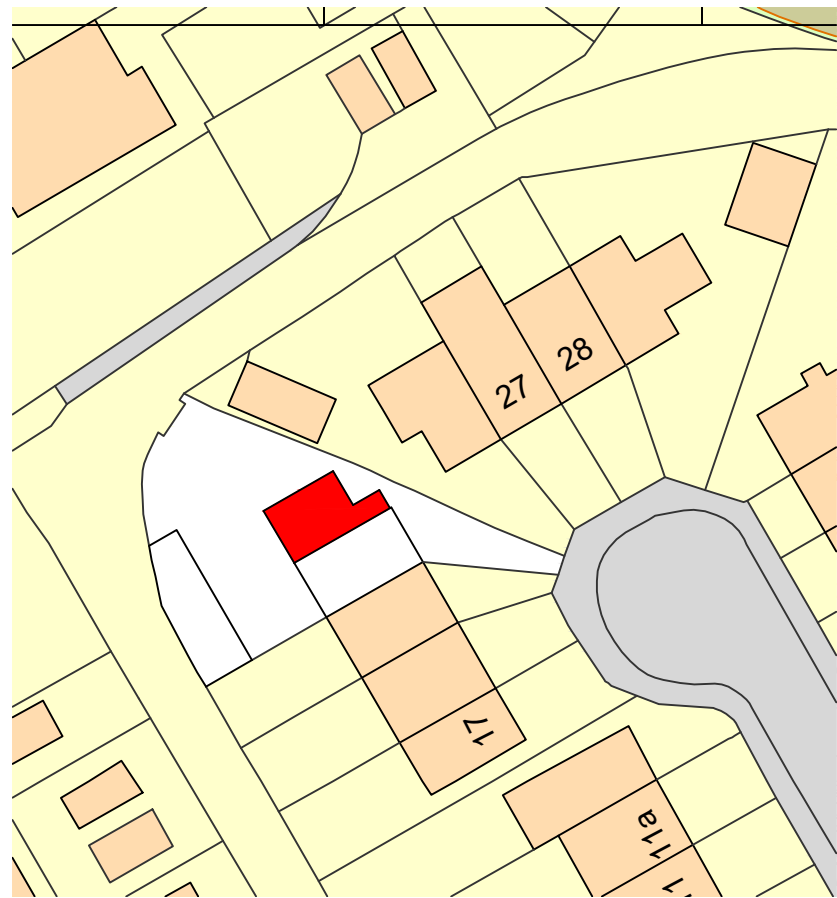

PROPOSED SITE PLAN 1:500

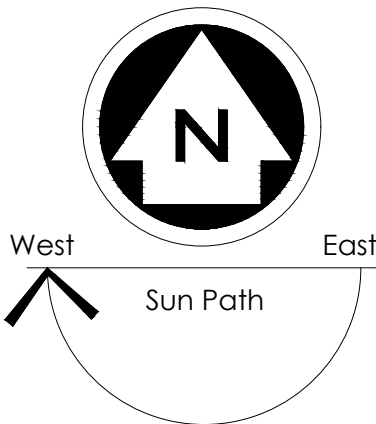

PLANNING ONLY PLANS
NOT TO BE USED FOR CONSTRUCTION

NOTES

ALL DIMENSIONS TO BE CHECKED ON SITE
ALL SUBJECT TO STRUCTURAL
ENGINEERS CHECKS AND
CALCULATIONS
TO BE READ IN CONJUNCTION
WITH CONSTRUCTION SPECIFICATION
DO NOT SCALE FROM THIS DRAWING
EXCEPT FOR THE PURPOSES OF LOCAL
AUTHORITY PLANNING
IF ANY VARIATIONS ARE MADE TO
SPECIFICATION/DRAWINGS WITHOUT DK
DESIGNS KNOWLEDGE, DK DESIGNS WILL
NOT BE HELD ACCOUNTABLE FOR NON
COMPLIANCE OF PLANNING AND BUILDING
REGULATIONS
This drawing and all the information
shown is the property of DK Designs and
shall not be copied whole, or in part, or
used for any other purpose without written
permission of the Company

DK DESIGNS
FUTURE PROJECTS TODAY

7A HAYWOOD HOUSE, HYDRA BUSINESS PARK
NETHER LANE
SHEFFIELD
S35 1ZX
TEL OFFICE:- 07591 206852
WEB:- WWW.DK-DESIGNS.CO.UK
EMAIL :- DESIGNS@DK-DESIGNS.CO.UK


Client:
Karl Mahoney

23 Strawberry Avenue, Liversedge
LOCATION AND SITE PLANS


Scales: 1:1250 1:500 @ A3	Date: JAN 2024
Drawing Number: 2024-007-001	Revision: A Drawn by: DCK/KLU

A 23.02.2024 Reduction as planning requested		
Rev.	Date.	Remarks


EXISTING

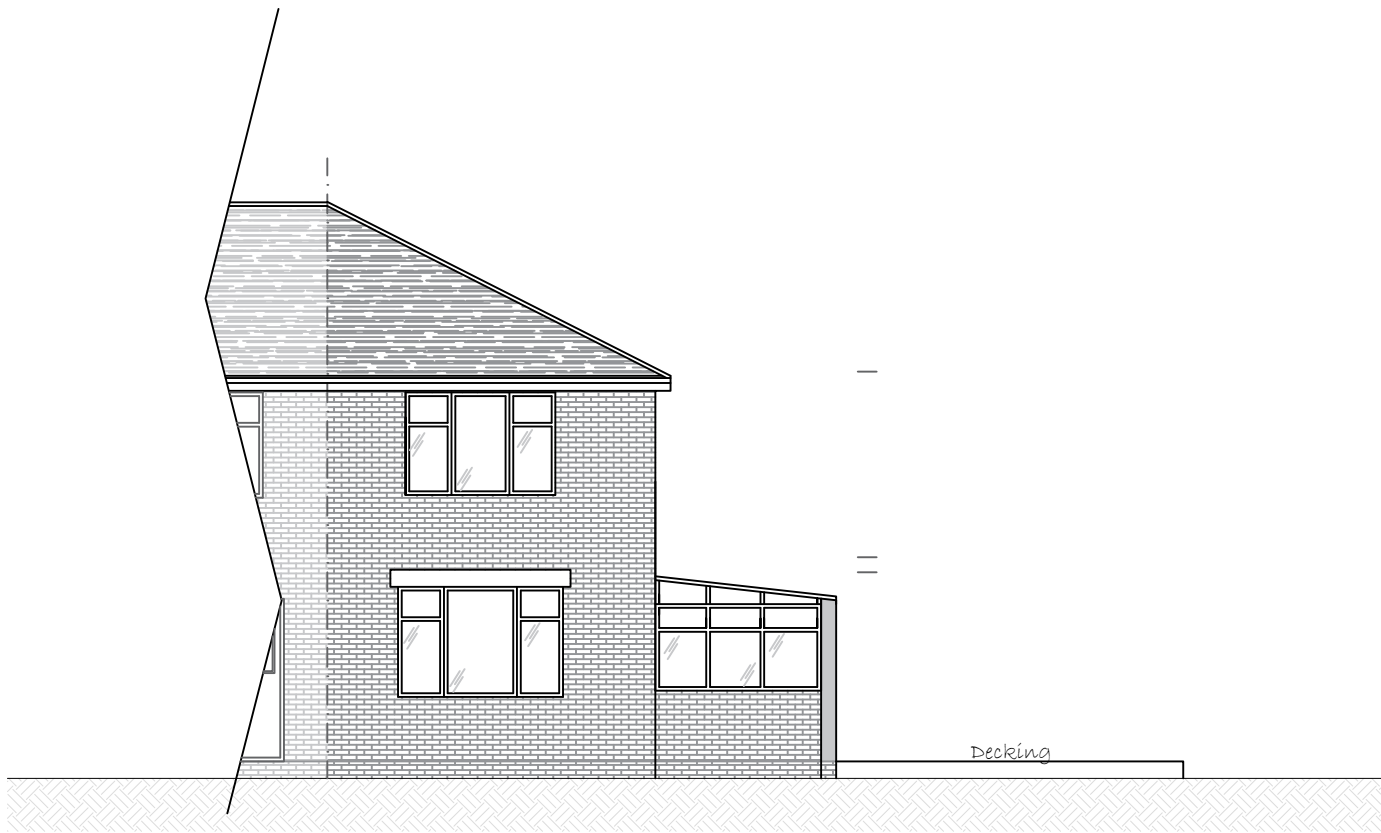


Front Elevation

 

Side Elevation

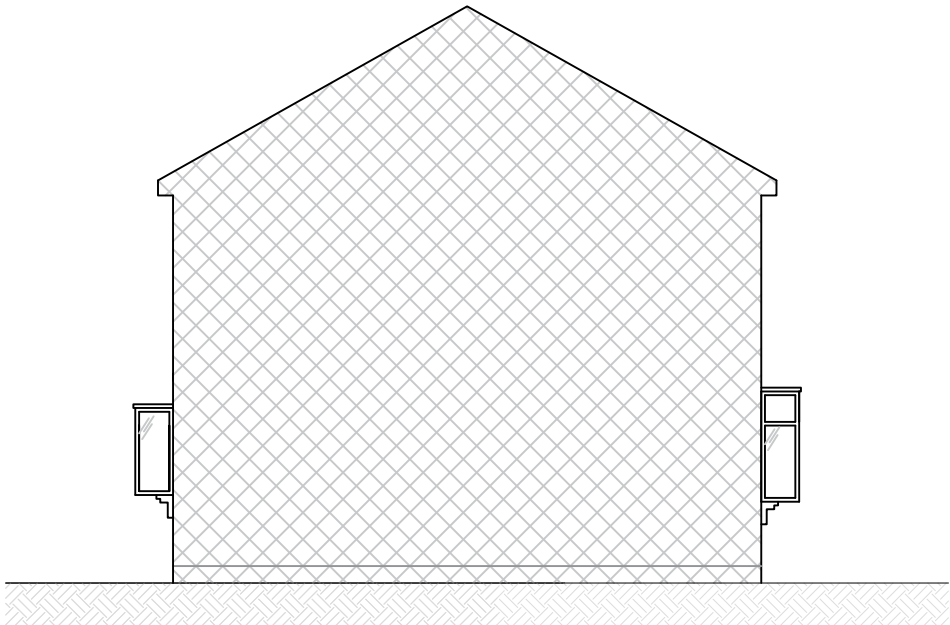


Side Elevation

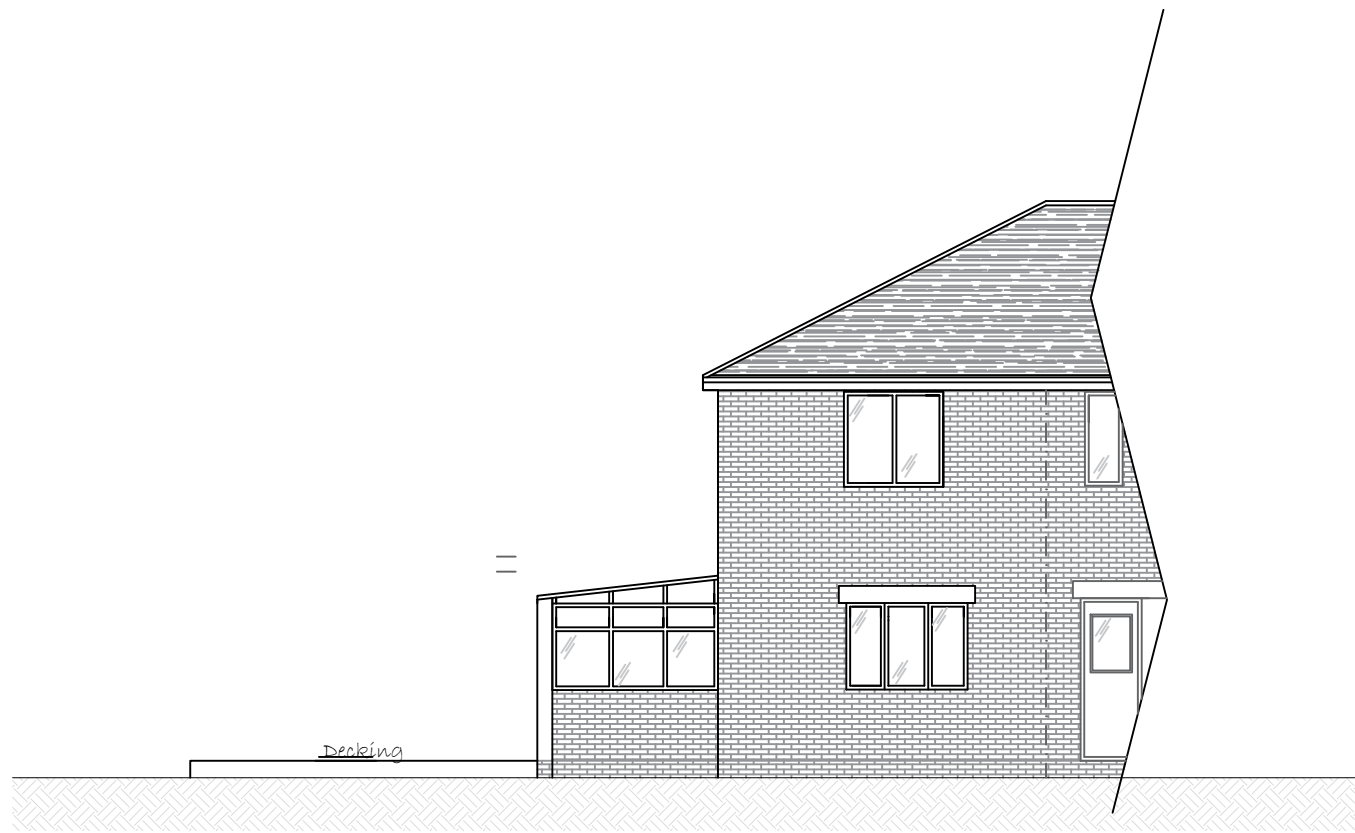


Rear Elevation

PLANNING ONLY PLANS

NOT TO BE USED FOR CONSTRUCTION

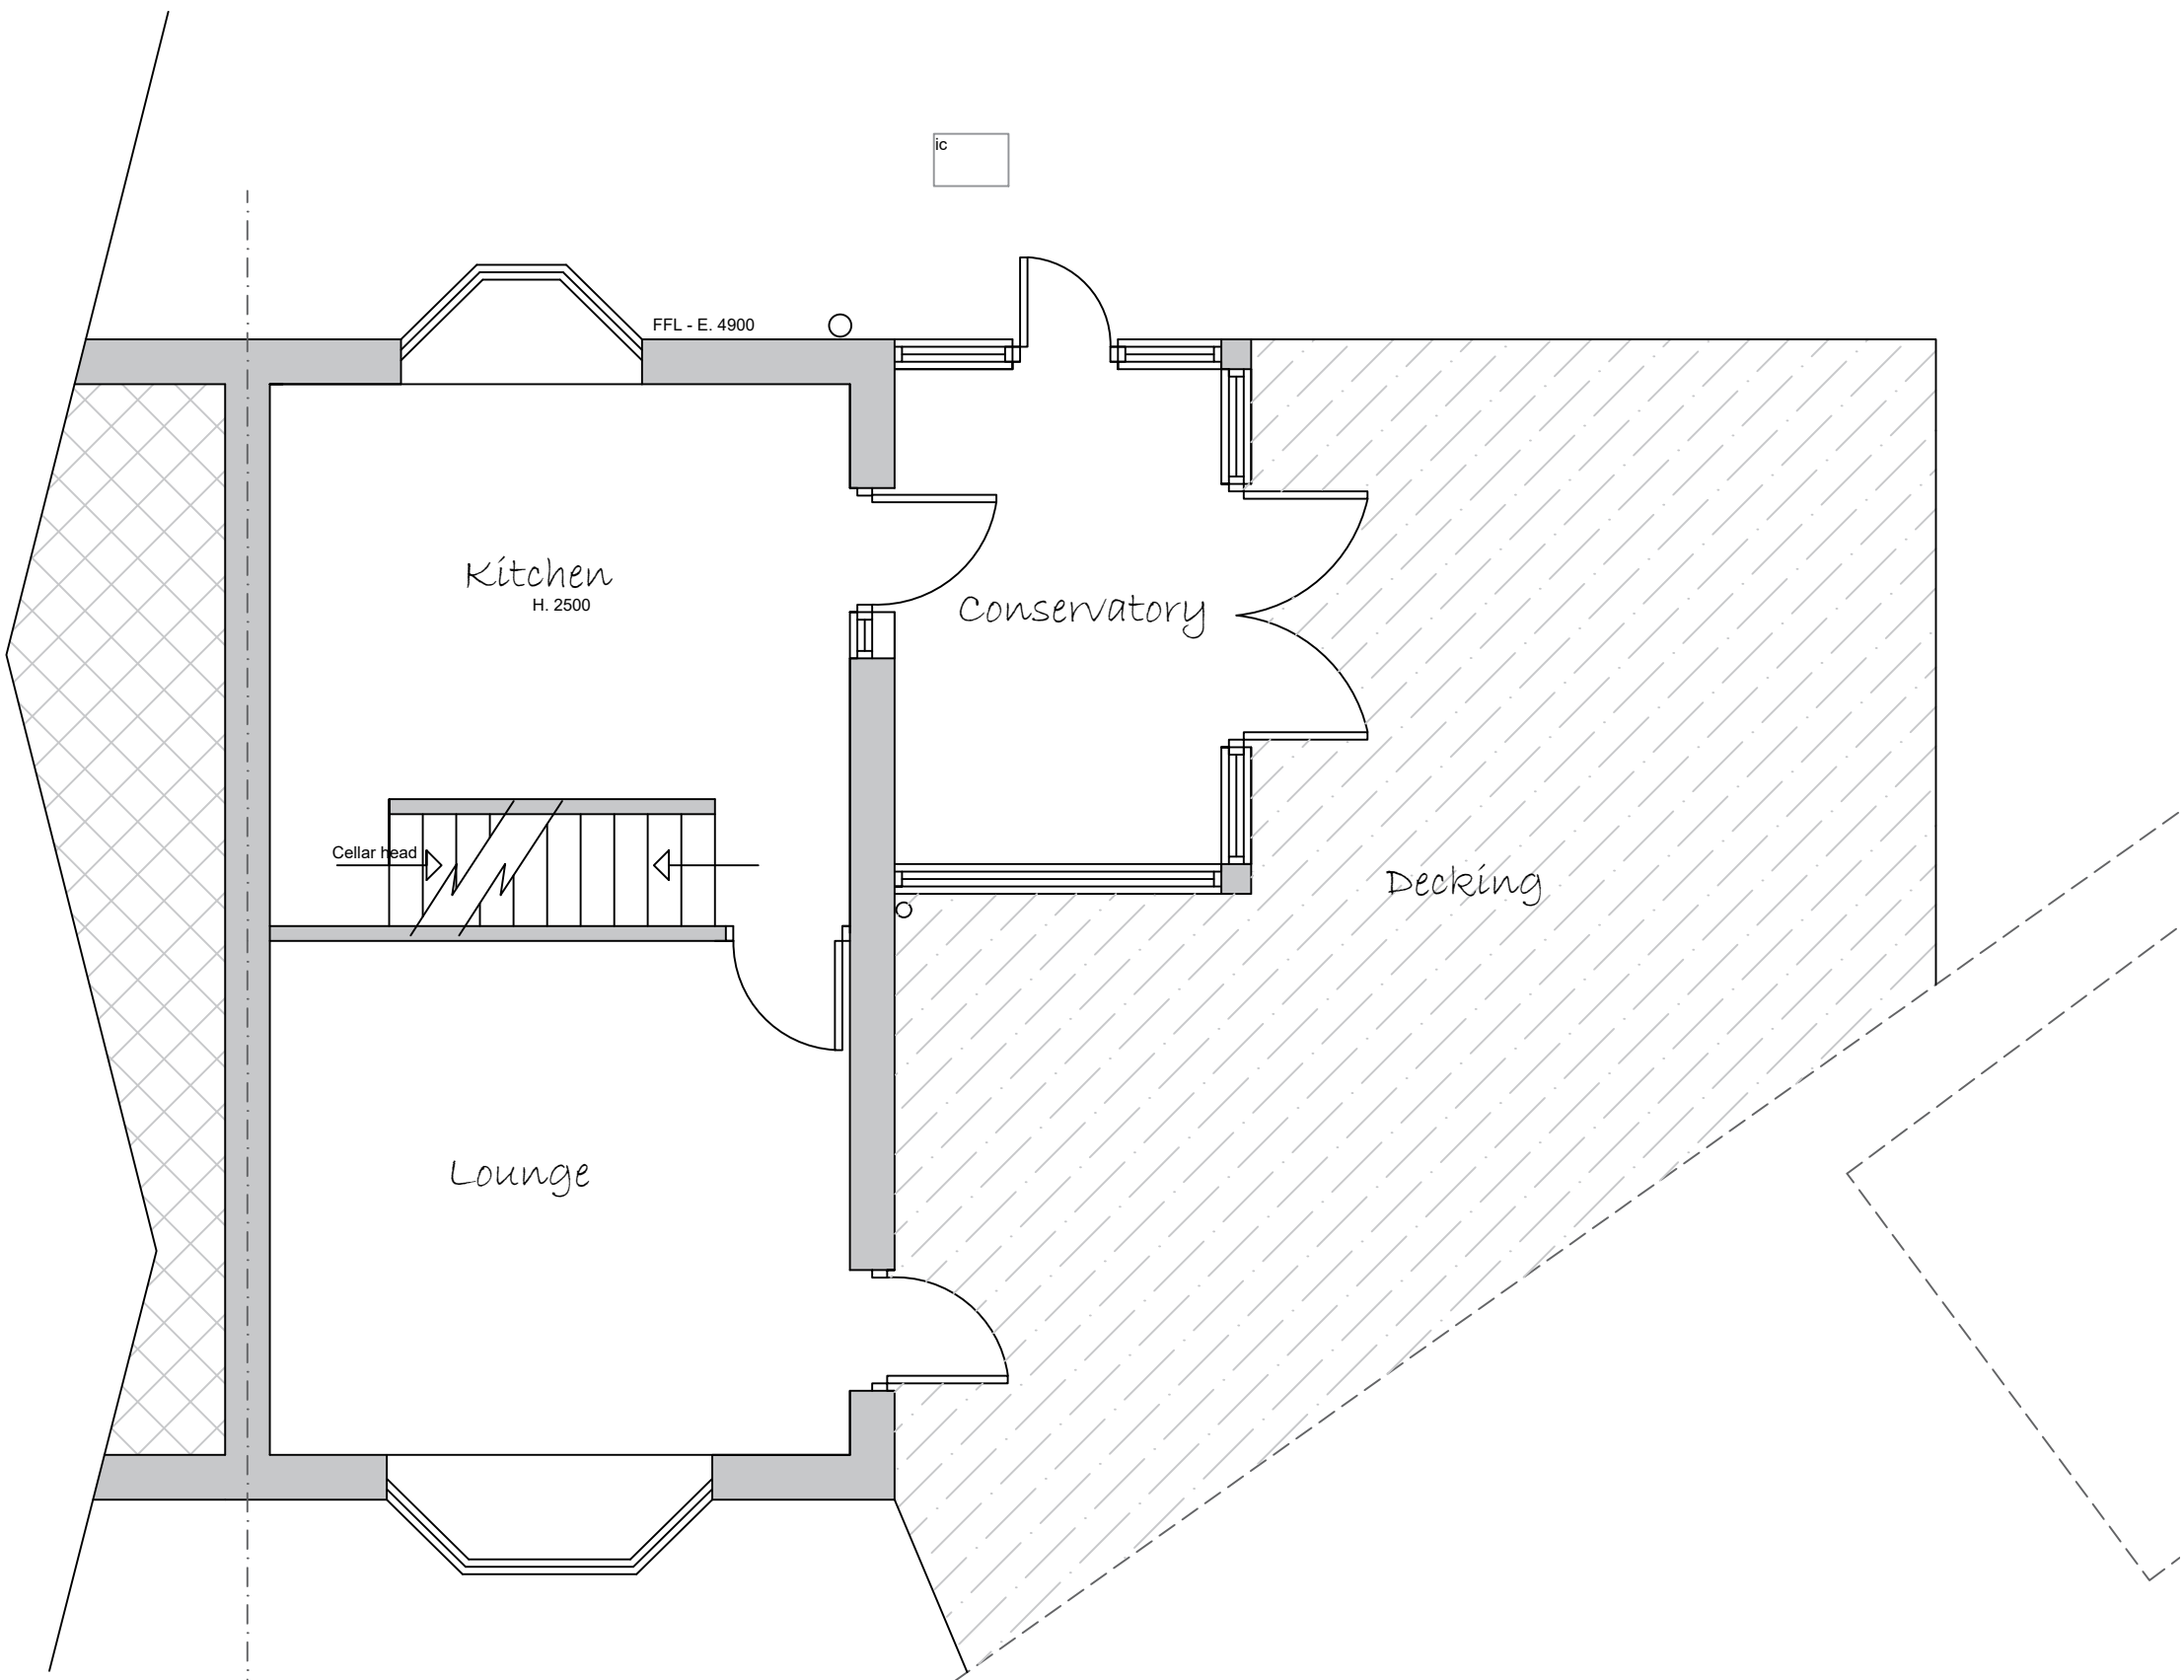

Ground Floor Plan

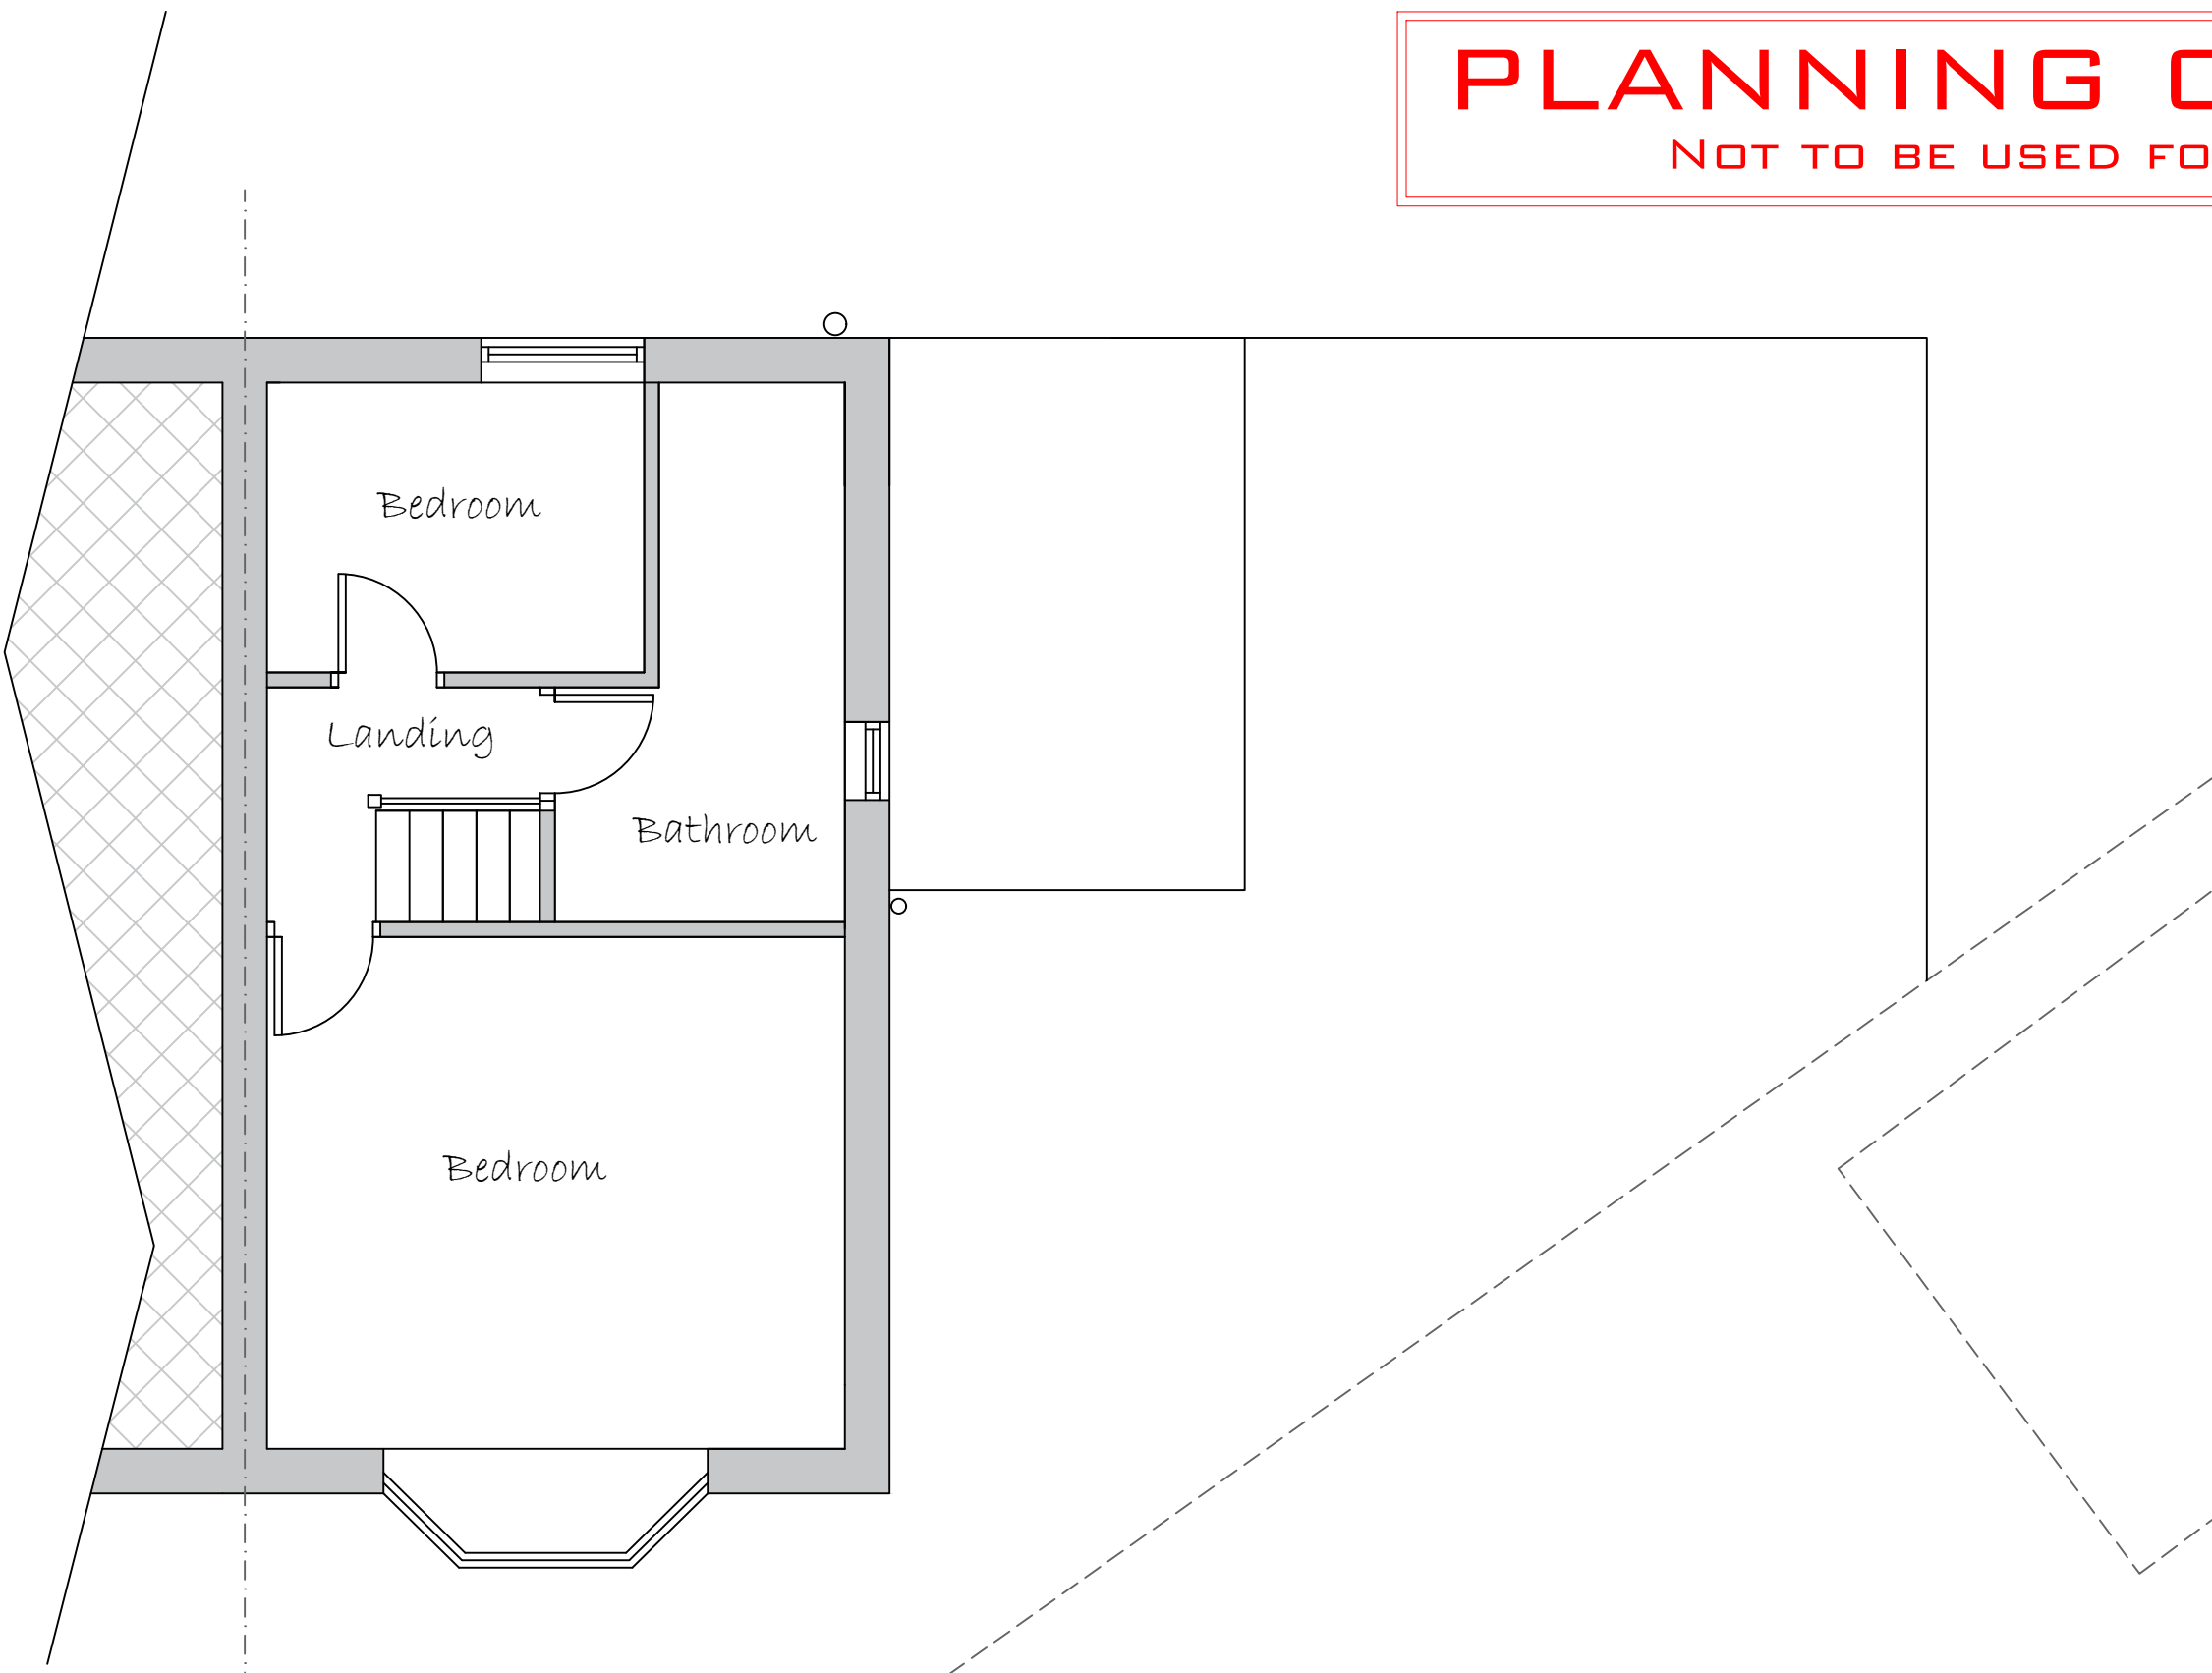

First Floor Plan



Wall Key

- New External Wall
- New Internal Stud Walls

Materials

- Brick
- Roof Tiles
- New Glazing

Electrical and Heating

To clients spec

- Pendant Light
- Spot Light
- External Light
- Switch. (All switches 1200mm above floor)
- Double 13 Amp sockets, 450mm min. above floor.
- Double 13 Amp sockets, 1050mm min. above floor.
- T.V aerial socket.(H.L denotes 1050mm high)
- Smoke detector wired permanently to a separately fused circuit.
- Carbon Monoxide Detector to BS EN 50291.2001
- Heat Detector
- Mechanical extract fan
- External Tap
- External 13 Amp sockets, 450mm min. above floor.
- Radiator position.

NOTES

ALL DIMENSIONS TO BE CHECKED ON SITE
ALL SUBJECT TO STRUCTURAL
ENGINEERS CHECKS AND
CALCULATIONS
TO BE READ IN CONJUNCTION
WITH CONSTRUCTION SPECIFICATION
DO NOT SCALE FROM THIS DRAWING
EXCEPT FOR THE PURPOSES OF LOCAL
AUTHORITY PLANNING
IF ANY VARIATIONS ARE MADE TO
SPECIFICATION/DRAWINGS WITHOUT DK
DESIGNS KNOWLEDGE, DK DESIGNS WILL
NOT BE HELD ACCOUNTABLE FOR NON
COMPLIANCE OF PLANNING AND BUILDING
REGULATIONS
This drawing and all the information
shown is the property of DK Designs and
shall not be copied whole, or in part, or
used for any other purpose without written
permission of the Company

DK DESIGNS
FUTURE PROJECTS TODAY

7A HAYWOOD HOUSE, HYDRA BUSINESS PARK
NETHER LANE
SHEFFIELD
S35 1ZX
TEL OFFICE:- 07591 206852
WEB:- WWW.DK-DESIGNS.CO.UK
EMAIL :- DESIGNS@DK-DESIGNS.CO.UK

Client

Karl Mahoney

23 Strawberry Avenue, Liversedge
EXISTING FLOOR PLANS & ELEVATIONS

Scales

1:50 1:100 @ A1

Drawing Number:
2024-007-002

Revision

-


Date

JAN 2024

Drawn by

DCK/KLU


PROPOSED

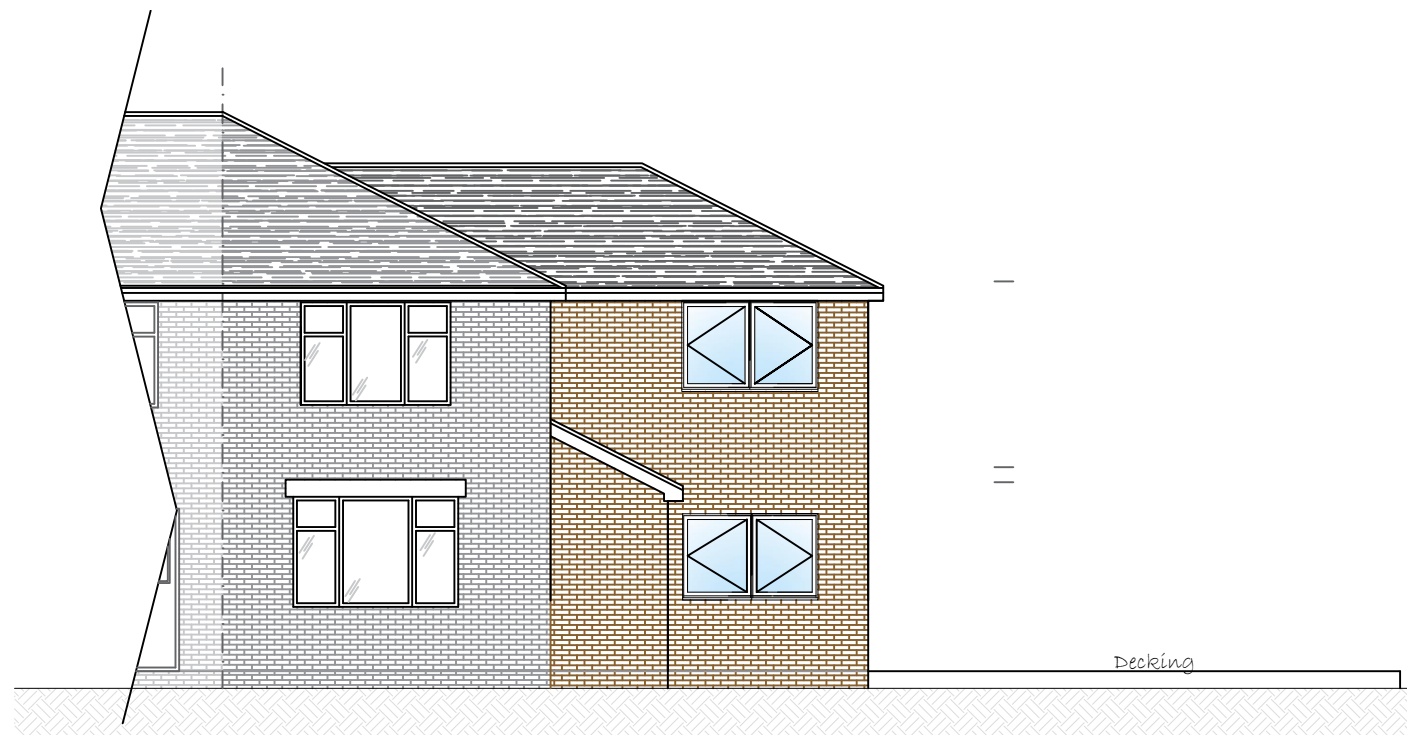


Front Elevation




Side Elevation

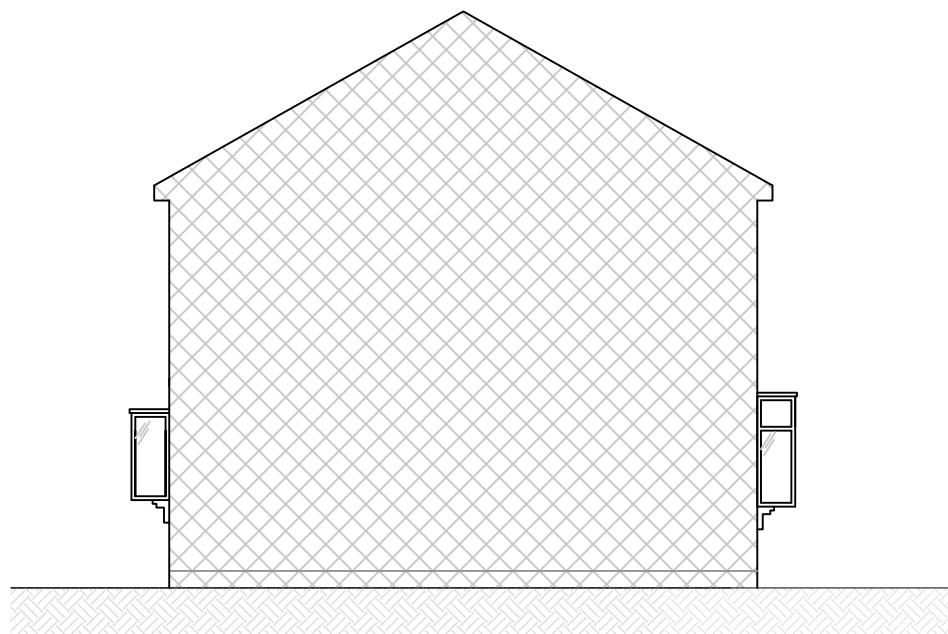


Side Elevation

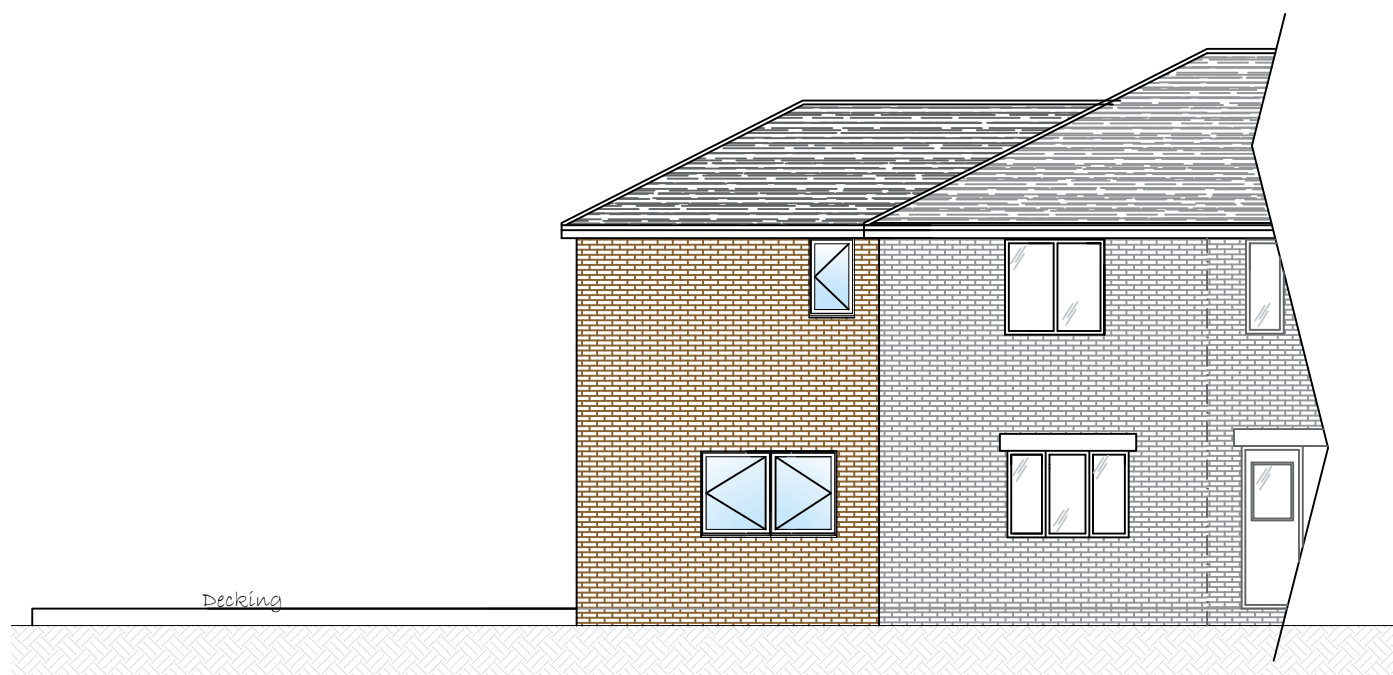

Rear Elevation

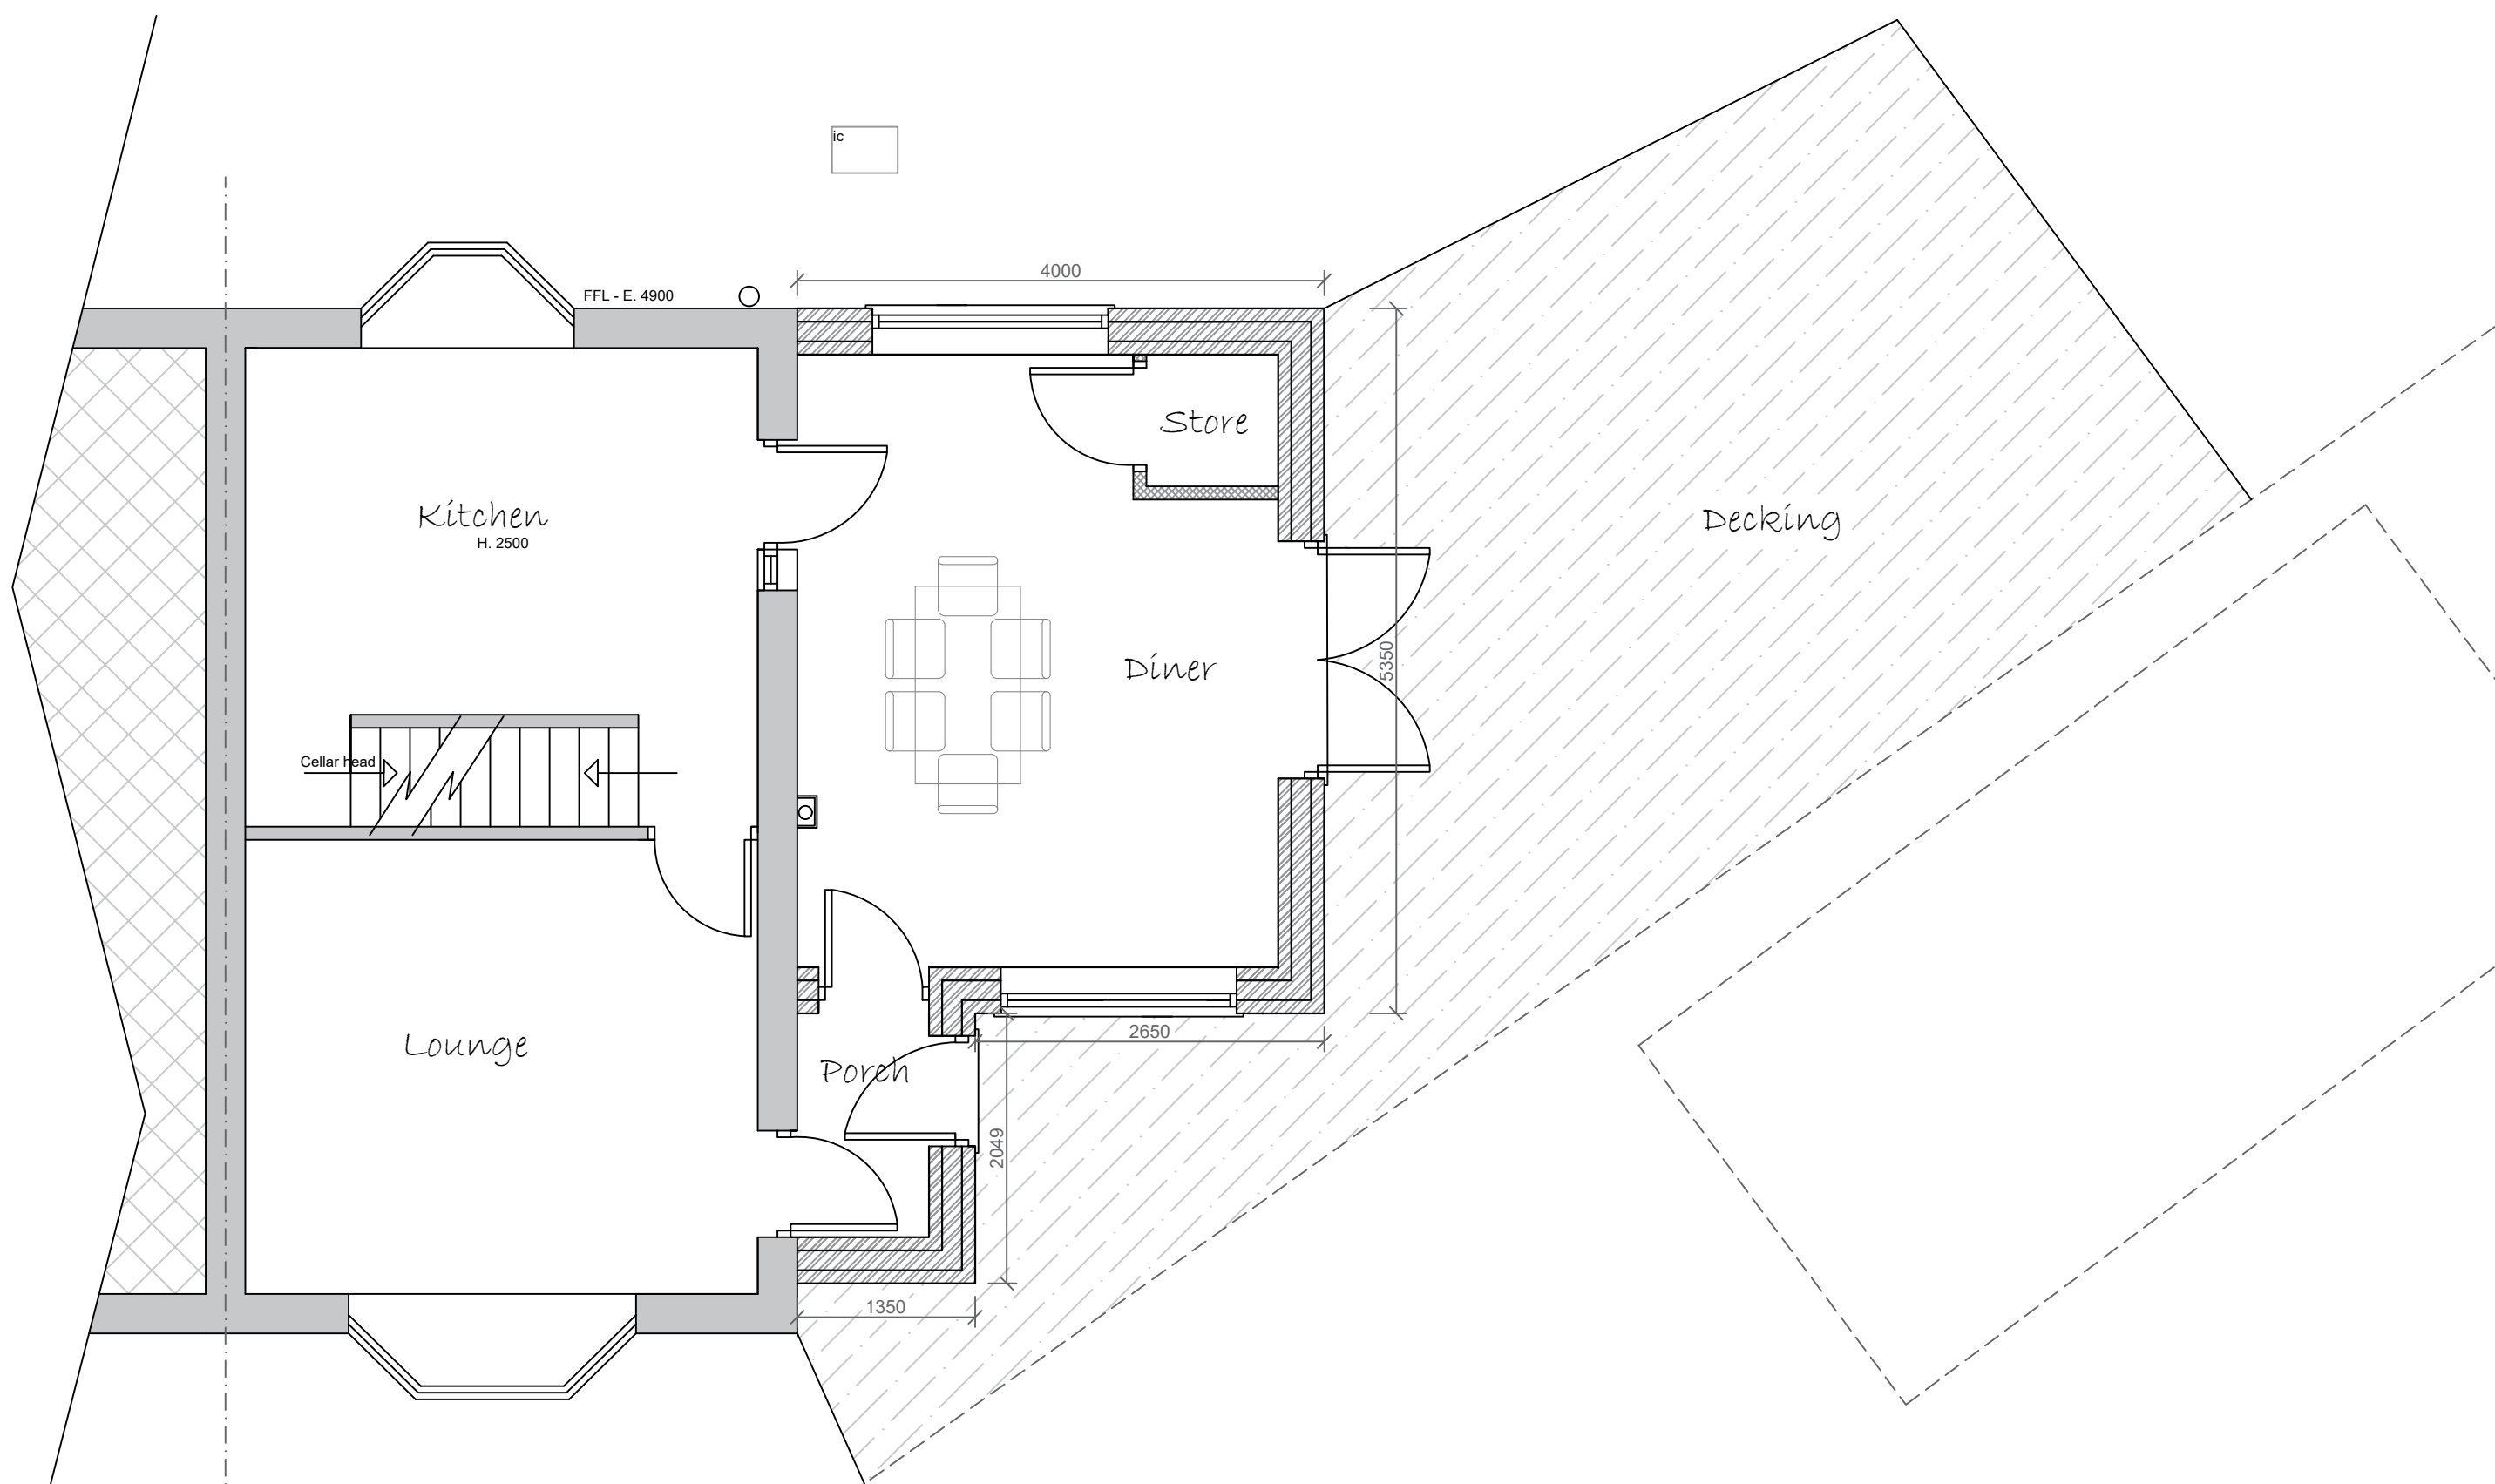

Ground Floor Plan

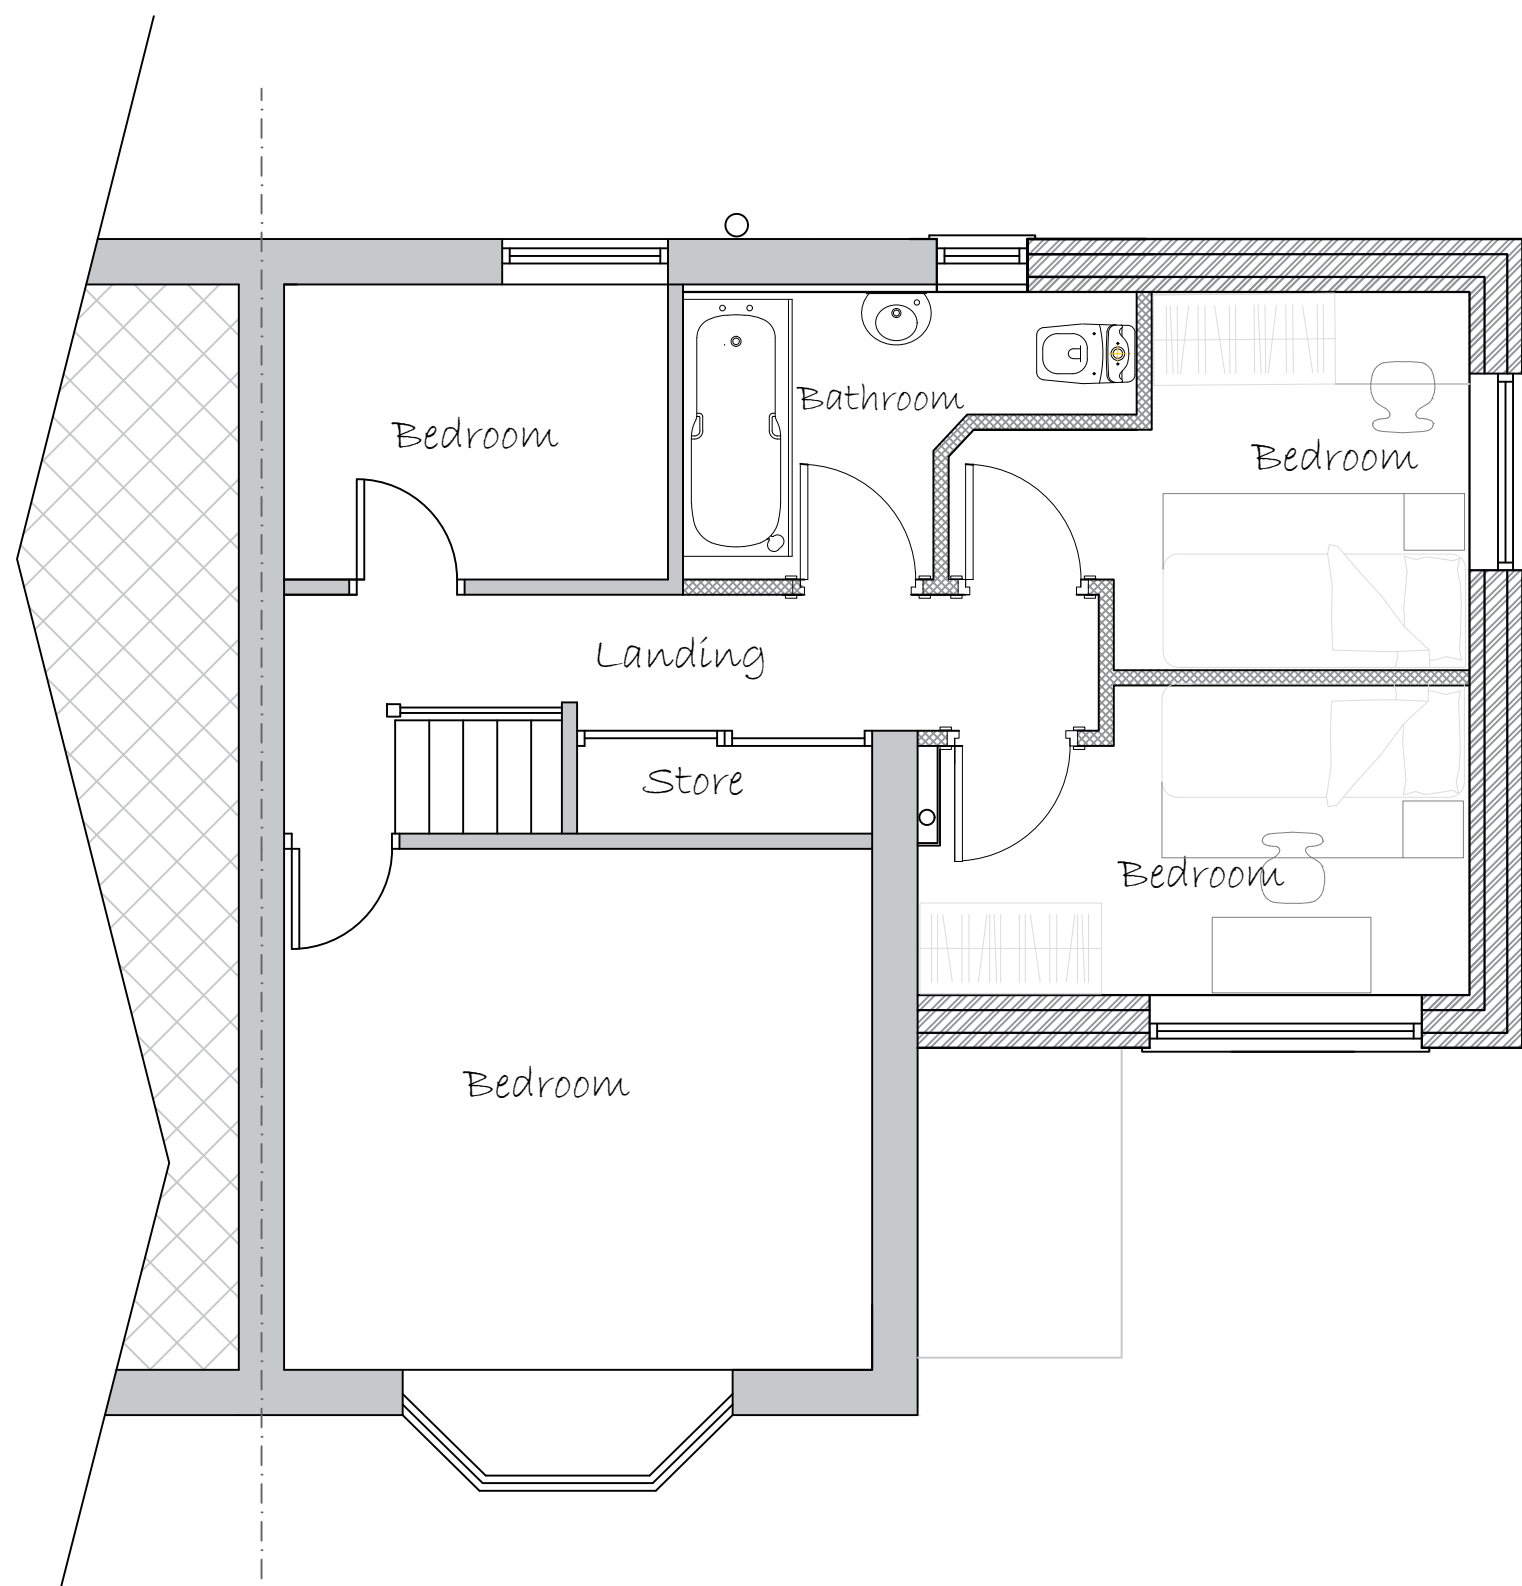

First Floor Plan



PLANNING ONLY PLANS
NOT TO BE USED FOR CONSTRUCTION

A 23.02.2024 Reduction as planning requested

Rev.	Date.	Remarks
------	-------	---------

Wall Key

New External Wall
New Internal Stud Walls

Materials

Brick
Roof Tiles
New Glazing

Electrical and Heating To clients spec

Pendant Light
Spot Light
External Light
Switch. (All switches 1200mm above floor)
Double 13 Amp sockets, 450mm min. above floor.
Double 13 Amp sockets, 1050mm min. above floor.
T.V aerial socket.(H.L denotes 1050mm high)
Smoke detector wired permanently to a separately fused circuit.
Carbon Monoxide Detector to BS EN 50291:2001
Heat Detector
Mechanical extract fan
External Tap
External 13 Amp sockets, 450mm min. above floor.
Radiator position.

NOTES

ALL DIMENSIONS TO BE CHECKED ON SITE
ALL SUBJECT TO STRUCTURAL ENGINEERS CHECKS AND CALCULATIONS
TO BE READ IN CONJUNCTION WITH CONSTRUCTION SPECIFICATION
DO NOT SCALE FROM THIS DRAWING EXCEPT FOR THE PURPOSES OF LOCAL AUTHORITY PLANNING
IF ANY VARIATIONS ARE MADE TO SPECIFICATION/DRAWINGS WITHOUT DK DESIGNS KNOWLEDGE, DK DESIGNS WILL NOT BE HELD ACCOUNTABLE FOR NON COMPLIANCE OF PLANNING AND BUILDING REGULATIONS
This drawing and all the information shown is the property of DK Designs and shall not be copied whole, or in part, or used for any other purpose without written permission of the Company

DK DESIGNS
FUTURE PROJECTS TODAY

7A HAYWOOD HOUSE, HYDRA BUSINESS PARK
NETHER LANE
SHEFFIELD
S35 1ZX
TEL OFFICE:- 07591 206852
WEB:- WWW.DK-DESIGNS.CO.UK
EMAIL :- DESIGNS@DK-DESIGNS.CO.UK

Client: Karl Mahoney

23 Strawberry Avenue, Liversedge
PROPOSED FLOOR PLANS & ELEVATIONS

Scale: 1:50 1:100 @ A1

Drawing Number: 2024-007-003

Revision: A

Date: JAN 2024

Drawn by: DCK/KLU