



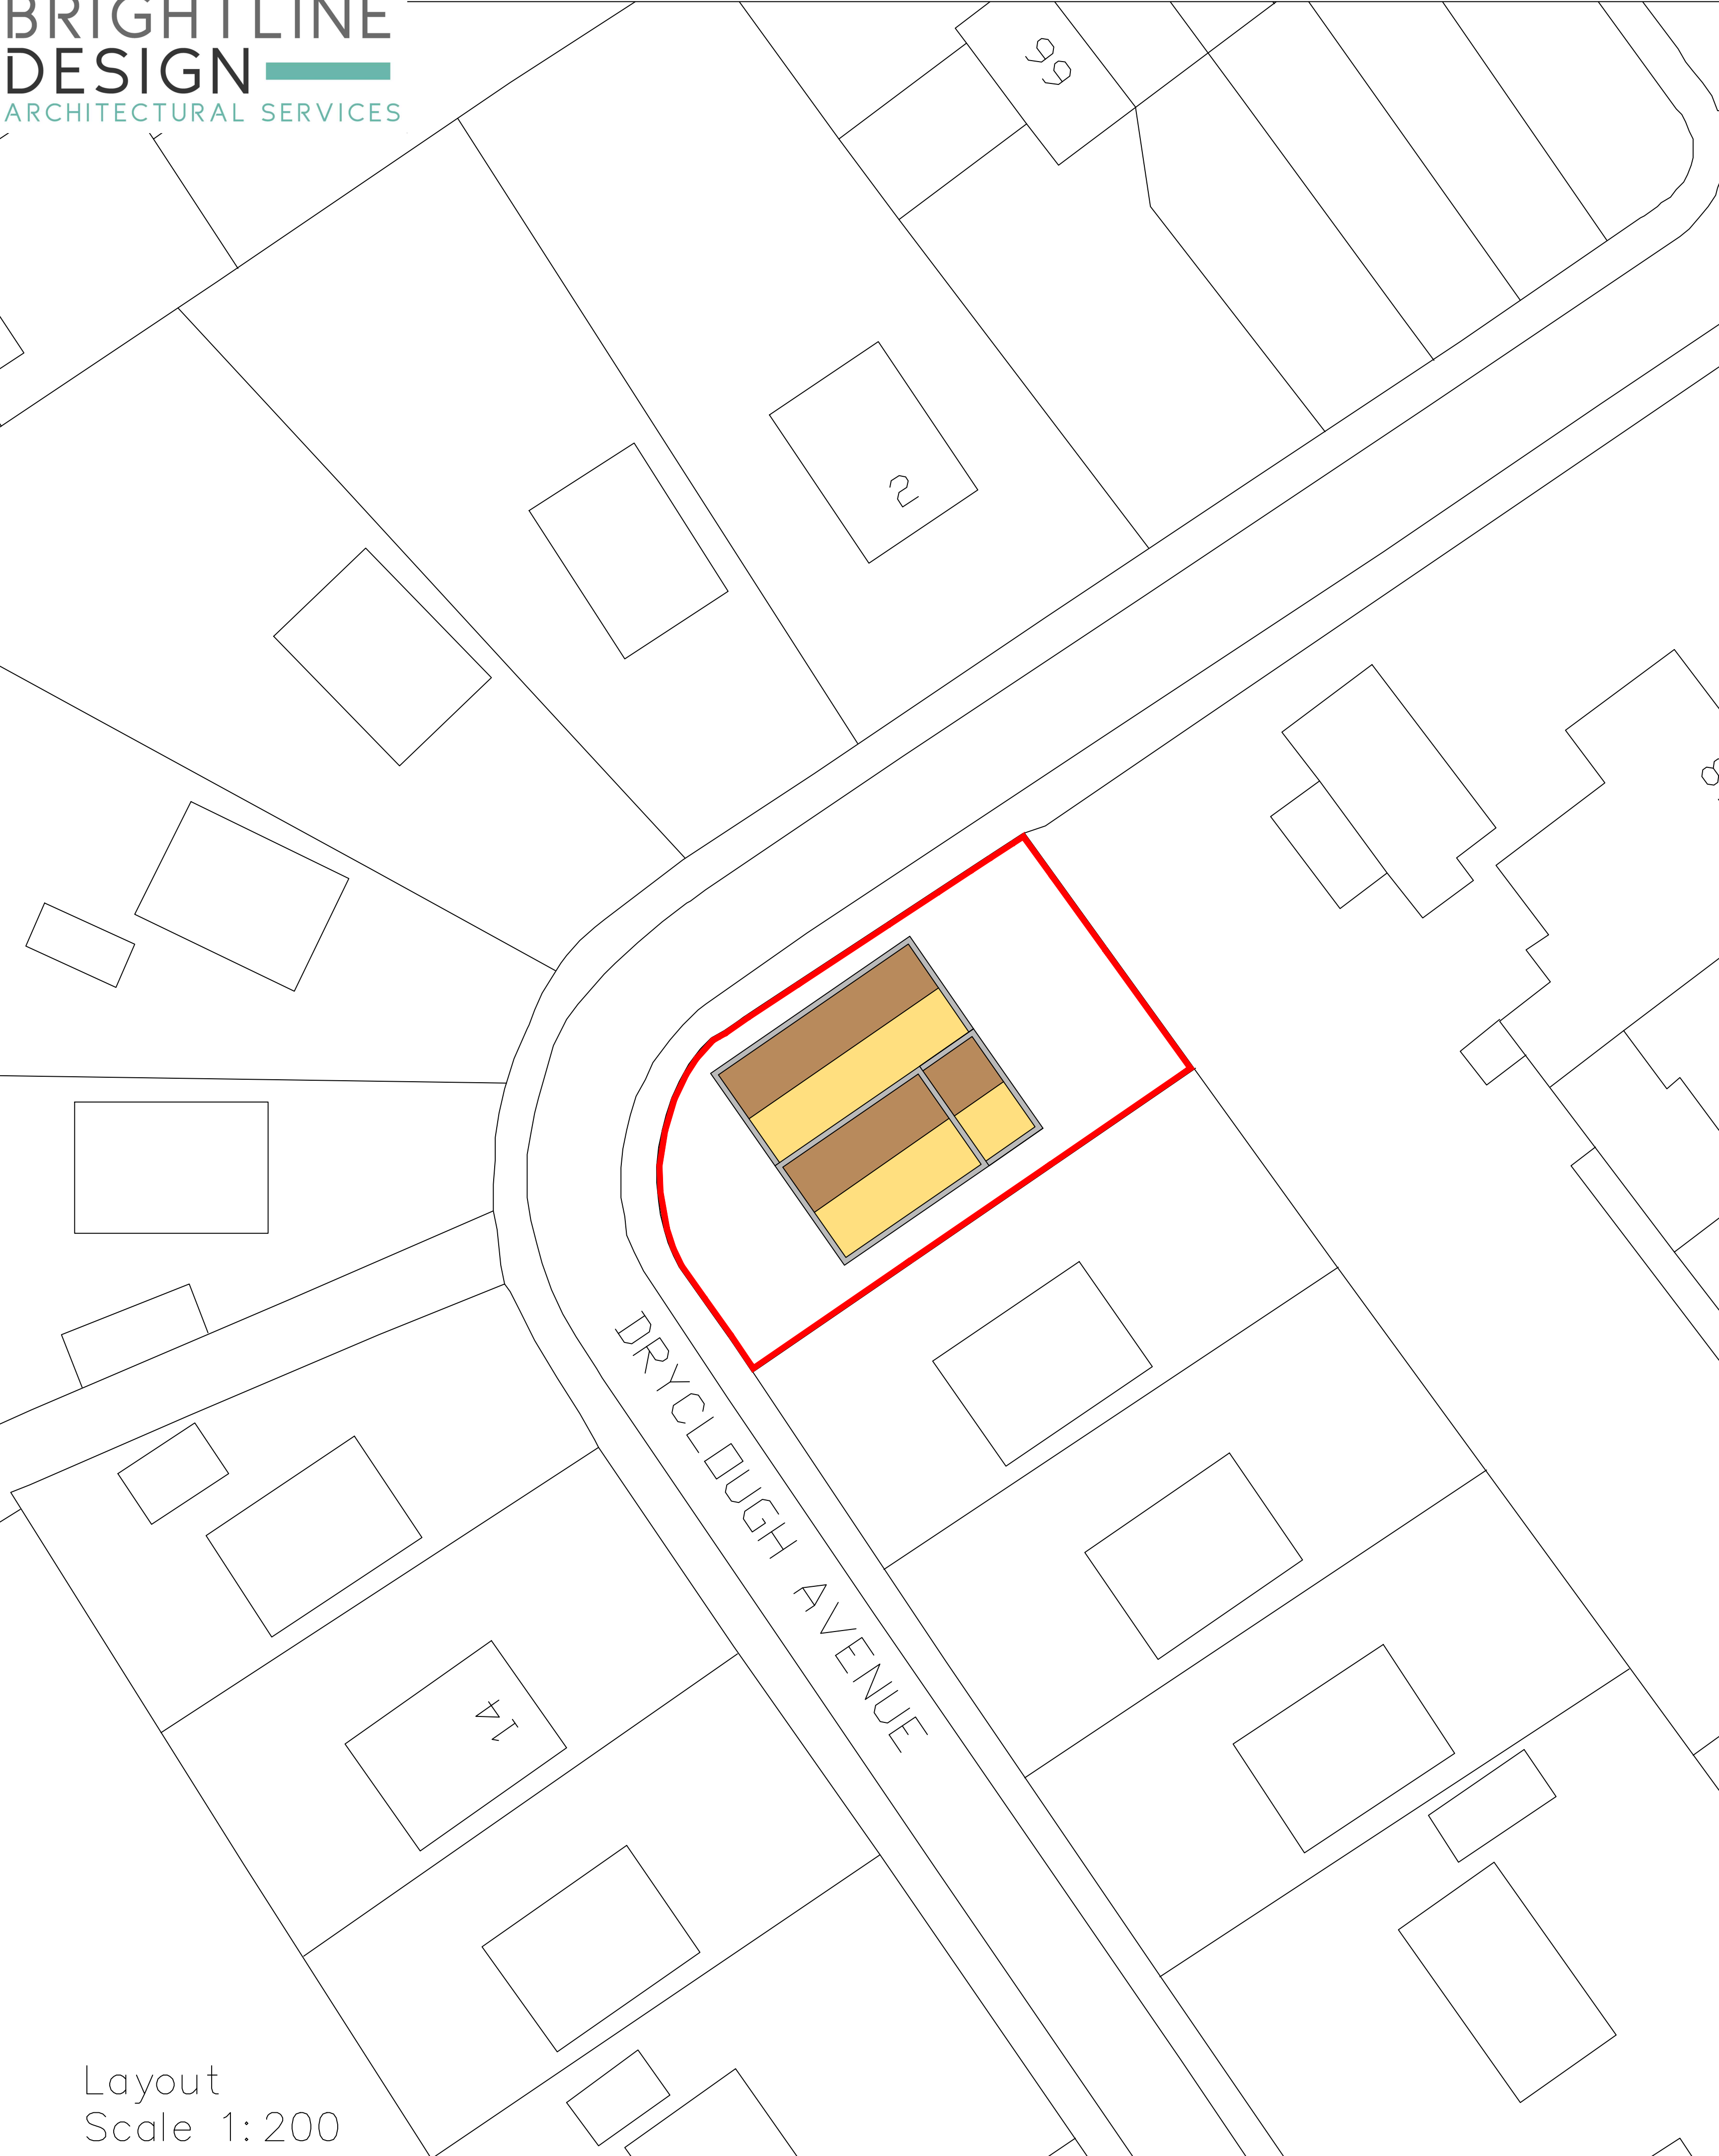

Layout
Scale 1:200

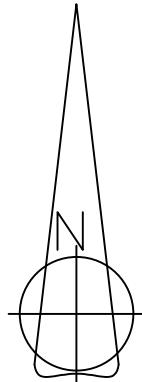

All drawings are to be read in conjunction with specification and all other drawings that relate to this house type.


All notes refer to all drawings of this house type.

Electrical layout is schematic – Completed installation to comply with L.E.E regs & all relevant codes of practices.

Electrical components ffl to comply with approved part M.

Do not scale from this drawing. [Brightline Design](#) to be notified of any discrepancies

Verify relevant dimensions on site before commencing work or preperation shop drawings. This Drawing is copyright.

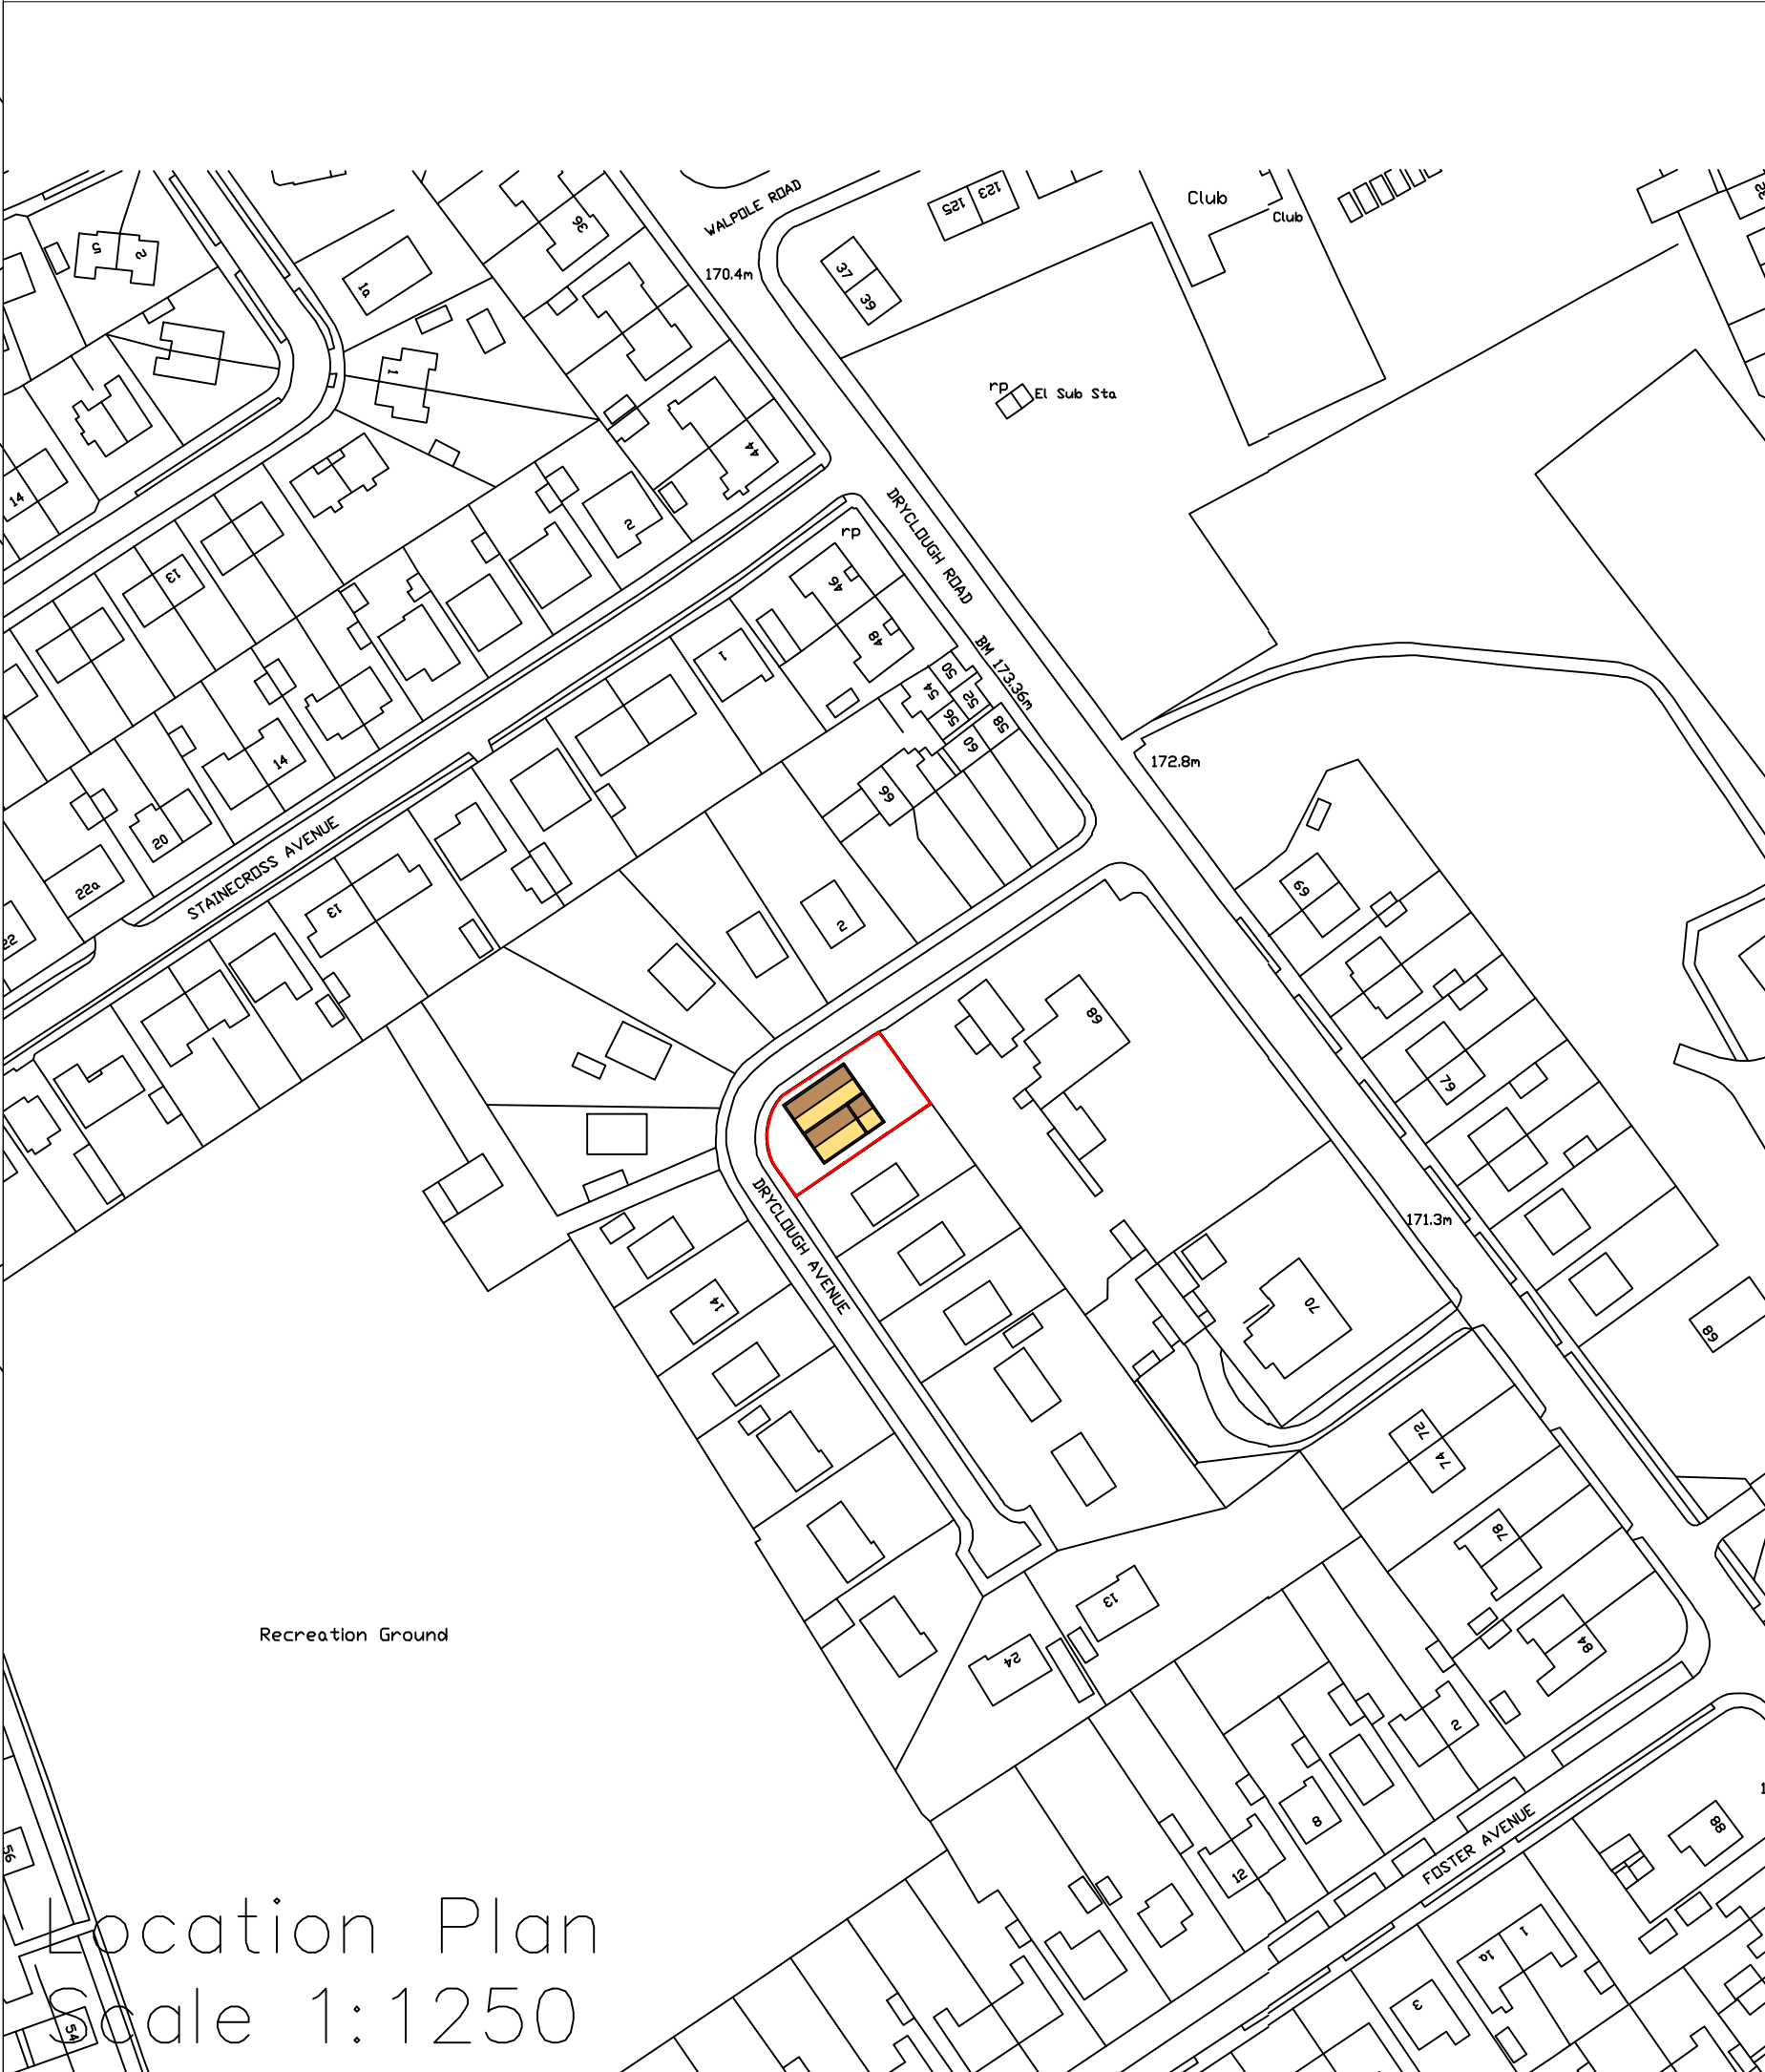

Location Plan
Scale 1:1250

5 Sunnybank Road, Greetland, Halifax. HX4 8JP
Telephone - 07590 677 717/
Email - info@brightlinedesign.co.uk
Web: www.brightlinedesign.co.uk

Client
Mr K RAJA

Project
1 Dryclough Avenue, Huddersfield
HD4 5JU

Drawing
Layout and Location Plan

Scale SEEDWG/@A1	Date JUN24	Drawn R.FOSTER
Drawing No. 24-018-03	Checked by J.WHIP	Revision -



Barn Conversion • Loft Conversion • Basement Conversion
New Build • Extension
Refurbishments • Domestic Work