



Notes

THIS DRAWING READ IN CONJUNCTION WITH :

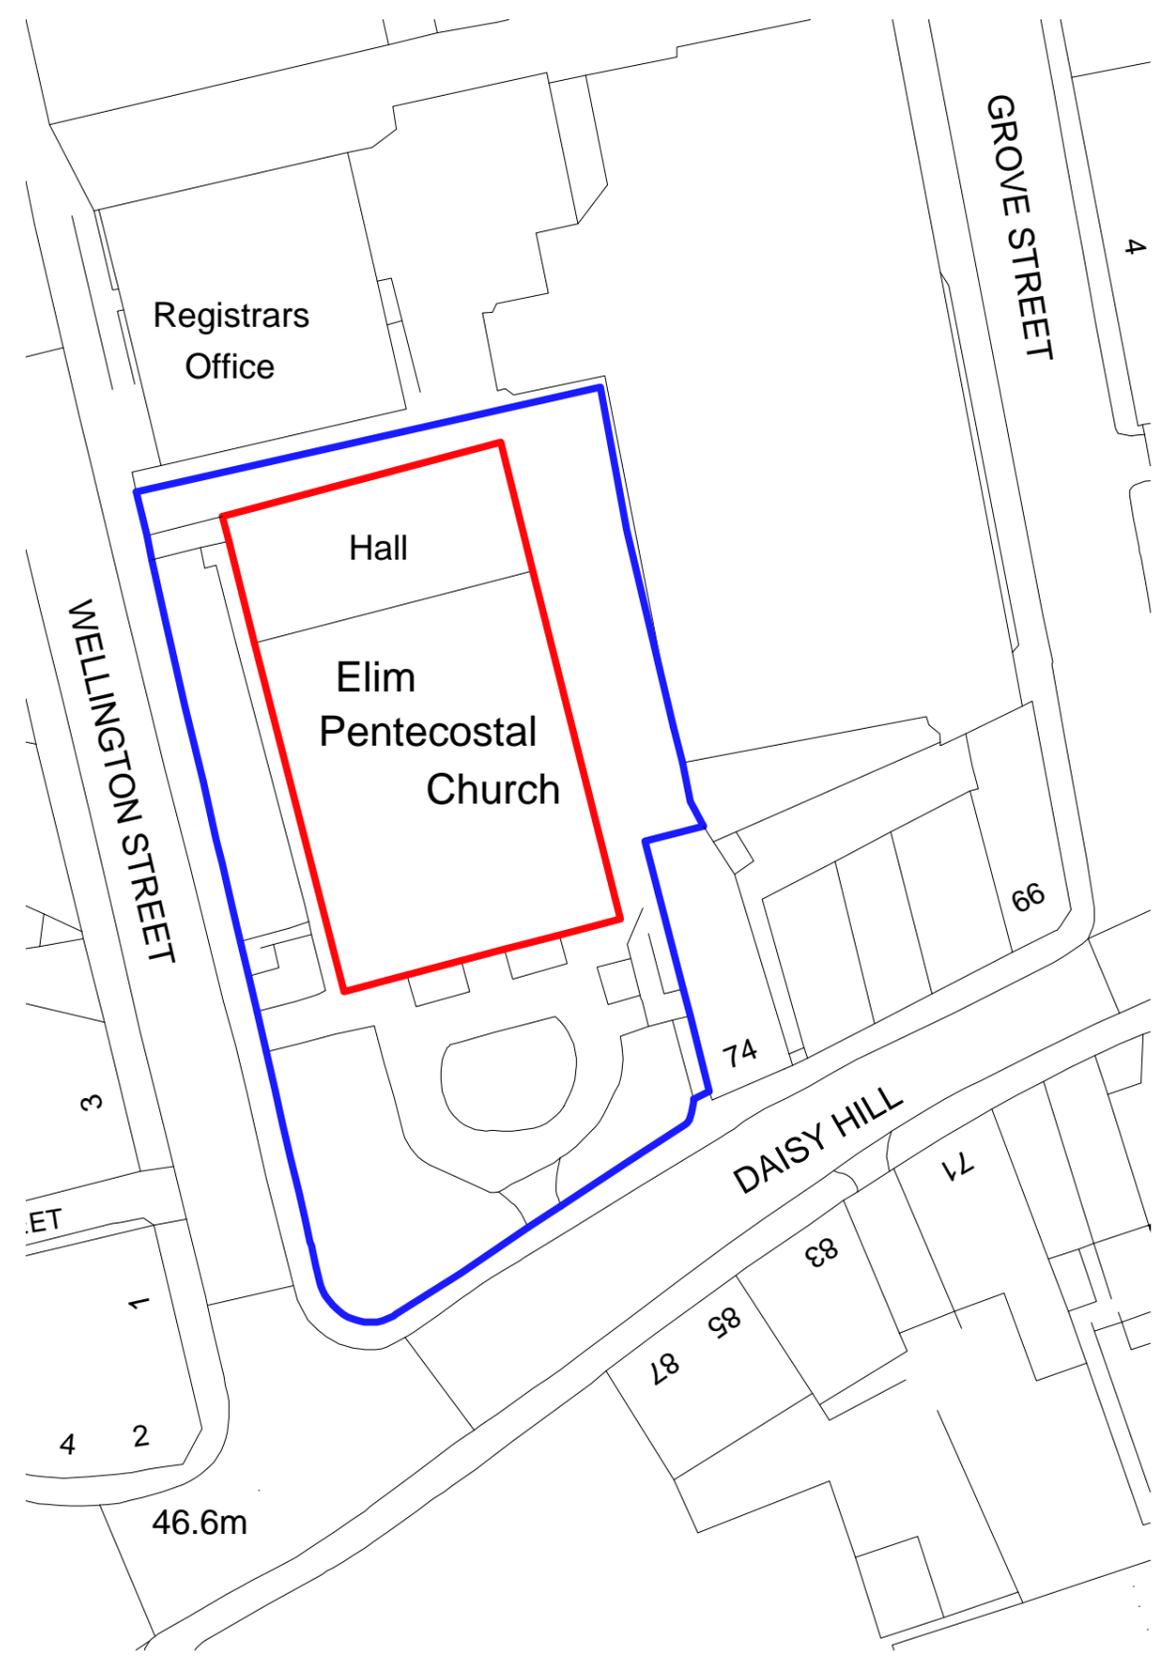

Site Plan
1:500 @ A2

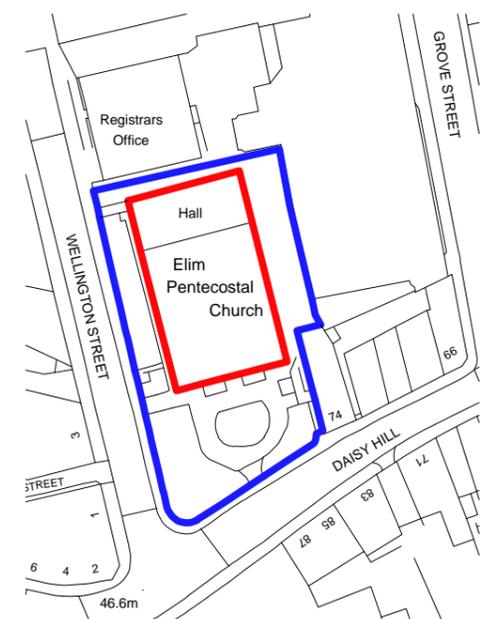

Location Plan
Scale 1:1250 @ A2

Rev	Description	Date	Dr by	App by
original by		date created		approved by
	T.Nyansimera	June'17		

AHR AHR Building Consultancy Ltd
Norwich Union House
High Street
Huddersfield
HD1 2LF
United Kingdom

T +44(0)1484 537411
F +44(0)1484 530332
E huddersfield@ahr-global.com
www.ahr-global.com

client
Elim Pentecostal Church, Dewsbury

project
Toilet Remodelling

drawing
Site & Location Plan

project number	scale	
2017.00667.000	As Indicated @A3	
drawing number	rev	issue status
EX-WC-01	-	Planning

This drawing is to be read in conjunction with all related drawings. All dimensions must be checked and verified on site before commencing any work or producing shop drawings. The originator should be notified immediately of any discrepancy. This drawing is copyright and remains the property of AHR.