
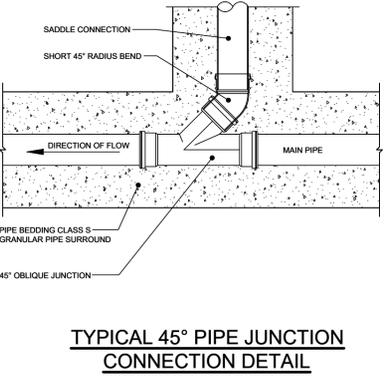
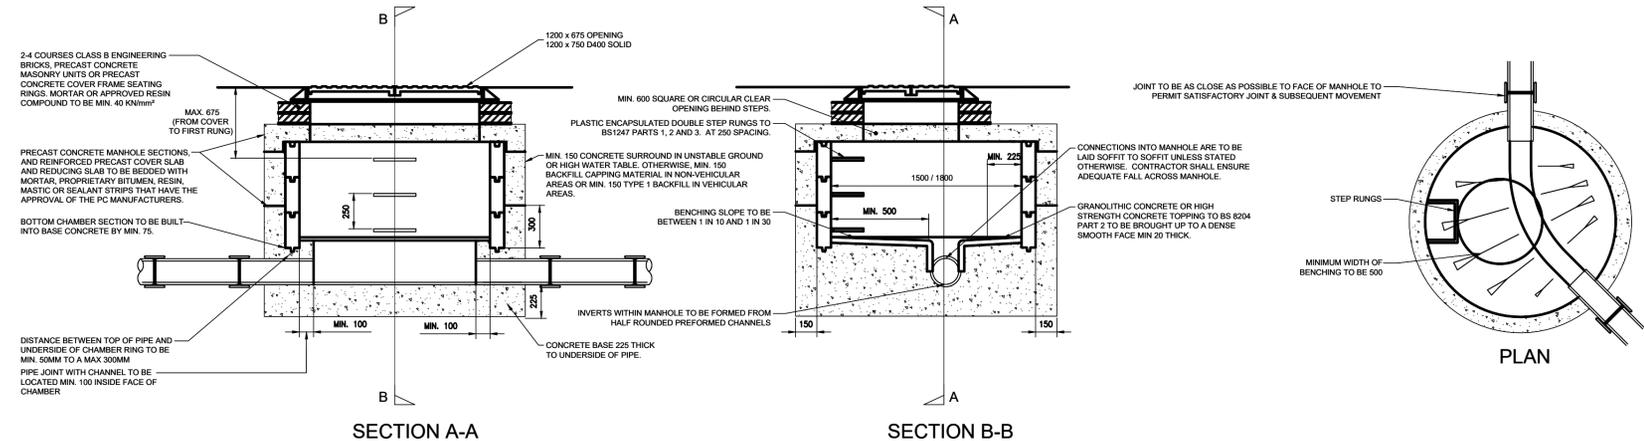
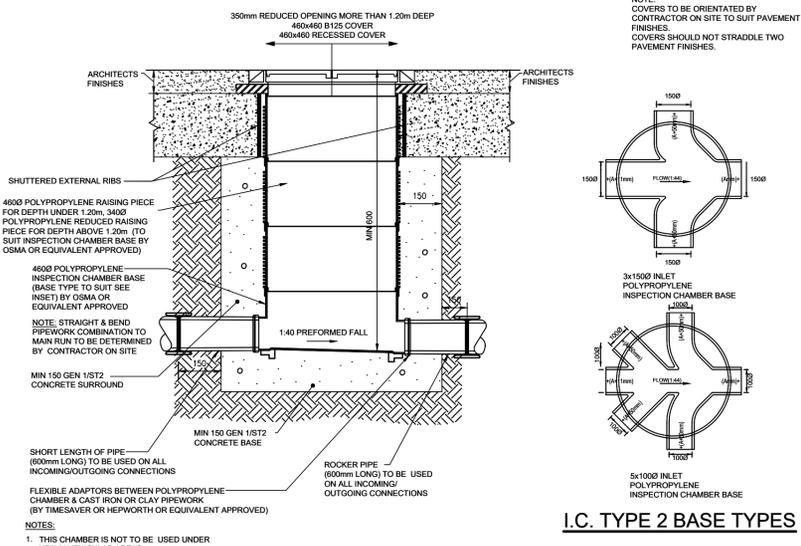


- NOTES :**
- IF THIS DRAWING HAS BEEN RECEIVED ELECTRONICALLY IT IS THE RECIPIENTS RESPONSIBILITY TO PRINT THE DOCUMENT TO THE CORRECT SCALE.
  - ALL DIMENSIONS ARE IN MILLIMETRES UNLESS STATED OTHERWISE. IT IS RECOMMENDED THAT INFORMATION IS NOT SCALED OFF THIS DRAWING.
  - THIS DRAWING SHOULD BE READ IN CONJUNCTION WITH ALL OTHER RELEVANT DRAWINGS AND SPECIFICATIONS.
  - ANY DISCREPANCIES NOTED ON SITE ARE TO BE REPORTED TO THE ENGINEER IMMEDIATELY.

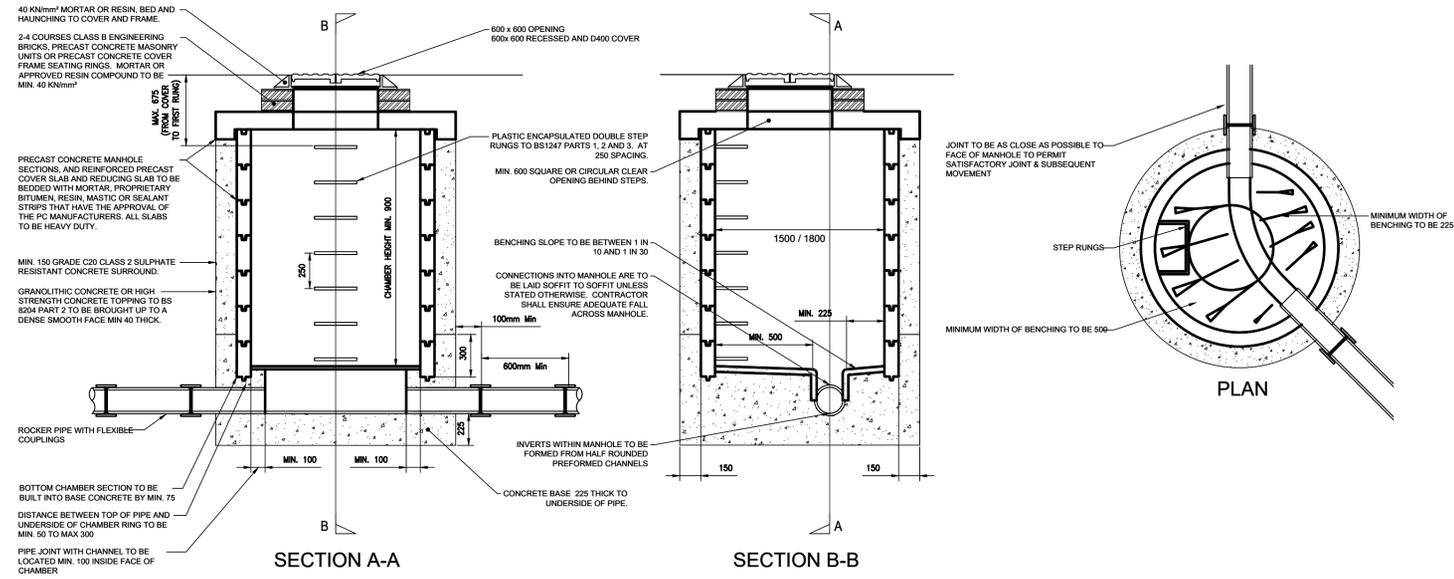

THIS DRAWING IS TO BE USED FOR PRELIMINARY INFORMATION ONLY AND MUST NOT BE READ AS A CONSTRUCTION ISSUE. IT INDICATES DESIGN INTENT ONLY AND IS SUBJECT TO AMENDMENT DURING FINAL DESIGN DEVELOPMENT

**PRELIMINARY DRAWING ISSUE**

P02	DRAWING UPDATED TO SUIT REVISED BELOW GROUND DRAINAGE LAYOUT	MDS	12.01.24
P01	PRELIMINARY DRAWING ISSUE	MDS	10.10.23
rev	amendments	by	date



Client : **ASH MARTIN CONSTRUCTION**

Project : **FREDRICK FINLAY CARE HOME, OXFORD ROAD, DEWSBURY**

Title : **PROPOSED BELOW GROUND DRAINAGE DETAILS SHEET 1 of 3**

Drawing Status :	Date Created :	Drawing Scale :
<b>PRELIMINARY</b>	<b>JULY '23</b>	<b>N.T.S.</b>
Project Number   Originator   Vol.   Level   Type   Role   Number	Rev :	
<b>LE-161 - CCS - 01 - 00 - DR - S - 0201</b>	<b>P02</b>	
Project Leader :	Drawn By :	Initial Review :
<b>JB</b>	<b>MDS</b>	<b>JB</b>