

THIS DRAWING IS COPYRIGHT, AND REMAINS THE PROPERTY OF HT ARCHITECTS. IT MUST NOT BE REPRODUCED, USED, DISCLOSED OR TRANSMITTED TO THIRD PARTIES IN ANY FORM, IN WHOLE OR IN PART, WITHOUT PRIOR WRITTEN PERMISSION.

DO NOT SCALE!  
ALL DIMENSIONS SHOULD BE CHECKED ON SITE BEFORE WORK COMMENCES

TITLE PLAN: WYK122973, WYK13687, WYK07987, WYK86603 and YWE22745

TRACKING: E.JSA 1814 07 Proposed Site Plan OPTION 5 paths update


LIGHTING PLAN: LIDL New Hey Road Carpark Ltg Proposal 19.10.18 - SUBJECT TO ADDITIONAL LIGHTING

ARBORICULTURAL SURVEY: 12484 SR Arboricultural Report at the former Spotted Cow, New Hey Road, Huddersfield


MODIFIED DEVELOPERS SPECIFICATION DRAWING

SURVEY INFORMATION:  
D224-011 June 2018 Landform Surveys  
001002 November 2014 Landform Surveys


LEVEL OF BEDROCK IS ESTIMATED AND SUBJECT TO FURTHER INVESTIGATION

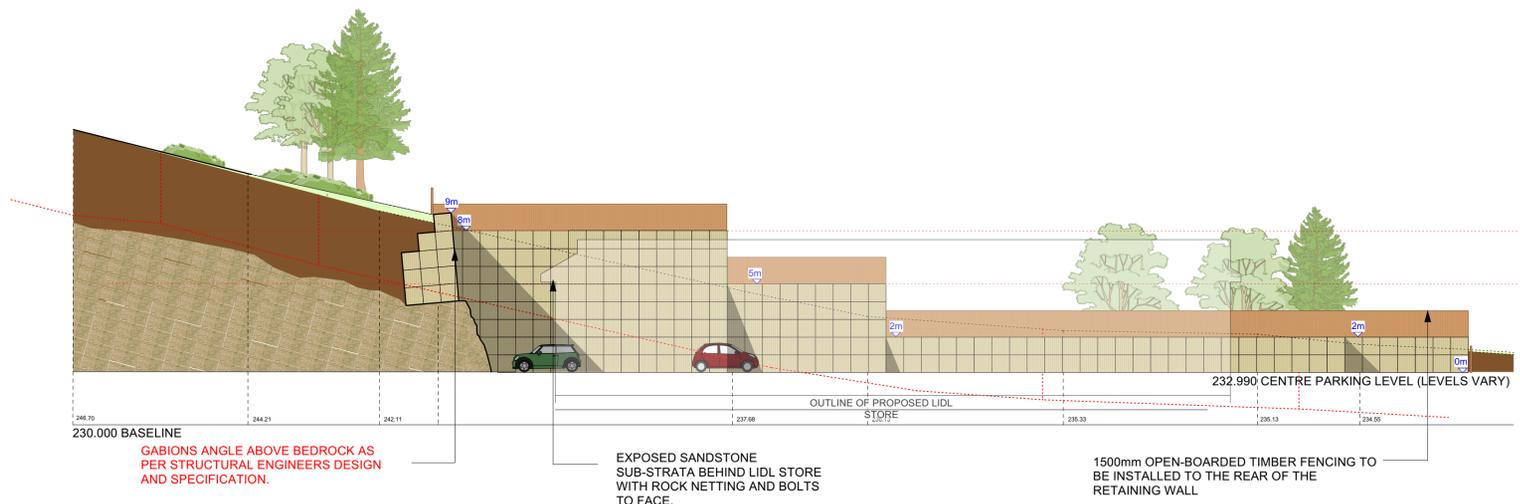


1 - EAST /SIDE RETAINING WALL

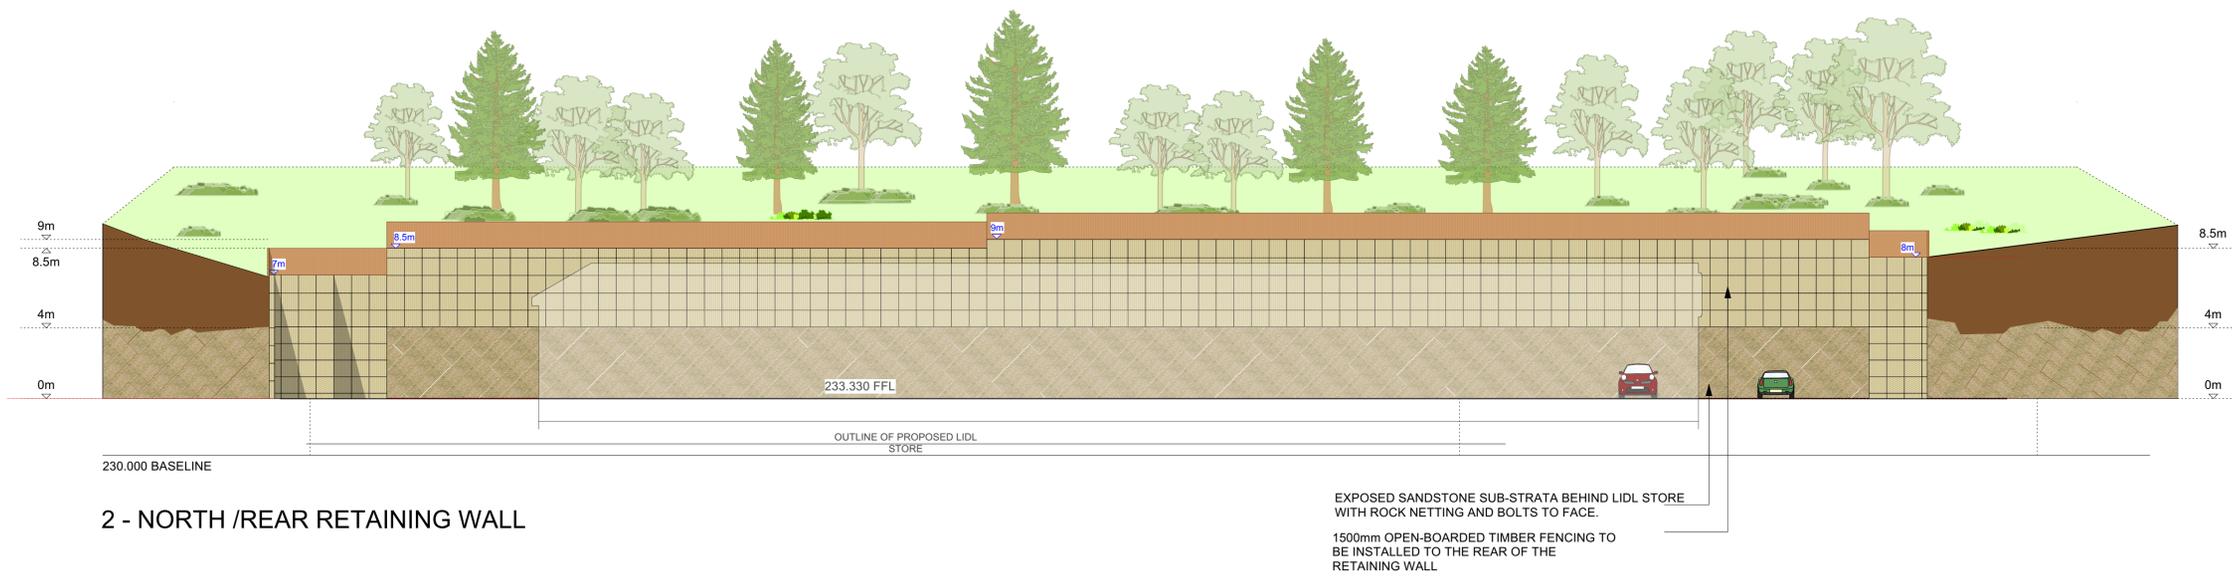

2 - NORTH /REAR RETAINING WALL

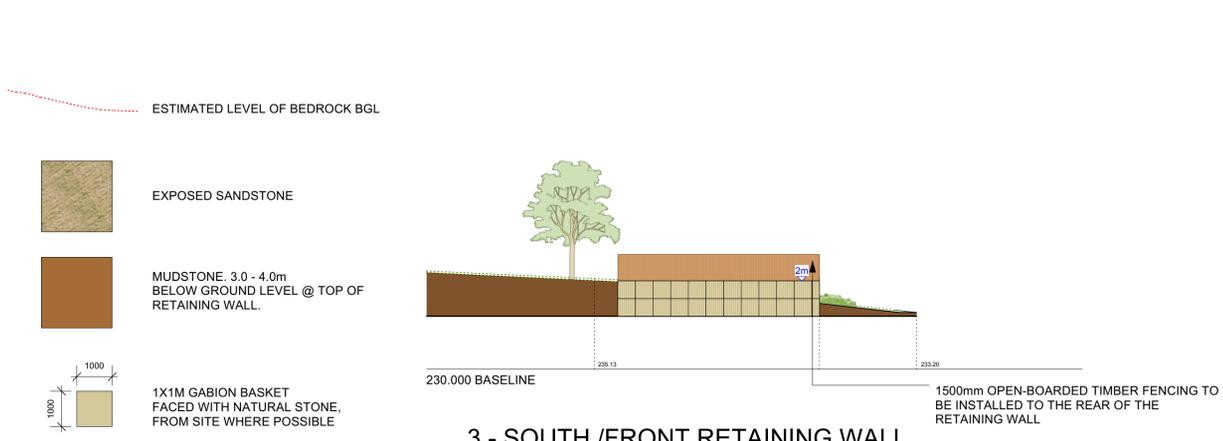

3 - SOUTH /FRONT RETAINING WALL

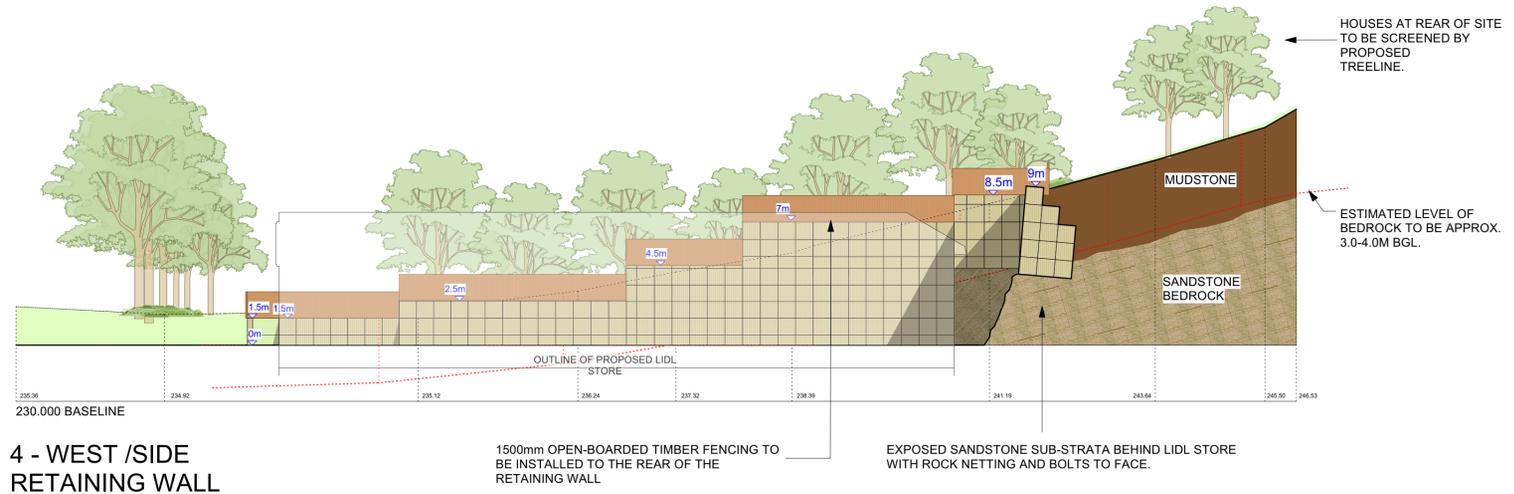

4 - WEST /SIDE RETAINING WALL

Rev	Date	Description	Drawn
H	06.08.14	Updated Store silhouette in line with P4170	JBH
G	04.11.19	Updated in line with latest site plan alterations	LS
F	20.06.19	Added annotation on each elevation specifying Timber fencing	JBH
E		Updated in line with Boundary Treatment Plan	LS
A.D	02.04.19	Clients updates	

client  
Lidl GB Ltd



project  
New Hey Road,  
Huddersfield

drawing title  
Proposed Retaining Wall  
Elevations

date  
Auhust 2024

status  
Planning Issue

scale  
1:200 @ A1

drawn  
DL checked  
MH

job no.  
1814

dwg no.  
P406

rev.  
H

htarchitects

York Place Studio  
8 Britannia Street  
Leeds  
LS1 2DZ

T: (0113) 244 3457  
E: info@htarchitects.co.uk