




PLANNING - MCC KIOSK PLAN
1 : 100

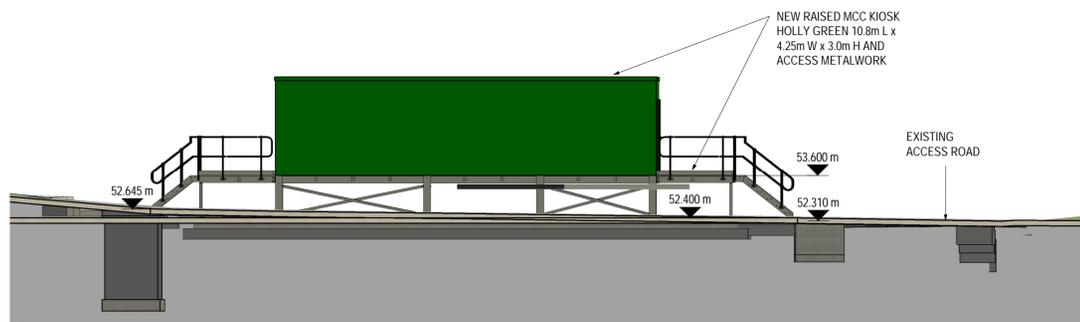


1 EAST ELEVATION
1 : 100

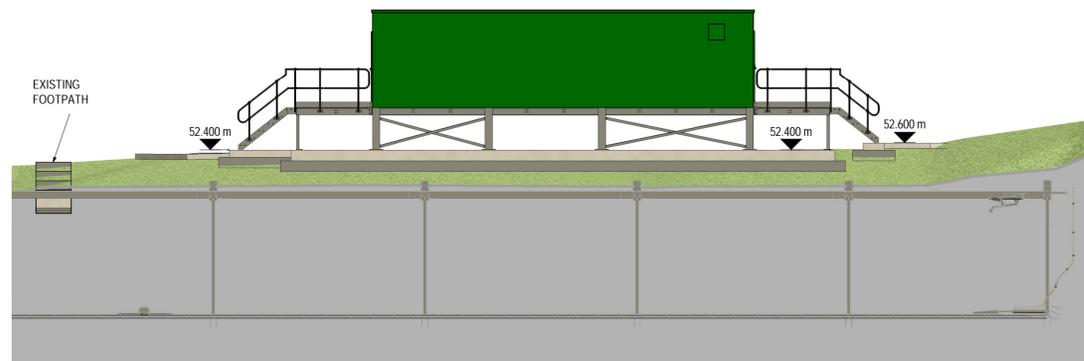


3 WEST ELEVATION
1 : 100

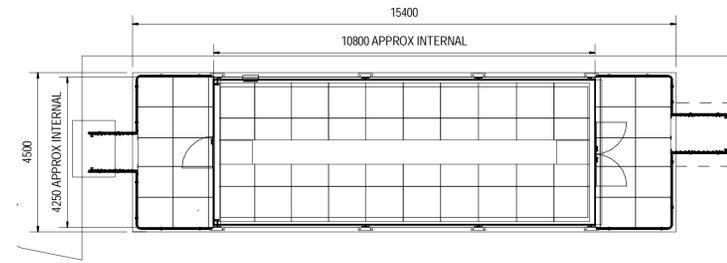

6 PLANNING - MCC KIOSK INTERNAL PLAN
1 : 100

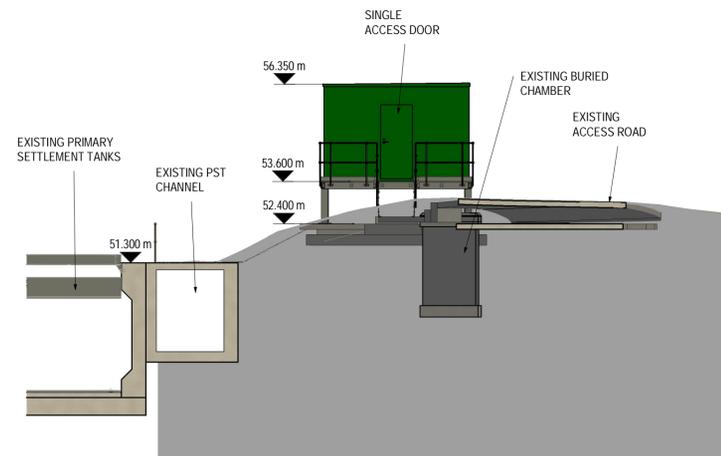

2 SOUTH ELEVATION
1 : 100

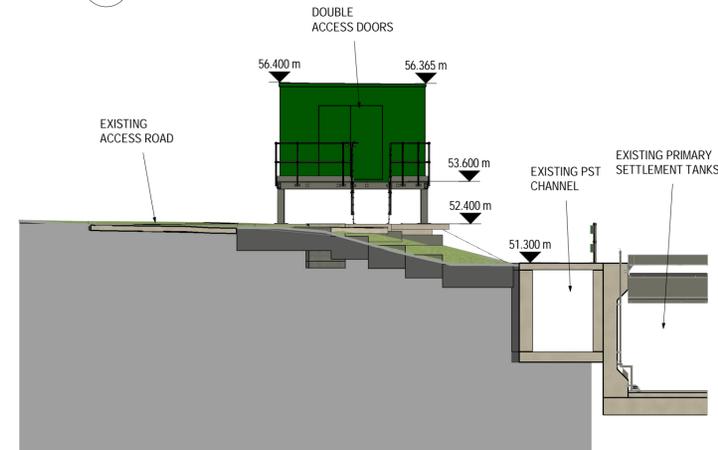

4 NORTH ELEVATION
1 : 100

- NOTES:**
- THIS DRAWING TO BE READ IN CONJUNCTION WITH ALL RELEVANT DRAWINGS AND TOGETHER WITH THE SPECIFICATIONS.
 - ALL DIMENSIONS ARE SHOWN IN MILLIMETRES (mm), UNLESS NOTED OTHERWISE.
 - ALL LEVELS ARE SHOWN IN METRES (m) AOD, UNLESS NOTED OTHERWISE.

- REFERENCE DRAWINGS**
- HUDE-MMB-WWT-SED-DR-C-0101 PLANNING - SITE LOCATION PLAN
 - HUDE-MMB-WWT-SED-DR-C-0102 PLANNING - EXISTING SITE LAYOUT
 - HUDE-MMB-WWT-SED-DR-C-0103 PLANNING - PROPOSED SITE PLAN



File Location: BIM 360//VU09 - Deighton WwTW PST Investigation/HUDE-MMB-WWT-SED-M3-C-0001.rvt

Rev	Description	Drawn	Check	App'd	Output Date
S1.P03	ISSUED FOR PLANNING	RN	TG	GM	16/05/24
S1.P02	ISSUED FOR PLANNING	RN	TG	GM	17/10/23
S1.P01	ISSUED FOR PLANNING	RN	TG	GM	28/09/23

Status: Rev: Description: Drawn: Check: App'd: Output Date:

Construction Complete Date: 25/11/2025

MMB
MOTT MACDONALD BENTLEY

Mott MacDonald Bentley
Bank House
King Street
Leeds
LS1 1HT
www.mottmacbentley.co.uk

YORKSHIRE WATER
ALWAYS CONSIDERS

LIFE SAVING RULES

YorkshireWater

Yorkshire Water Services Ltd
Western House,
Western Way,
Halifax Road,
Bradford,
BD6 2SZ

Framework: AMP 7	Work Stream: COMPLEX MEICA
YW Batch ID / Project Code: YW.201455.04	YW Solution ID: 0

Site: **DEIGHTON STW**

OS Grid Reference: 417092 , 419235	DAZ or DMA Reference: 283
------------------------------------	---------------------------

Drawing Title: **PLANNING - PROPOSED KIOSK PLAN & ELEVATIONS**

Original Design / OEM Reference: -	Site: A1	Scale: 1 : 100
Status Description: NOT FOR CONSTRUCTION	Status: S1	Revision: P03
Drawing Number: HUDE MMB WWT SED DR C 0104		