



Builder/Contractor should not scale from this drawing-should use figured dimensions only. Builder/Contractor must check all dimensions on site before works. Any discrepancy found to be reported to A N Designs Ltd as soon as possible. This drawing or any portion of it may not be reproduced.

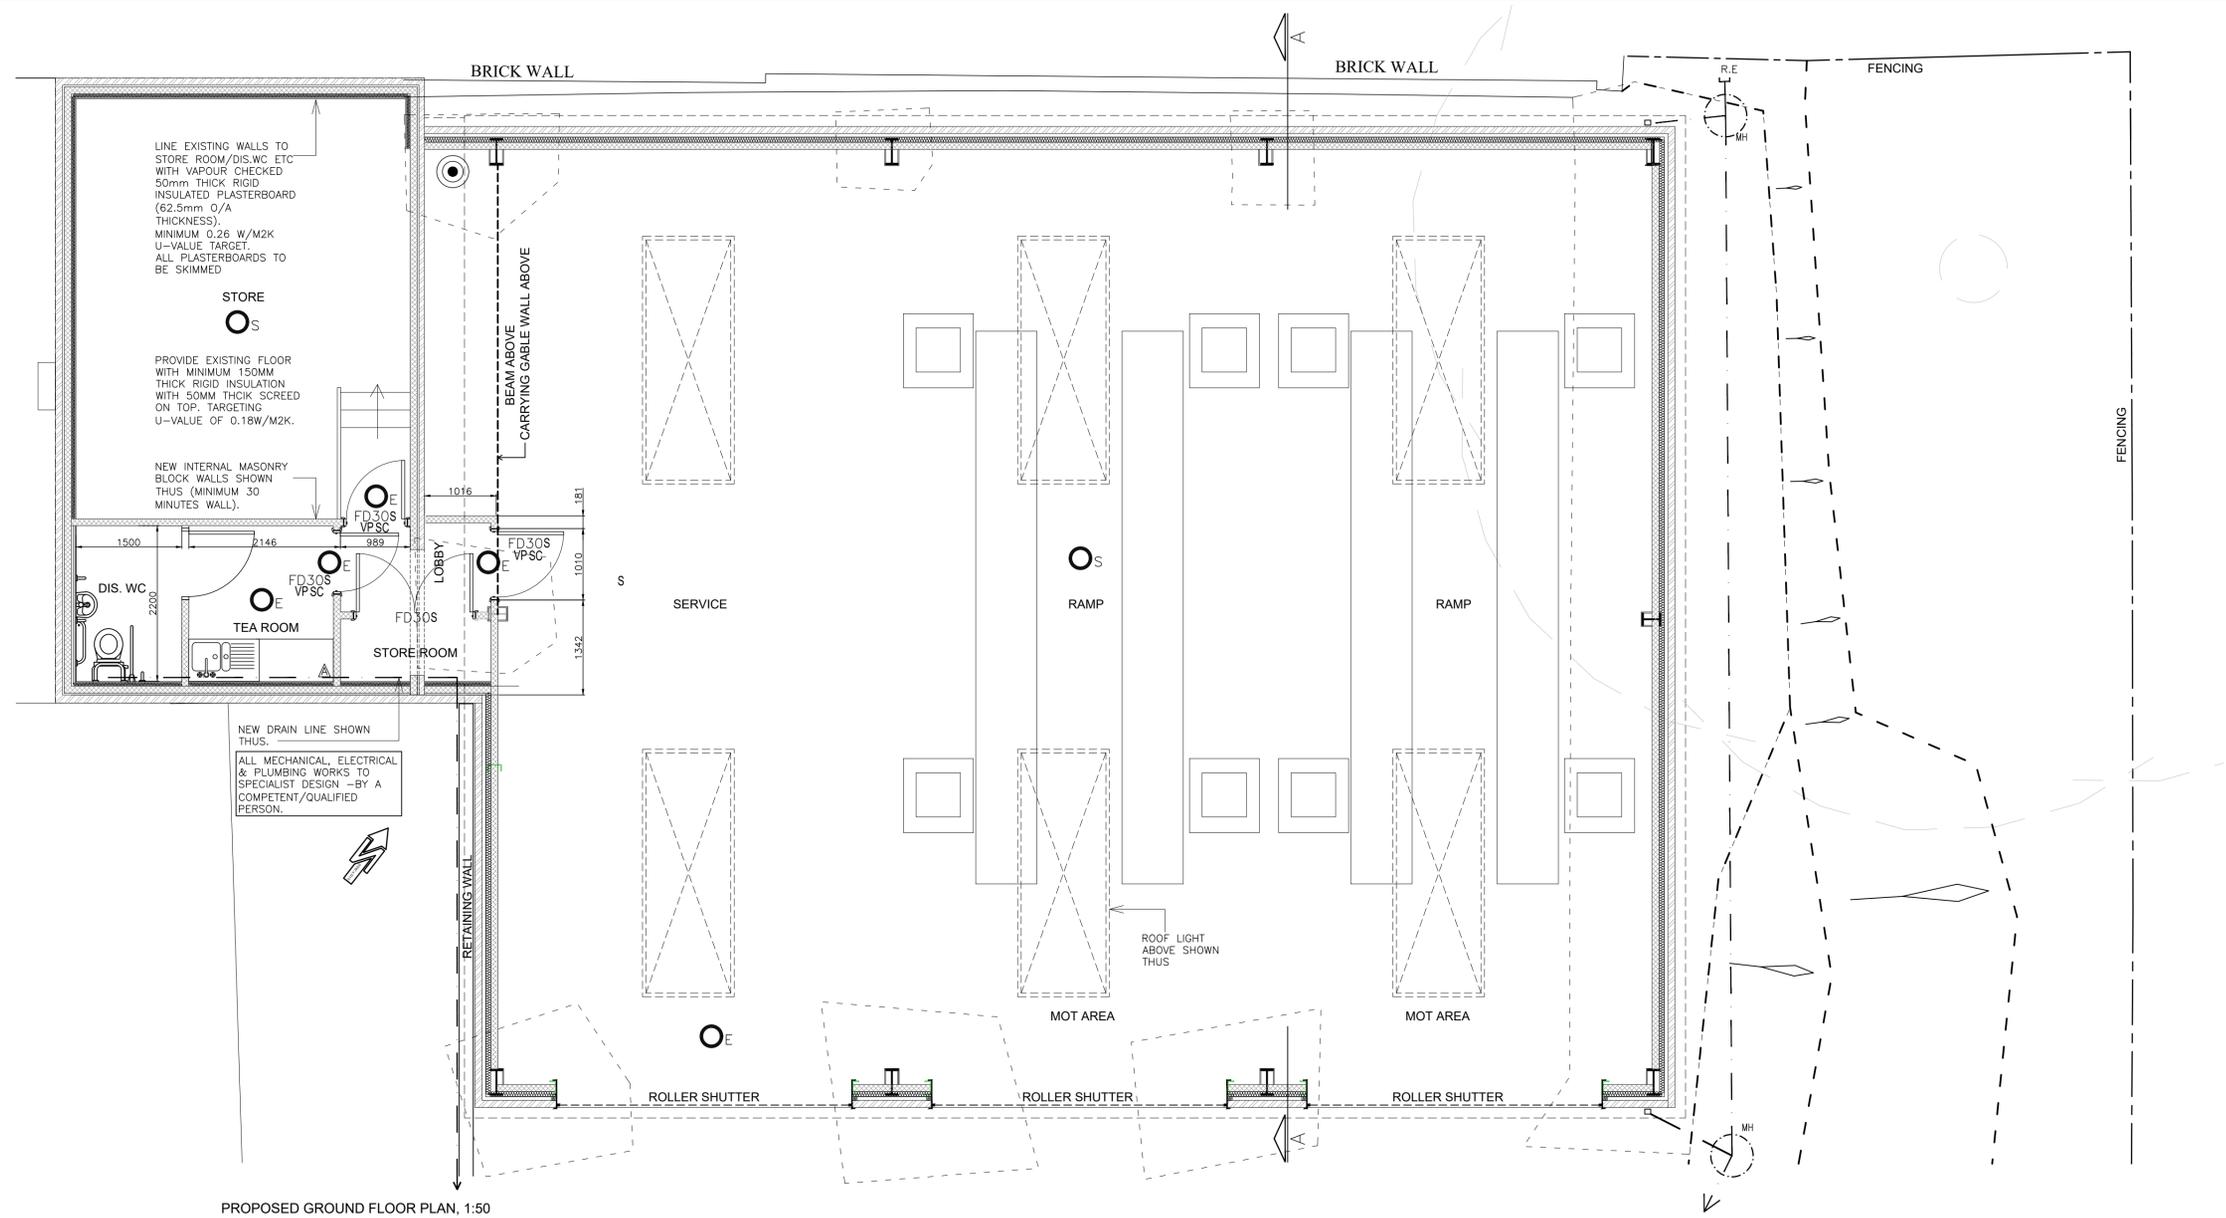

PROPOSED GROUND FLOOR PLAN, 1:50

LEGEND:-	
○ _E	ILLUMINATED EMENGENCY LIGHTING
○ _H	HEAT DETECTOR & SOUNDER
○ _S	SMOKE DETECTOR & SOUNDER
▲	FIRE EXTINGUISHER
FD30	30 MINUTES FIRE RESISTING DOOR
○	FIRE ALARM SOUNDER
□	MANUAL FIRE ALARM ACTUATION POINT
TBC	DIMENSIONS TO BE CONFIRMED ON SITE
FIRE BUILDING REGULATION NOTES:- -Exit and fire safety signage to be provided in accordance with BS 5499-1:2002 (indicative layout shown all to be confirmed by Fire Engineer before installation). NOTE, SMOKE DETECTORS TO BE WIRED INTO MAINS ELECTRICAL SYSTEM TO MANUFATURER'S INSTRUCTIONS, B.S. 5546 AND INTERLINKED.	
All fire Alarm information shown on this project by A N Design are indicative & to be reviewed by Specialist Designer before supply and works. FD =Fire Resisting Door. VP =Vision Panel in door SC=Self closing Door S = SMOKE SEAL Door	

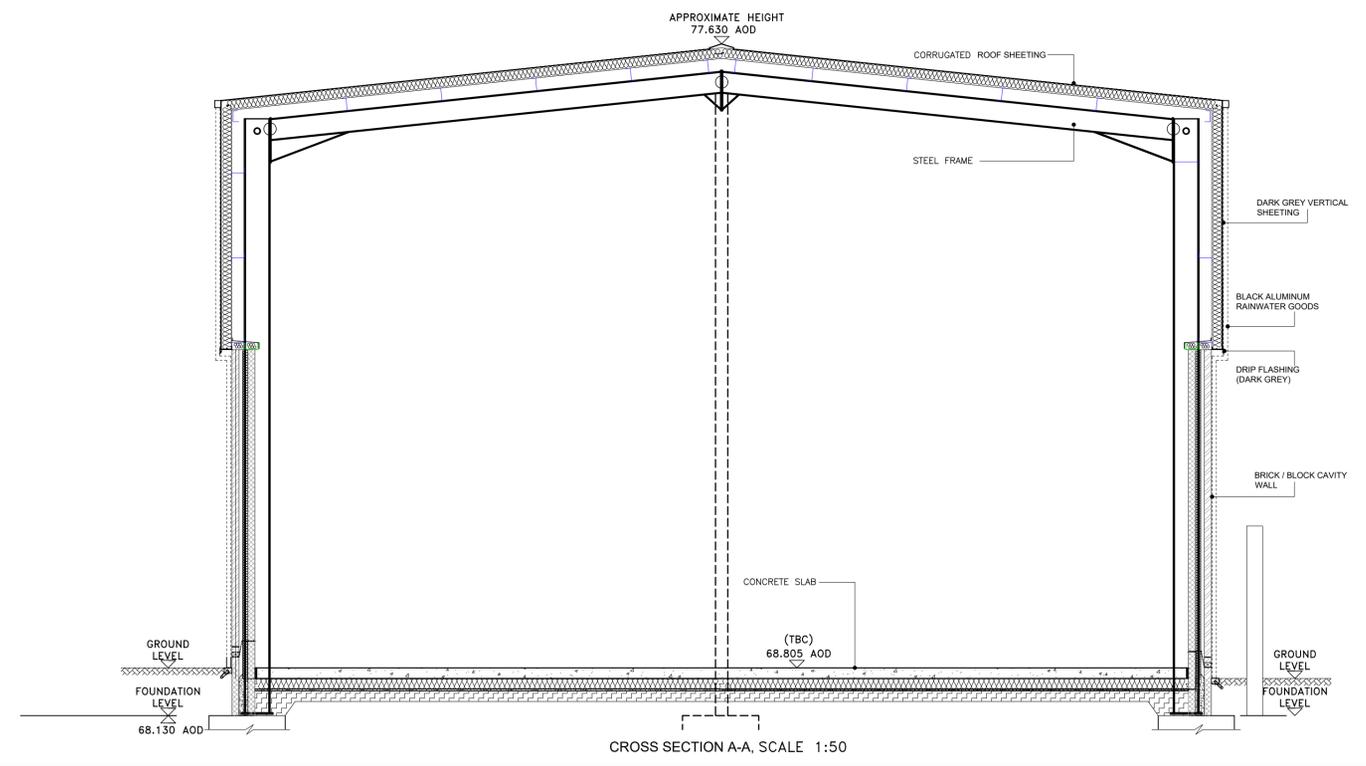

CROSS SECTION A-A, SCALE 1:50

REV	DATE	DESCRIPTION
DRAWING STATUS: PLANNING & BUILDING REGS ISSUE		

AN Architectural Design Ltd
 CONTACT ASIF NEKI
 MOB: 07970 020 028
 EMAIL:asif@andesigns.eu
 28 HEARFIELD ROAD, SAVILLE TOWN, DEWSBURY, WF12 8JF

CLIENT:
MR AMJID RASHID

PROJECT:
PROPOSED MINISTRY OF TRANSPORT (MOT) BAY/SERVICE/STORAGE AREA, AT WILTON MILLS, 586 BRADFORD ROAD, BATLEY, WF17 8LP

TITLE:
PROPOSED FLOOR PLAN, PROPOSED CROSS SECTION A-A

SCALE: 1:50	DATE: APRIL 2025
PROJECT No: WILTON-101	DRAWING No: WK-03
REV:	REV: