
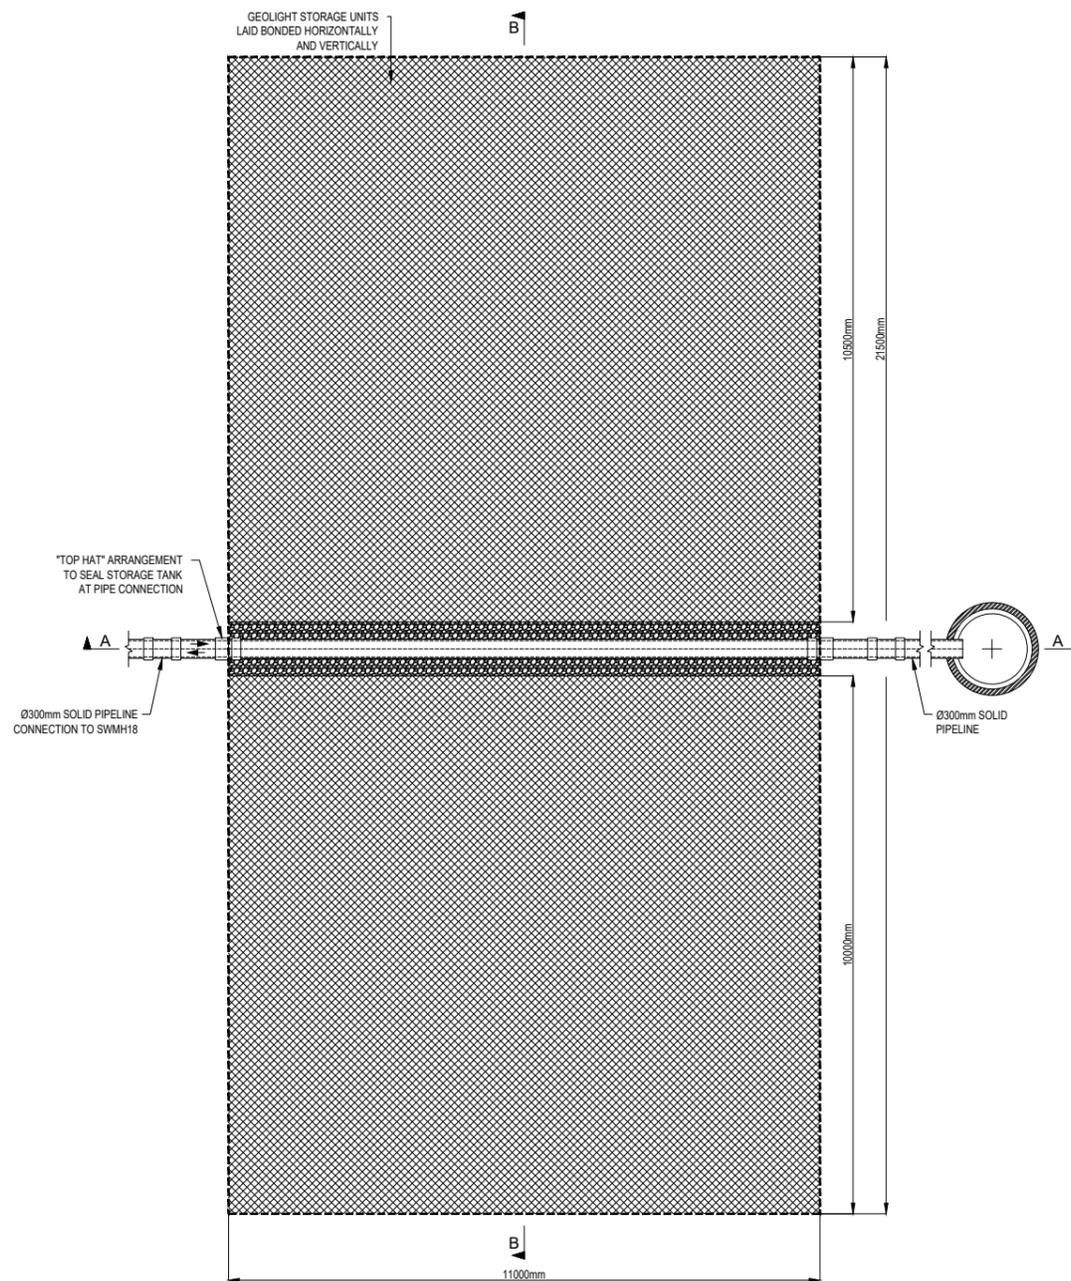


WEHOLYTE MANHOLE WITH SUMP
REF: NEW
IL: 100.200

APPROX. CL 102.400 - 104.000

TOT 101.700

IL 100.200

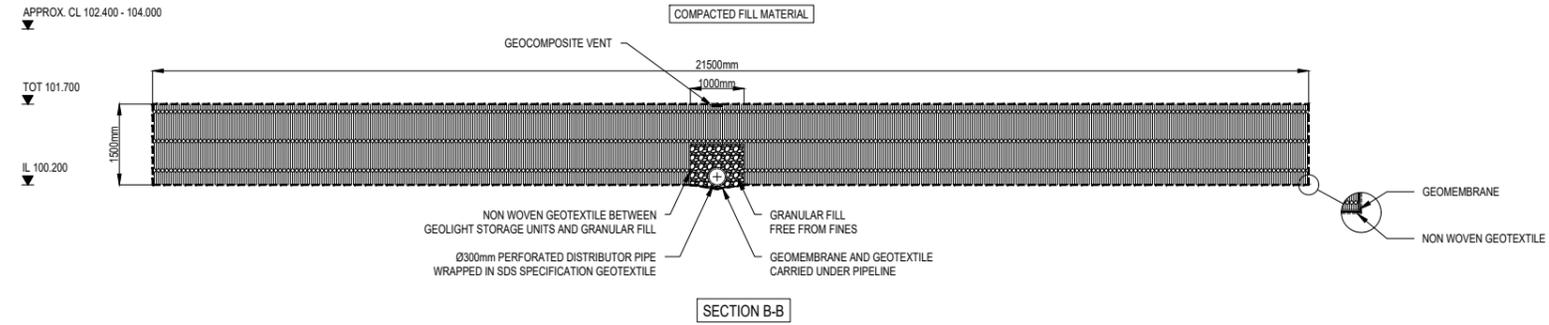

Notes:

This Drawing is to be read in conjunction with all relevant Architect's Engineer's and specialists' drawings and specifications.

Do not scale from this drawing in either paper or digital form. Use written dimensions only.

SDS to leave solid stub only, exiting tank for connection by others.

All external Manholes, Access Points, Junctions & Pipe are shown for guidance only and not part of the SDS program unless otherwise agreed.

ISSUED FOR APPROVAL	08.04.24
Rev	Comments
Rev	Comments



Clearwater House
Castlemills
Biddisham
Somerset
BS26 2RE
+44 (0)1934 751303

sdslimited.com

KENMORE DRIVE,
CLEAKHEATON

ROBERTSONS

ATTENUATION TANK 1 DETAIL

Scale: NTS Date: 08.04.24

Drawing No: E257220_01 Rev: -

REFERENCE DRAWINGS:			
Drawing Number	Revision	Drawing Title	Date
CLK-MJM-XX-XX-DR-D-5201	C4	OVERALL SITE DRAINAGE LAYOUT	29.01.24