


- GENERAL NOTES**
1. THIS DRAWING IS COPYRIGHT AND SHOULD NOT BE REPRODUCED IN WHOLE OR PART WITHOUT THE WRITTEN CONSENT OF PATRICK PARSONS LTD.
 2. DO NOT SCALE FROM THIS DRAWING.
 3. LOCATIONS OF ALL EXISTING SERVICES ON-SITE TO BE CONFIRMED & PROVIDED TO THE ENGINEER PRIOR TO COMMENCEMENT OF WORKS.
 4. THIS DRAWING IS TO BE READ IN CONJUNCTION WITH ALL RELEVANT PATRICK PARSONS LTD DRAWINGS & SPECIFICATIONS.
- PRIVATE DRAINAGE NOTES**
1. ALL DIMENSIONS IN mm UNLESS NOTED OTHERWISE.
 2. ALL LEVELS IN METRES.
 3. ALL PROPOSED DRAINAGE TO BE MINIMUM 1000 UNLESS NOTED OTHERWISE.
 4. ALL CONNECTING PIPES TO ADOPTABLE DRAINAGE TO BE MINIMUM 1500.
 5. ALL RAINWATER PIPES MUST BE FITTED WITH A RODDABLE ACCESS ABOVE GROUND.
 6. ALL PRIVATE DRAINAGE TO BE INSTALLED IN ACCORDANCE WITH PART H OF THE BUILDING REGULATIONS AND BS EN 752 & 12056.
 7. PRIVATE DRAINAGE TO BE 1500 UPVC PIPES WITH GRP OR UPVC INSPECTION CHAMBERS. SYSTEM DESIGN & CONSTRUCTION TO CONFORM WITH MANUFACTURER'S INSTRUCTIONS & "GOOD PRACTICE GUIDE".

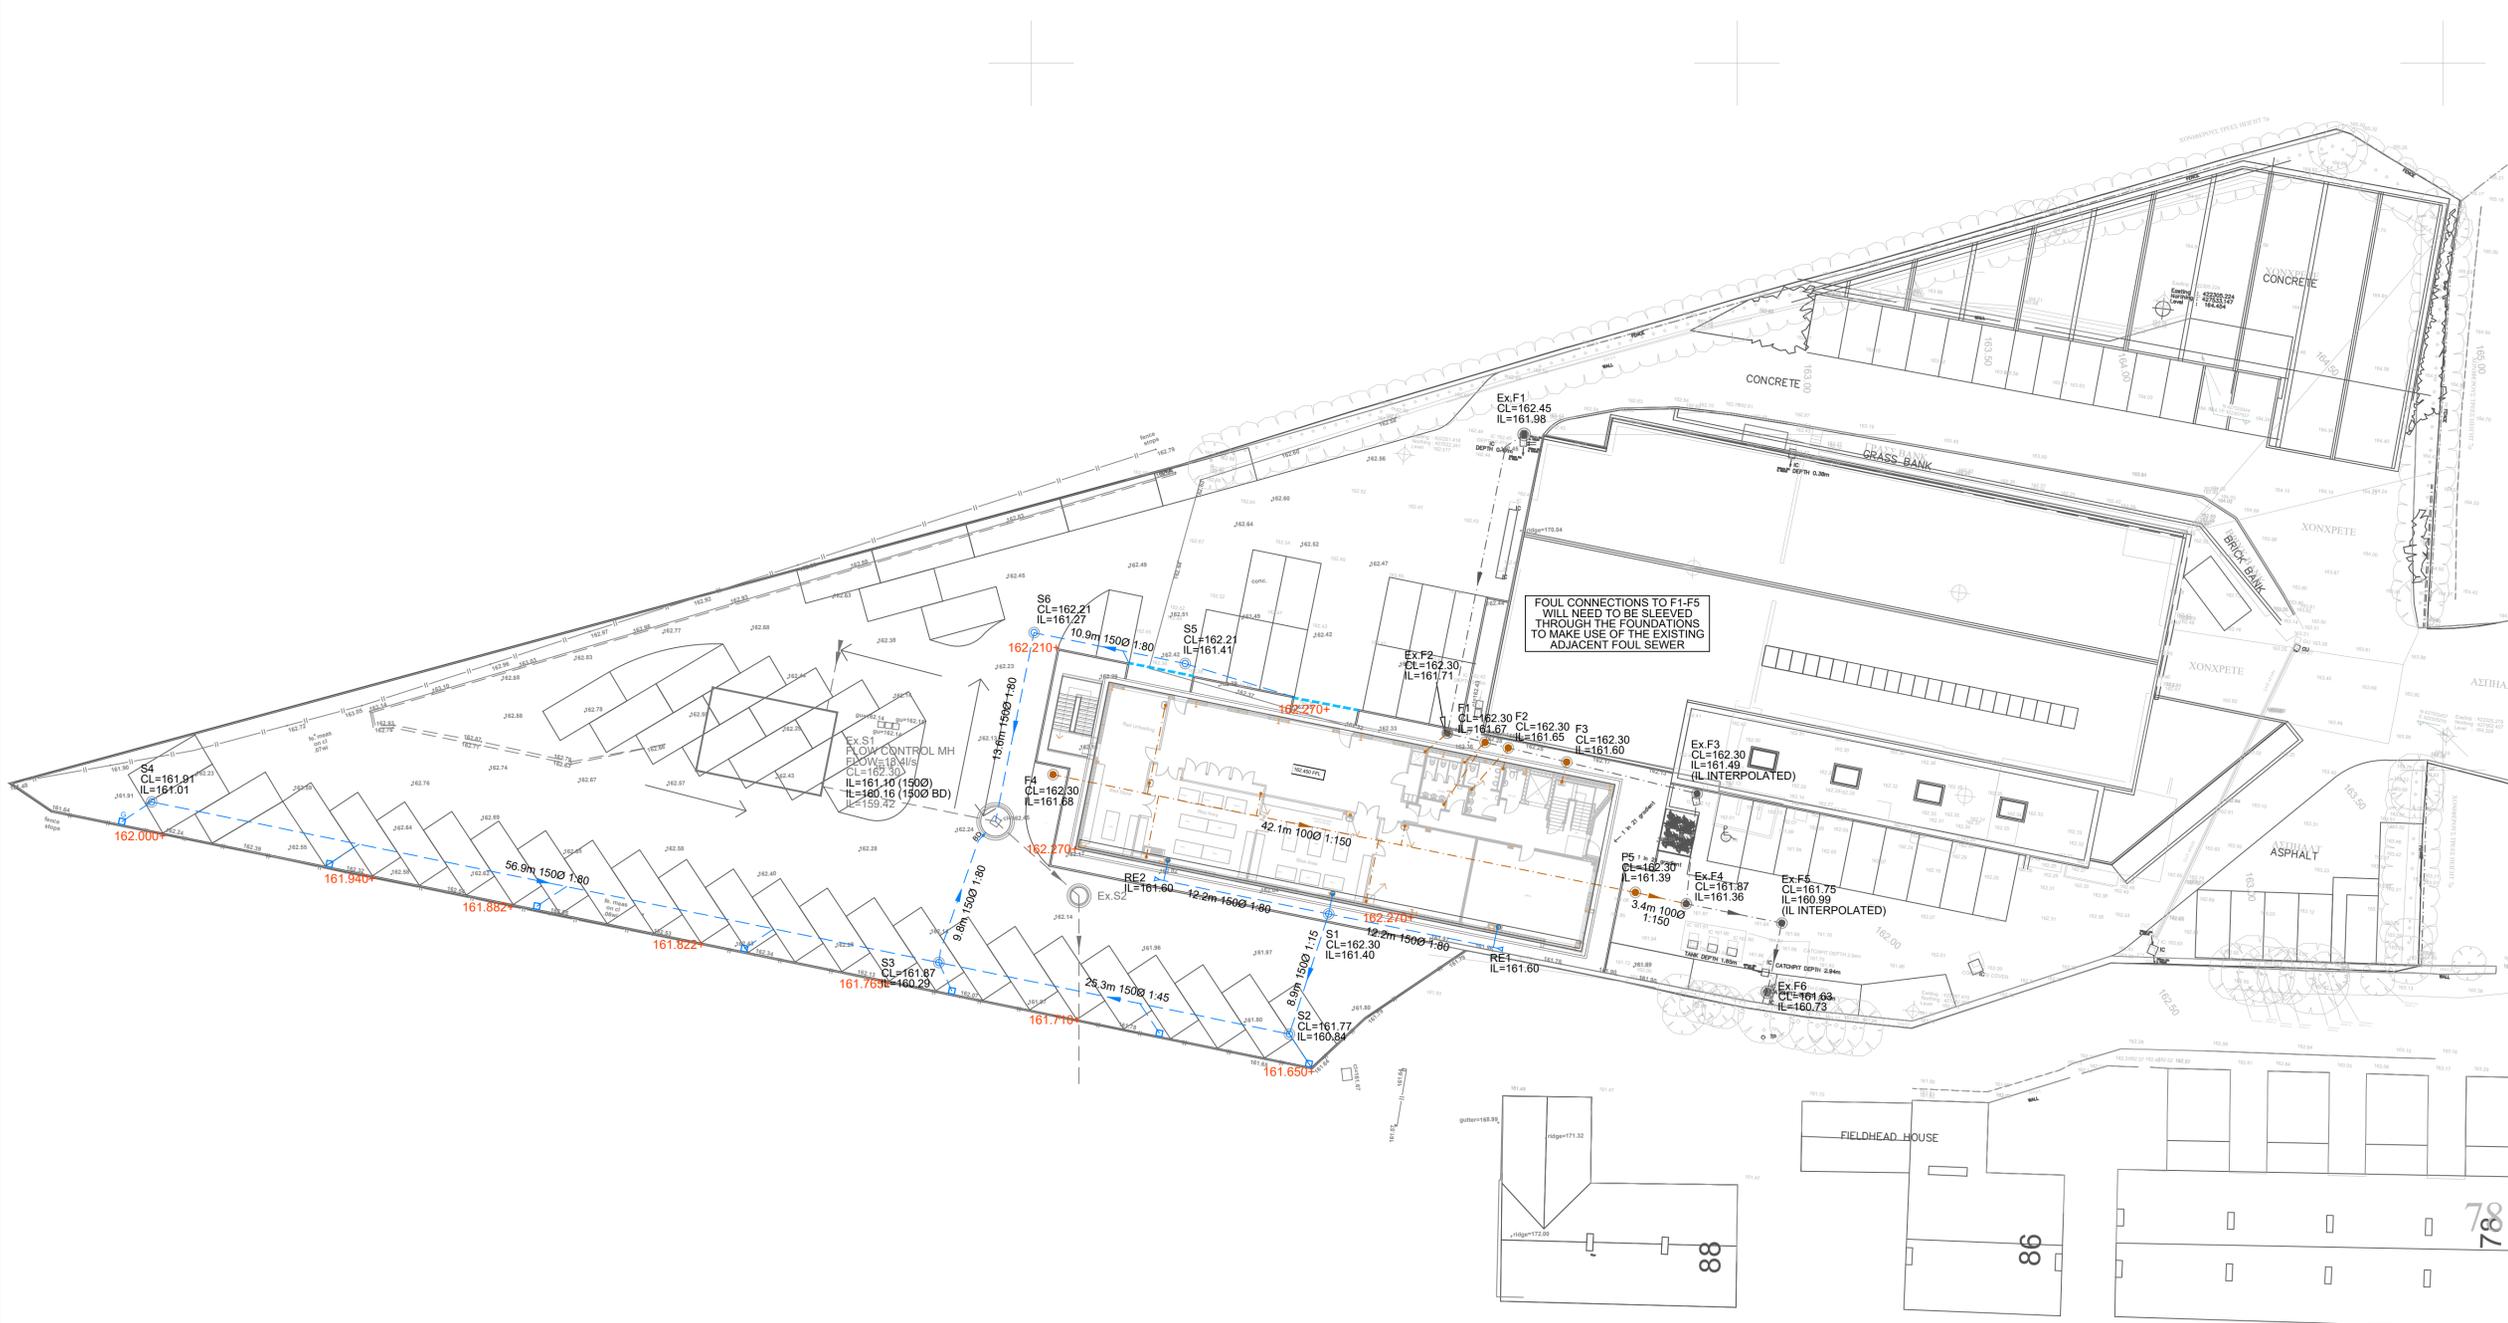

- LEGEND**
- EXISTING FOUL WATER SEWER
 - EXISTING SURFACE WATER SEWER
 - PROPOSED SURFACE WATER SEWER
 - PROPOSED FOUL WATER SEWER
 - EXISTING FOUL WATER MANHOLE
 - EXISTING SURFACE WATER MANHOLE
 - PROPOSED FOUL WATER CHAMBER
 - PROPOSED SURFACE WATER CHAMBER
 - ACO CHANNEL DRAIN (MULTIDRAIN M150D 20.0)
 - 7.68+ PRELIMINARY LEVELS
 - RWP
 - RODDING EYE
 - SVP
 - BACK DROP

P1	INITIAL ISSUE.	17.10.18	TE
Rev.	Amendments	Date	By

Revisions

PATRICK PARSONS

5 Waverley Road
Huddersfield
West Yorkshire
HD1 5NA
United Kingdom
T. +44 (0)1484 516 977
E. info@patrickparsons.co.uk
W. www.patrikparsons.co.uk

Client
PLANNED CONTRACTS LTD

Project
**BUILDING 2
JOSEPH PRIESTLEY
ENTERPRISE CENTRE**

Drawing
**DRAINAGE LAYOUT
SURFACE AND FOUL**

Scales 1:250 At original size A1

Drawn	TE	Checked	AS
Date	OCT 2018		

Status **PRELIMINARY**

Drawing No. **H17209-212** Rev. **P2**