


Foundation Plan

NOTE: All electrical work required to meet the requirements of Part P (electrical safety 2013 Edition) in England must be designed, installed, inspected and tested by a qualified installer.

 
ELECTRICAL SYMBOLS

-  INCANDESCENT LIGHT FITTING CEILING OUTLET
-  ONE WAY SWITCH
-  TWO WAY SWITCH
-  INTERMEDIATE SWITCH
-  PULL SWITCH
-  UNSWITCHED SOCKET OUTLET
-  SWITCHED SOCKET OUTLET
-  MULTIPLE SWITCHED SOCKET OUTLET
-  20A D.P. SWITCH WITH FLEX OUTLET

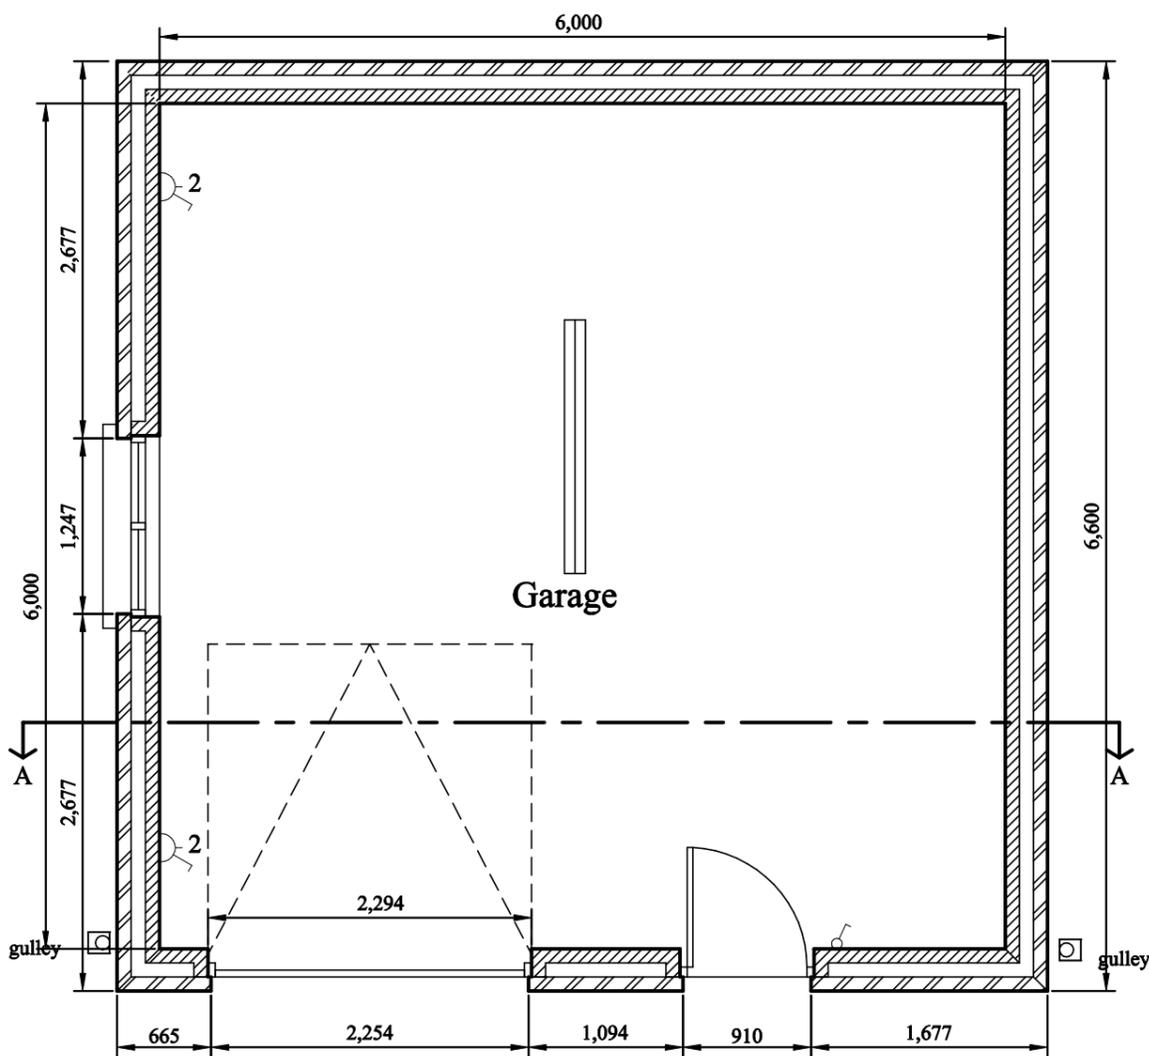

Plan

connect new storm water gully to existing storm drainage system



# GaragePlans.co.uk

1 Thorndale Road North, Hillsborough Road, Carryduff, Belfast BT8 8HY Tel: 028 9081 4106  
 Mobile: 077 2007 7465 Email: info@garageplans.co.uk Website: www.garageplans.co.uk

Standard Garage 6m x 6m  
 (6.6m x 6.6m Externally)  
 Plan Set No 6060D30LSBS

Jonathan Lawler  
 19 Headlands Road  
 Liversedge  
 West yorkshire  
 WF15 7NT

Scale: 1:50

Serial No: 262120856101

Sheet No: 1 of 4