


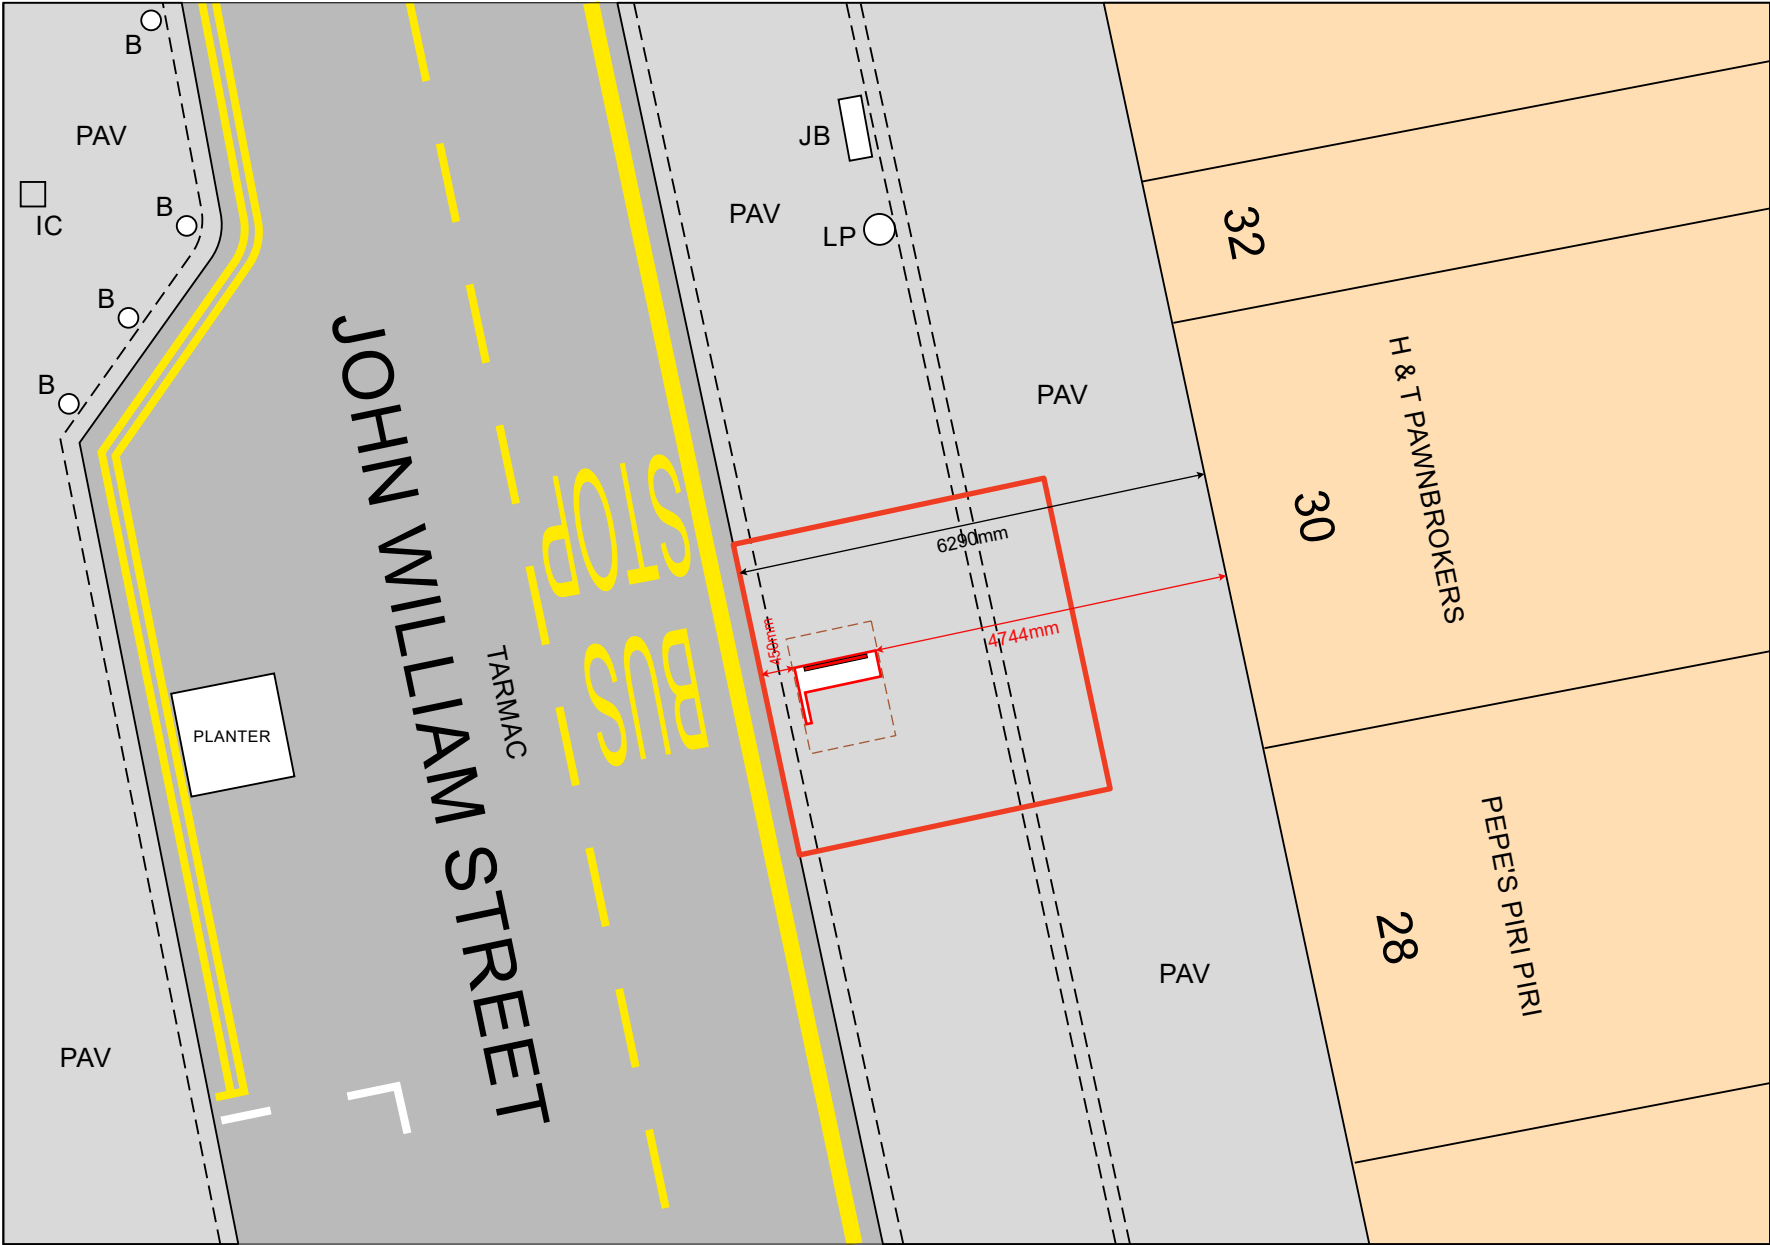

| ABBREVIATIONS |                          |      |                      |
|---------------|--------------------------|------|----------------------|
| A             | AIR CONDITIONING         | OH   | OVER HEAD            |
| ACO           | ACO CHANNEL              | P    | POST                 |
| AV            | AIR VALVE                | PAL  | PALE FENCE           |
| B             | BOLLARD                  | PAV  | PAVING               |
| BAR           | BARBED WIRE FENCE        | PB   | POST BOX             |
| BB            | BELISHA BEACON           | PC   | POST & CHAIN FENCE   |
| BD            | BACK DROP                | PFP  | PUBLIC FOOTPATH      |
| BH            | BORE HOLE                | PM   | PARKING METER        |
| BLW           | BLOCKWALL                | PR   | POST & RAIL FENCE    |
| BPV           | BLOCK PAVING             | PT   | PICKET FENCE         |
| BRW           | BRICK RETAINING WALL     | PW   | POST & WIRE FENCE    |
| BS            | BUS STOP                 | RE   | RODDING EYE          |
| BT            | BRITISH TELECOM          | RFL  | GENERAL ROOF LEVEL   |
| BW            | BRICK WALL               | RL   | RIDGE LEVEL          |
| CB            | CLOSE BOARD FENCE        | RNP  | ROAD NAME PLATE      |
| CCTV          | CLOSE CIRCUIT TELEVISION | RS   | ROAD SIGN            |
| CH            | CEILING HEIGHT           | RSJ  | ROLLED STEEL JOIST   |
| CHP           | CHESTNUT PALING FENCE    | RTW  | RETAINING WALL       |
| CL            | COVER LEVEL              | RWP  | RAIN WATER PIPE      |
| CLF           | CHAIN LINK FENCE         | SAP  | SAPLING              |
| COH           | COAL HOLE                | SC   | SPEED CAMERA         |
| COL           | COLUMN                   | SFL  | SOFFIT LEVEL         |
| CONC          | CONCRETE                 | SO   | SMOKE OUTLET         |
| CP            | CONCRETE PANEL FENCE     | SP   | SIGN POST            |
| CRB           | CRASH BARRIER            | SRW  | STONE RETAINING WALL |
| CRW           | CONCRETE RETAINING WALL  | SV   | STOP VALVE           |
| CTV           | CABLE TELEVISION         | SVP  | SOIL VENT PIPE       |
| CW            | CONCRETE WALL            | SW   | SURFACE WATER        |
| DCH           | DRAINAGE CHANNEL         | SWL  | STONE WALL           |
| DK            | DROPPED KERB             | SY   | STAY                 |
| EB            | ELECTRIC BOX             | TB   | TELEPHONE BOX        |
| EC            | ELECTRIC COVER           | TFL  | TRANSPORT FOR LONDON |
| EL            | EAVES LEVEL              | THL  | THRESHOLD LEVEL      |
| EP            | ELECTRIC POLE            | TL   | TRAFFIC LIGHT        |
| ER            | EARTH ROD                | TLB  | TRAFFIC LIGHT BUTTON |
| FB            | FLOWER BED               | TOC  | TOP OF CHIMNEY       |
| FH            | FIRE HYDRANT             | TOF  | TOP OF FENCE LEVEL   |
| FL            | FLOOR LEVEL              | TOV  | TOP OF VEGETATION    |
| FLD           | FLOOD LIGHT              | TOW  | TOP OF WALL LEVEL    |
| FP            | FLAG POLE                | TP   | TELEGRAPH POLE       |
| FW            | FOUL WATER               | TPIT | TRIAL PIT            |
| G             | GULLY                    | TPV  | TACTILE PAVING       |
| GB            | GAS BOX                  | TR   | TRELLIS FENCE        |
| GP            | GATE POST                | UK   | UNKNOWN              |
| GV            | GAS VALVE                | UTA  | UNABLE TO ACCESS     |
| HR            | HAND RAIL                | UTL  | UNABLE TO LIFT       |
| IL            | INSPECTION COVER         | UTS  | UNABLE TO SURVEY     |
| IL            | INVERT LEVEL             | V    | VALVE                |
| IR            | IRON RAILING             | VP   | VENT PIPE            |
| JB            | JUNCTION BOX             | W    | WATER COVER          |
| KO            | KERB OUTLET              | WB   | WASTE BIN            |
| LL            | LARCH LAP FENCE          | WBW  | WILDLIFE BURROW      |
| LP            | LAMP POST                | WL   | WATER LEVEL          |
| MB            | MULTI-BOLE               | WM   | WATER METER          |
| MH            | MANHOLE                  | WMF  | WIRE MESH FENCE      |
| MK            | UTILITY MARKER POST      | WO   | WASH OUT             |
| MW            | MONITORING WELL          | WV   | WATER VALVE          |

SYMBOLS & LINSTYLES

PROPOSED NEW COMMUNICATIONS KIOSK

FOUNDATION BASE

|                                                           |                |          |
|-----------------------------------------------------------|----------------|----------|
| ADDRESS                                                   |                |          |
| PAVEMENT O/S 30 JOHN WILLIAM STREET, HUDDERSFIELD HD1 1BG |                |          |
| APPLICANT                                                 | DRAWING NUMBER | REVISION |
| NWP STREET LIMITED                                        | 4906-001-003B  | -        |
| DRAWING TITLE                                             | DATE           |          |
| SITE PLAN                                                 | 23/10/2025     |          |
| SCALE                                                     | PAPER SIZE     |          |
| 1:100                                                     | A4             |          |

|                                                                                                                                                                  |
|------------------------------------------------------------------------------------------------------------------------------------------------------------------|
| GENERAL NOTES                                                                                                                                                    |
| RESPONSIBILITY IS NOT ACCEPTED FOR ERRORS MADE BY OTHERS IN SCALING FROM THIS DRAWING. ALL CONSTRUCTION INFORMATION SHOULD BE TAKEN FROM FIGURED DIMENSIONS ONLY |

