
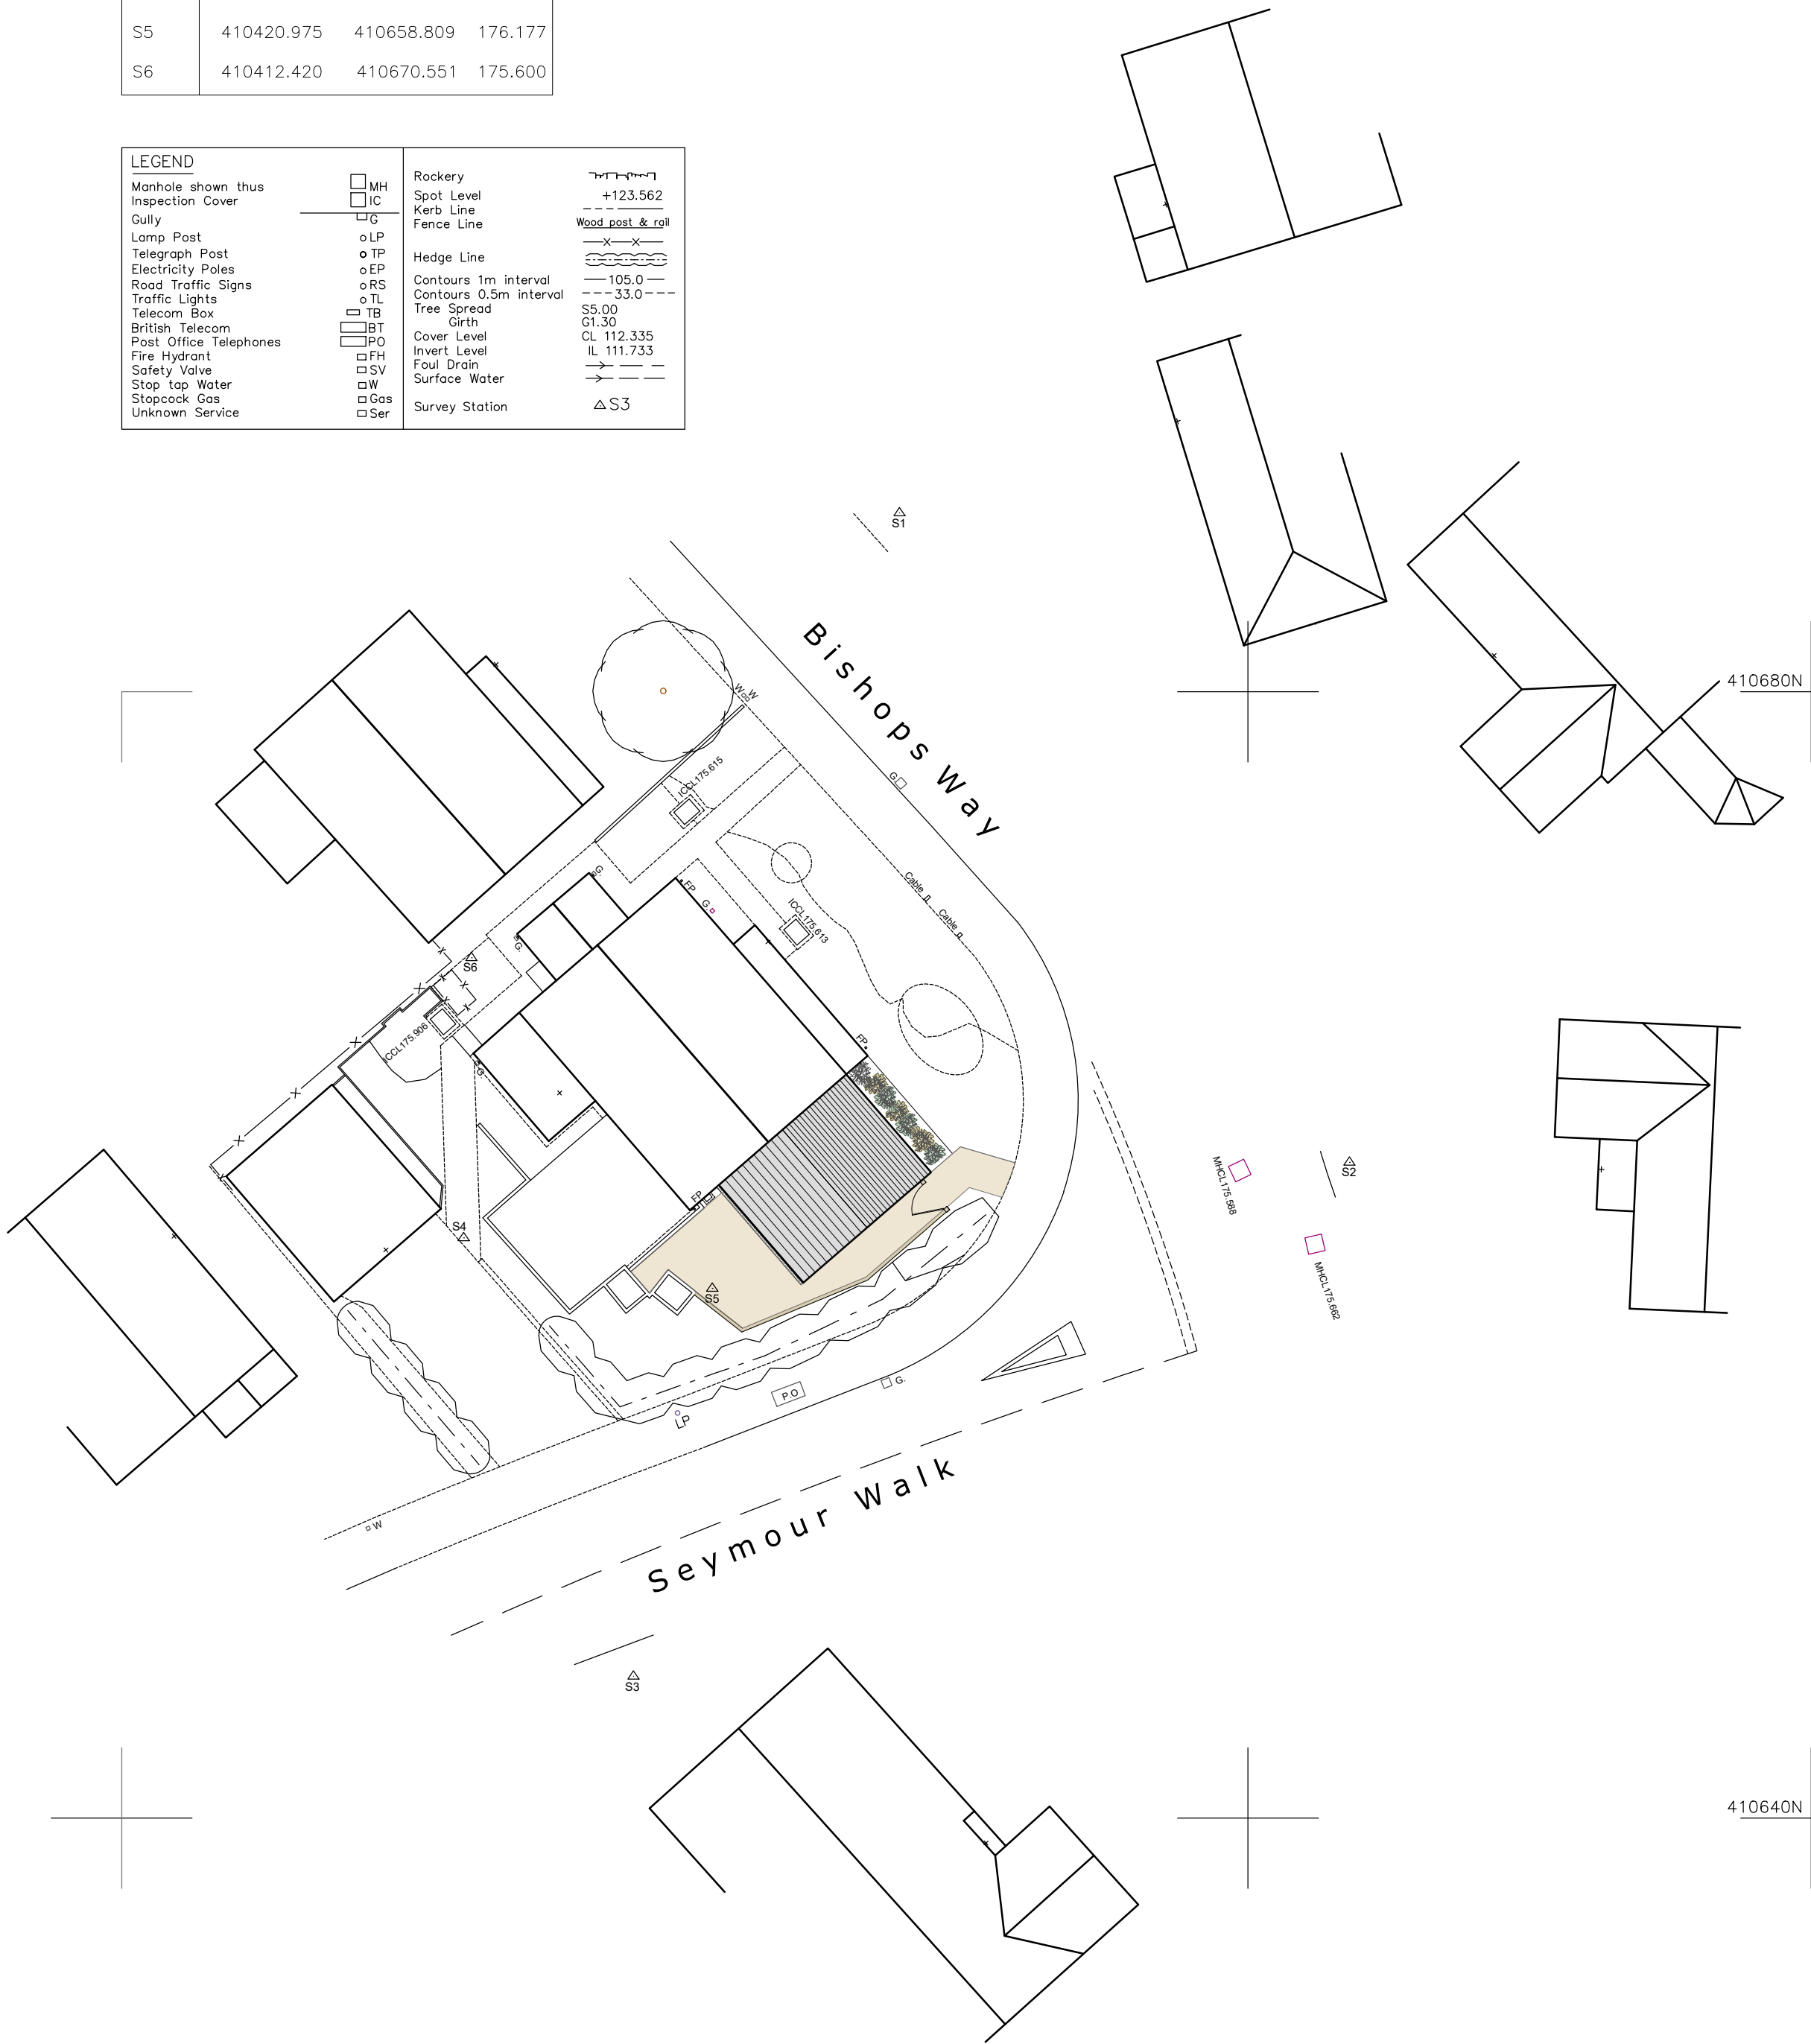


SURVEY STATIONS			
Station	Easting	Northing	Level
S1	410427.624	410686.348	174.964
S2	410443.602	410663.286	175.643
S3	410418.175	410645.033	176.765
S4	410412.144	410660.602	176.342
S5	410420.975	410658.809	176.177
S6	410412.420	410670.551	175.600

LEGEND			
Manhole shown thus	□ MH	Rockery	---X---X---
Inspection Cover	□ IC	Spot Level	+123.562
Gully	□ G	Kerb Line	--- 33.0 ---
Lamp Post	○ LP	Fence Line	Wood post & rail
Telegraph Post	○ TP	Hedge Line	---X---X---
Electricity Poles	○ EP	Contours 1m interval	--- 105.0 ---
Road Traffic Signs	○ RS	Contours 0.5m interval	--- 33.0 ---
Traffic Lights	○ TL	Tree Spread	S5.00
Telecom Box	□ TB	Girth	G1.30
British Telecom	□ BT	Cover Level	CL 112.335
Post Office Telephones	□ PO	Invert Level	IL 111.733
Fire Hydrant	□ FH	Foul Drain	→ ---
Safety Valve	□ SV	Surface Water	→ ---
Stop tap Water	□ W	Survey Station	△ S3
Stopcock Gas	□ Gas		
Unknown Service	□ Ser		

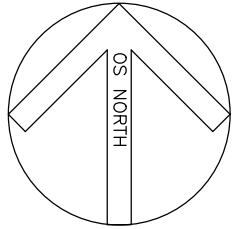

This drawing has been prepared specifically for the purpose of obtaining Planning Permission and/or Building Regulation Approval. Its suitability for other purposes, without supplementary details and specifications cannot be guaranteed. The Permissions and/or Approvals are beyond the Architects control, and no guarantee that such will be granted is given or to be inferred by reason of the preparation of this drawing.

Only figured dimensions are to be used. All dimensions to be checked on site. This drawing together with the design is the property and copyright of the Architect and must not be reproduced without prior written permission.

P01	Drawing originated	11.11.25	JW	NG
rev.	description	date	drawn	approved

AHP

project Proposed single storey extension
and internal alterations
at
4 Bishops Way, Meltham
Holmfirth, HD9 4BW
for
Mr and Mrs Roberts

title Site plan as proposed
number 25074D-05-P01
scale 1:200
size A2

ARCHITECTURE
AND DESIGN

The Old Police Station 16 Bridge Lane Holmfirth HD9 7AN
T: 01484 685411 E: hello@adp-architects.com
W: www.adp-architects.com

RIBA 
Chartered Practice