


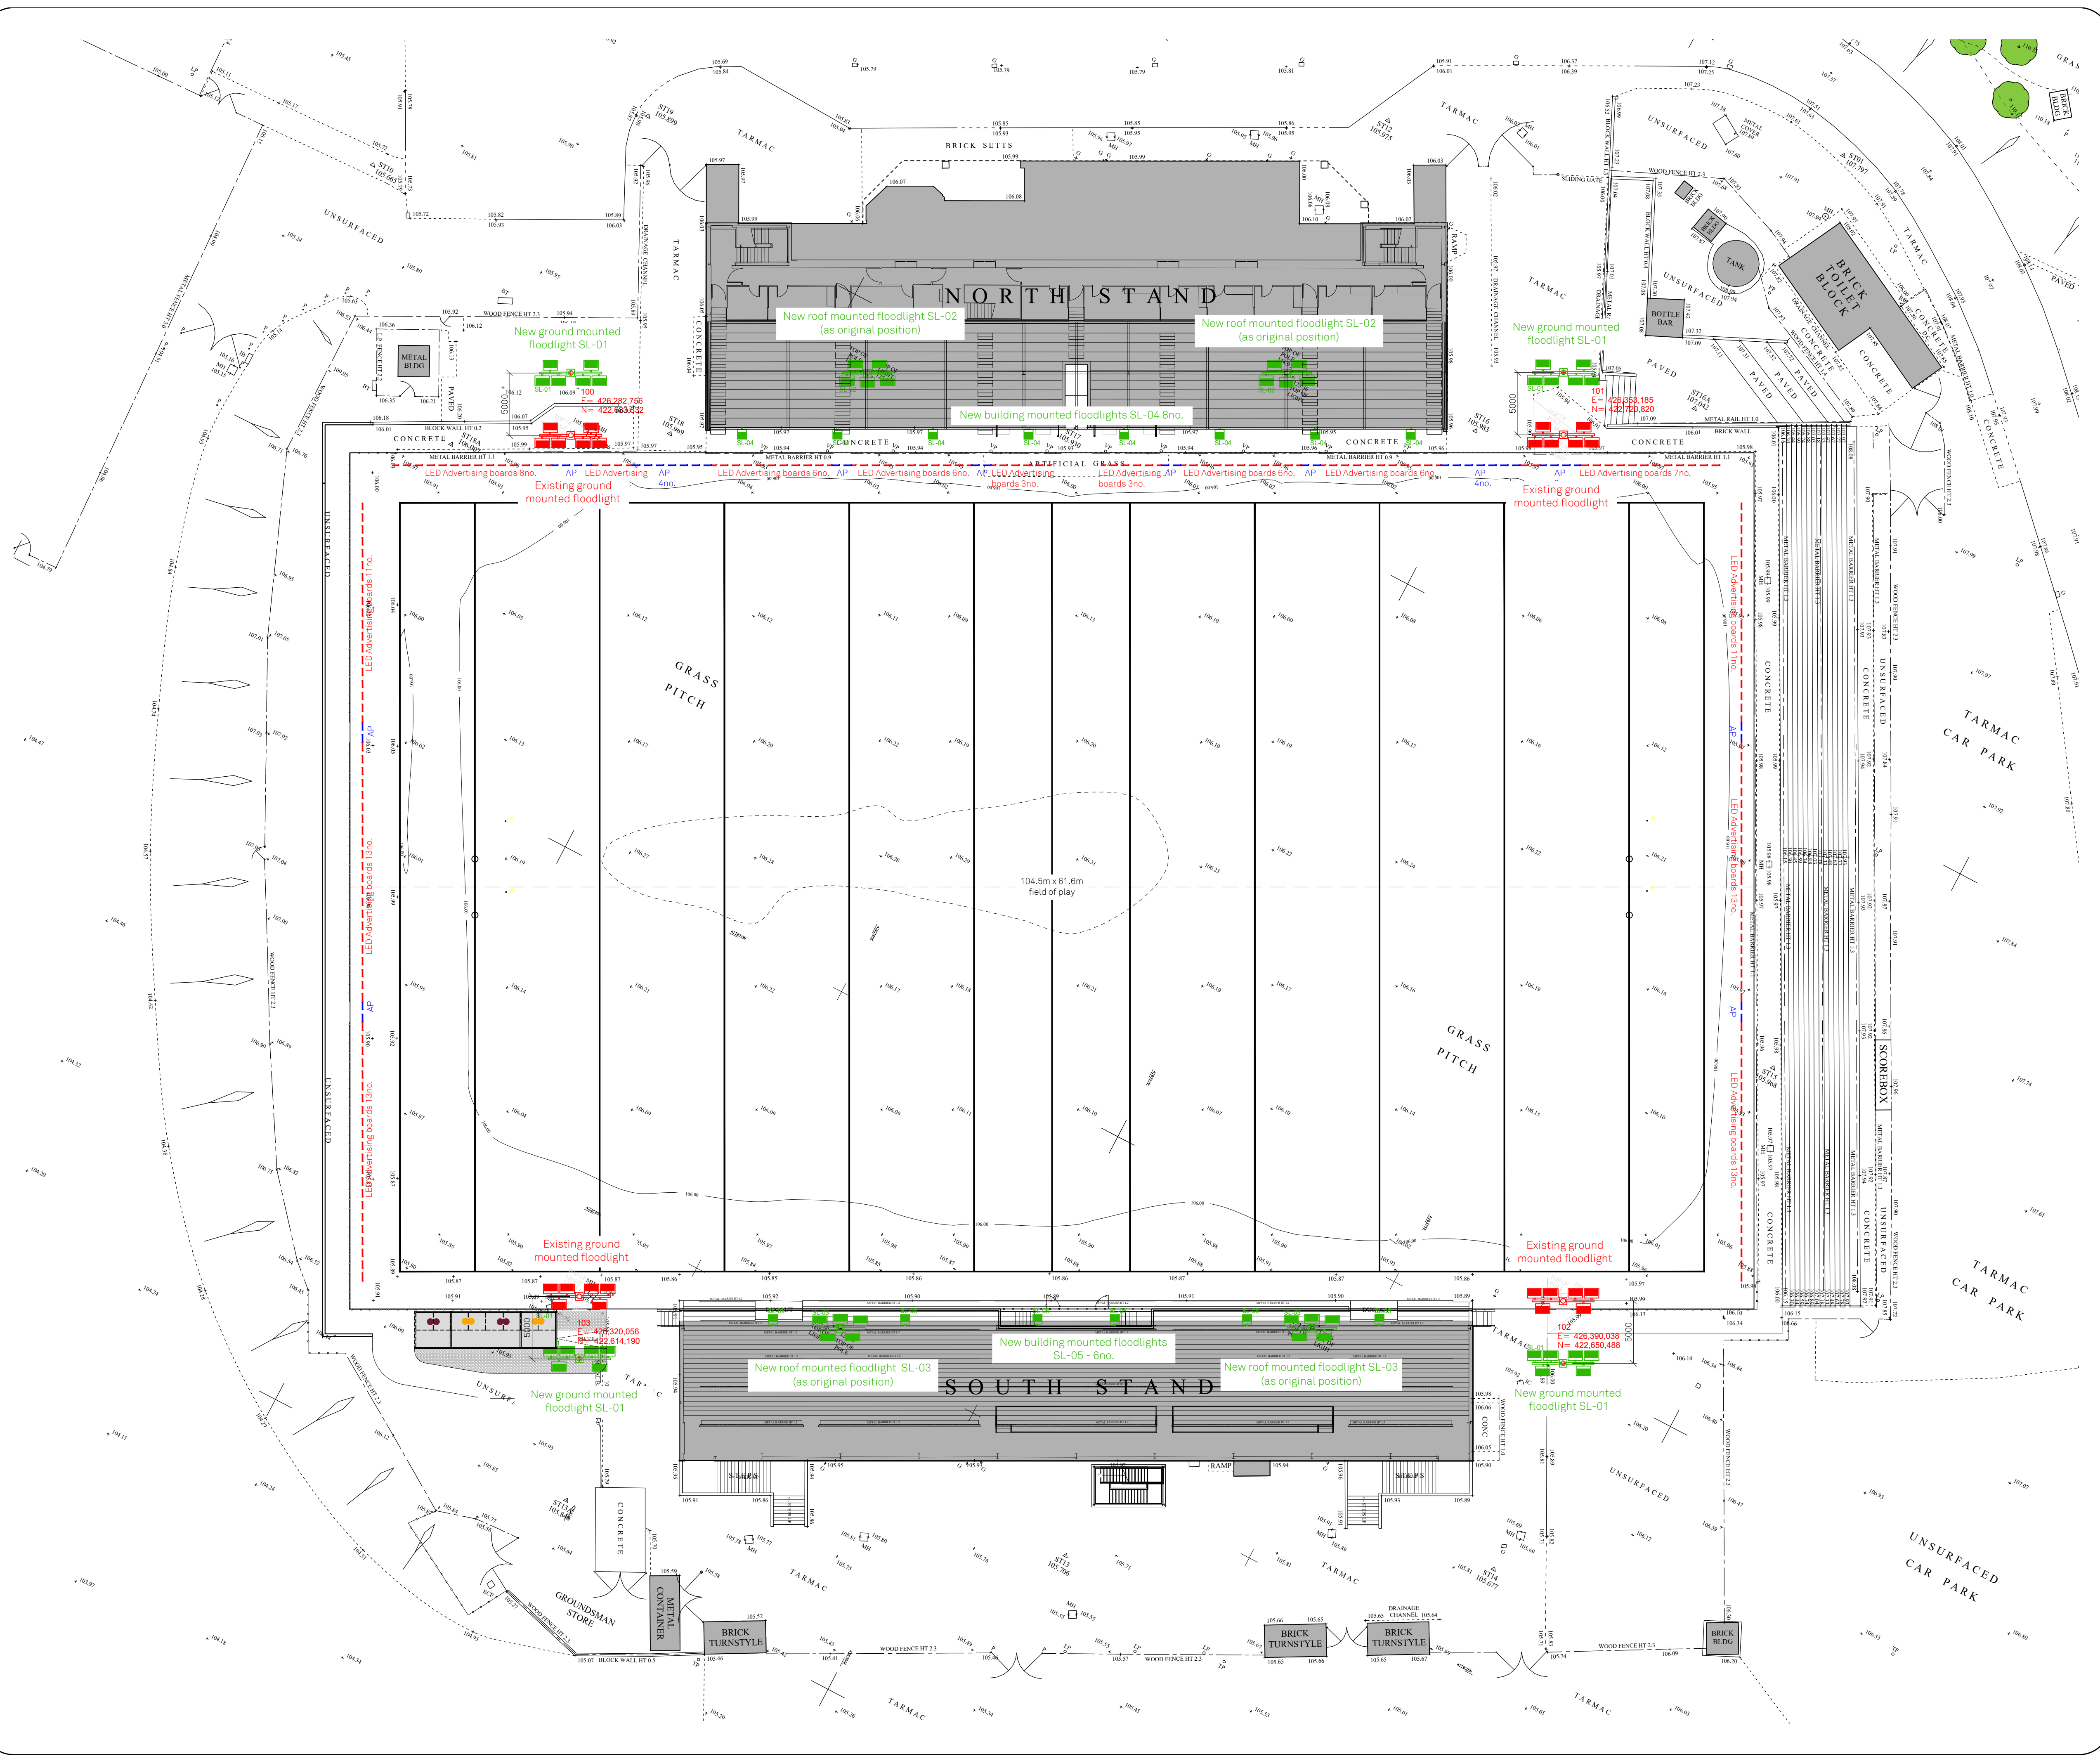

Notes			
Station	Easting	Northing	Level
ST01	426364.977	422746.035	107.797
ST02	426391.253	422756.918	110.250
ST03	426469.275	422707.706	108.755
ST04	426492.463	422650.986	107.801
ST05	426490.817	422572.028	106.516
ST06	426447.150	422645.263	106.788
ST07	426362.612	422600.987	105.222
ST08	426318.851	422548.876	103.787
ST09	426243.796	422519.885	103.058
ST10	426260.968	422691.736	103.665
ST11	426283.102	422724.541	106.295
ST12	426311.153	422732.153	105.975
ST13	426361.881	422618.319	105.706
ST14	426302.770	422633.290	105.677
ST15	426393.939	422679.263	105.968
ST16	426349.121	422713.388	105.983
ST17	426320.699	422698.740	105.930
ST18	426302.606	422683.215	105.969
ST19	426278.677	422704.932	105.899
ST20	426240.155	422718.754	105.605
ST13A	426324.398	422603.663	105.846
ST16A	426363.843	422723.155	107.042
ST18A	426276.959	422674.318	106.007

Floodlight - Set Out Co Ordinates		
Ref	Eastings	Northings
100	426.282,756	422.683,832
101	426.353,185	422.720,820
102	426.390,038	422.650,488
103	426.320,056	422.614,190

Revisions		
Rev	Date	Description
A	Oct 26	Updated to latest site plan

BUILDING MANAGEMENT SERVICES LTD

Huddersfield Road
Elland, West Yorkshire
HX5 9BW
TELEPHONE : ELLAND (01422) 371616
FAX No : (01422) 376717
email : mail@bmselland.com

Building Management Services

Client

Commercial Development Projects Ltd

Project

FLAIR Stadium
Owl Lane
Dewsbury

Sheet	
Flood Lighting Setting Out	
Drawn	B.D.L.
Scale	1:250 @ A1
Status	Planning
Drawing No.	M3310-08
Date	Sept 2026
Revision	Rev A